

Dimensions are not to be scaled from this drawing




Kingfisher Lighting

Part of the Luceco PLC group of companies



Amnis LED

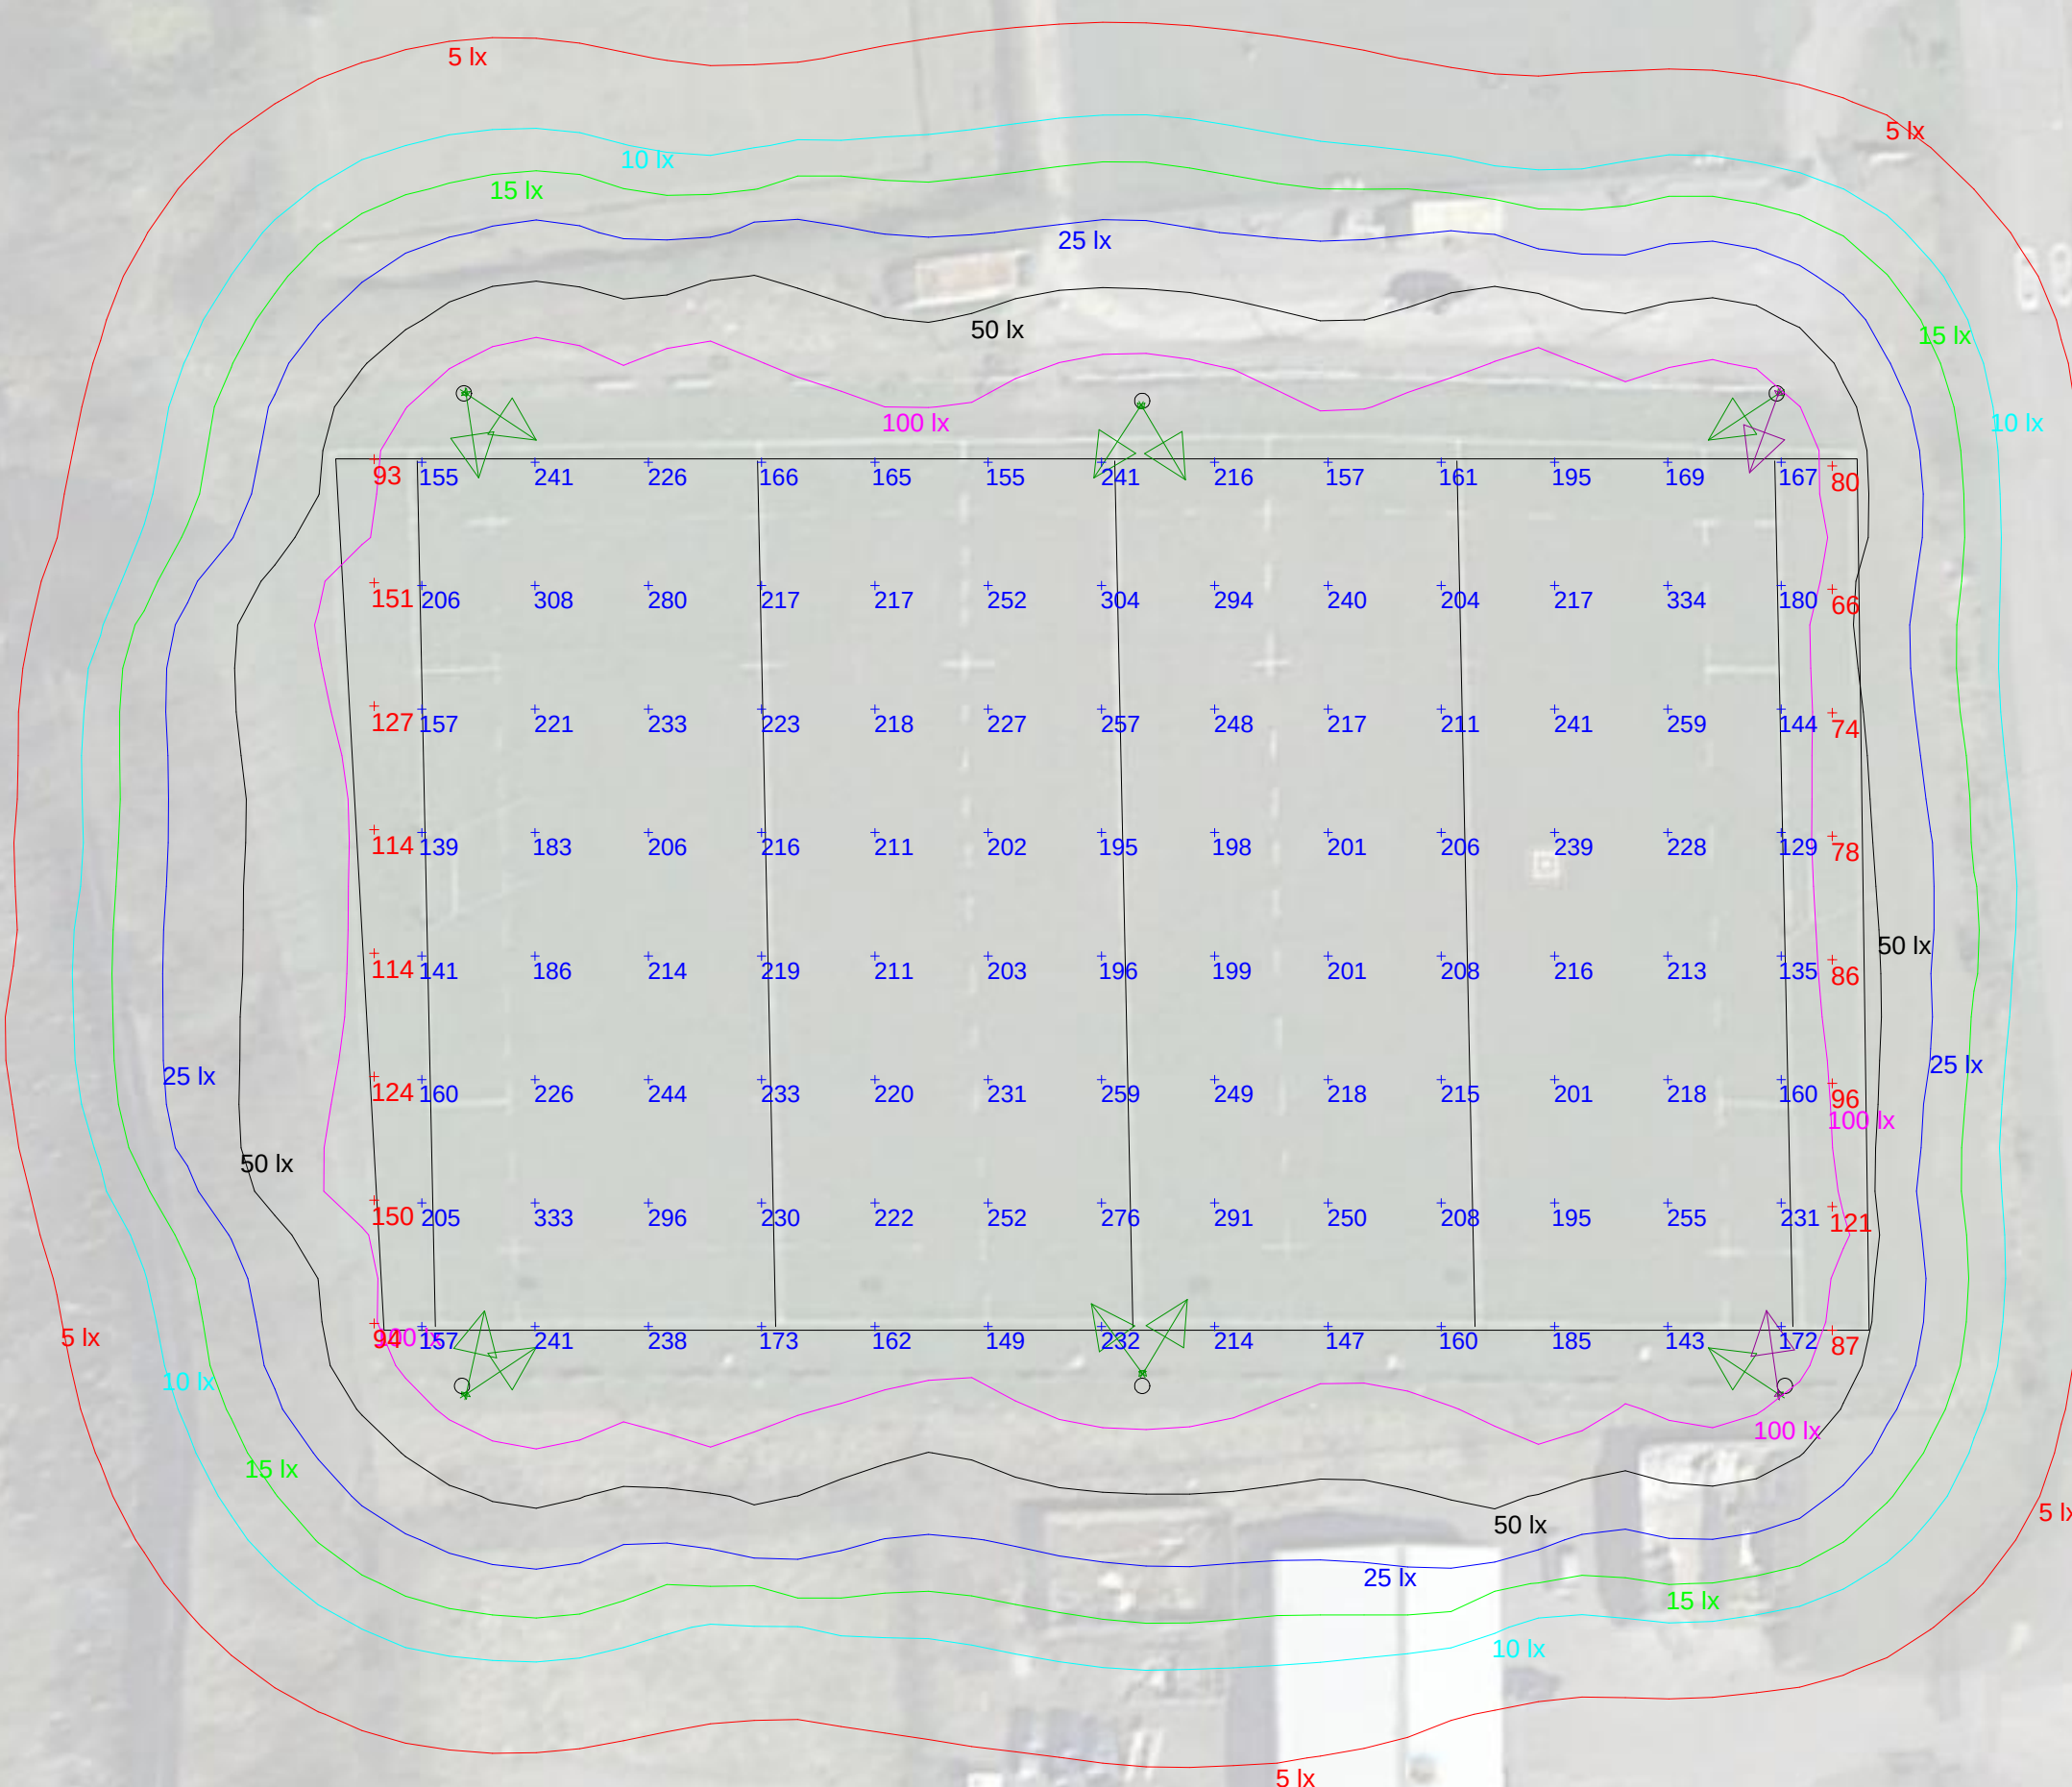

Calculation Summary							
Label	CalcType	Units	Avg	Max	Min	Min/Avg	Min/Max
ISO	Illuminance	Lux	34.60	371	0	0.00	0.00
Rugby Field	Illuminance	Lux	212.20	334	129	0.61	0.39
Rugby Field End	Illuminance	Lux	86.00	121	66	0.77	0.55
Rugby Field End 2	Illuminance	Lux	120.88	151	93	0.77	0.62

Luminaire Schedule				
Symbol	Qty	Label	Arrangement	Description
	10	A	SINGLE	1 x Amnis 1350W Short Narrow Throw Mounted @ 15m
	2	B	SINGLE	1 x 910w Amnis PRO with NST Optic Mounted @ 15m



Glyncorrwg RFC



For our LED lighting designs a 0.9mf has been used. If this differs from the maintenance period for this project then you must advise us accordingly

Scale	Project Number
1: 500 at A2	DD35863B NGLYNCORRWG RFC
Date	Drawing No.
28/10/19	D35863/TF/B
Lighting Designer : Tom Ford	

A lighting applications design service is provided by us in good faith and without charge, relating to Kingfisher products only. As such, whilst every endeavor is made for accuracy from information provided by yourselves, the final responsibility for the suitability of the design lies with the client. The company cannot, therefore, accept any liability or consequential loss incurred.