


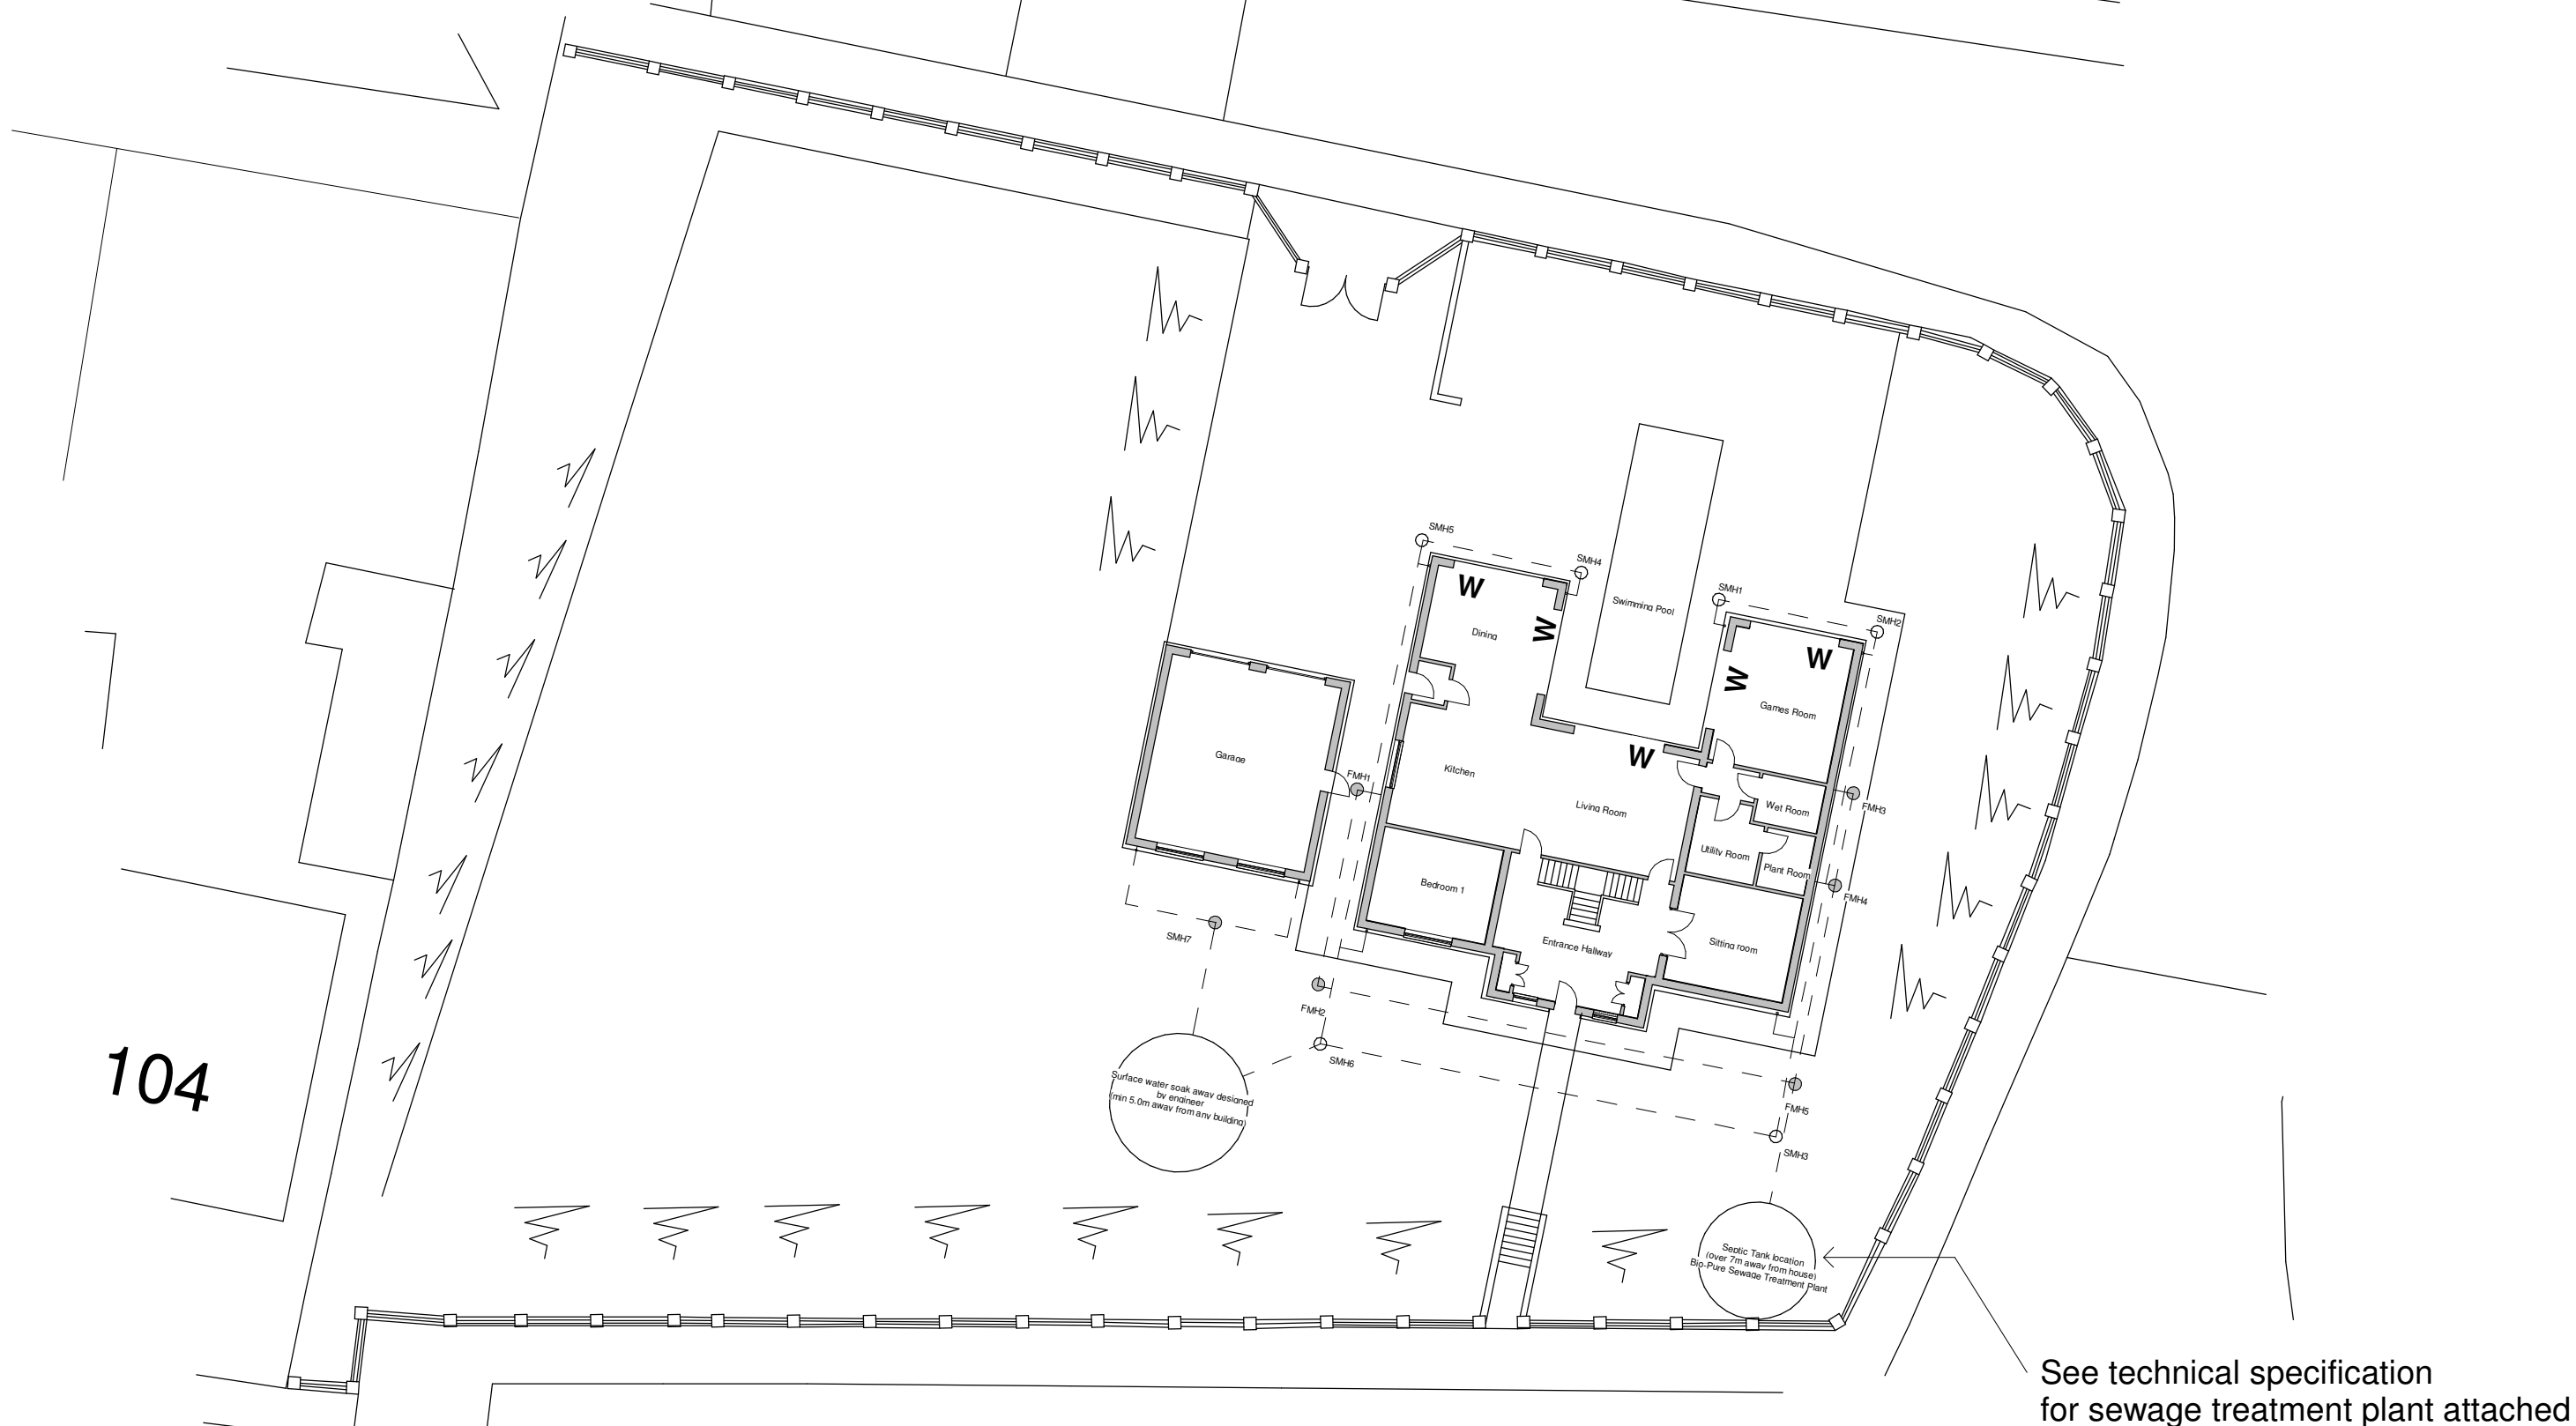

104

A4109

1 Proposed drainage plan

1 : 250

See technical specification
for sewage treatment plant attached

	No.	Description	Date	 www.ccs-solutions.co.uk				PROJECT Rosewarn House		CLIENT Mr Dean Davies		
										Date 16/06/2020	Project number Project Number	Scale (@ A3) 1 : 250
				CODE	STATUS	SUITABILITY DESCRIPTION	PURPOSE OF ISSUE	SHEET Proposed drainage plan		Drawn by CCS	DRWAING NUMBER A101	REV A
										Checked by CCS		