
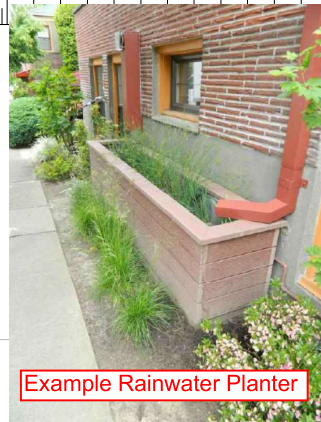


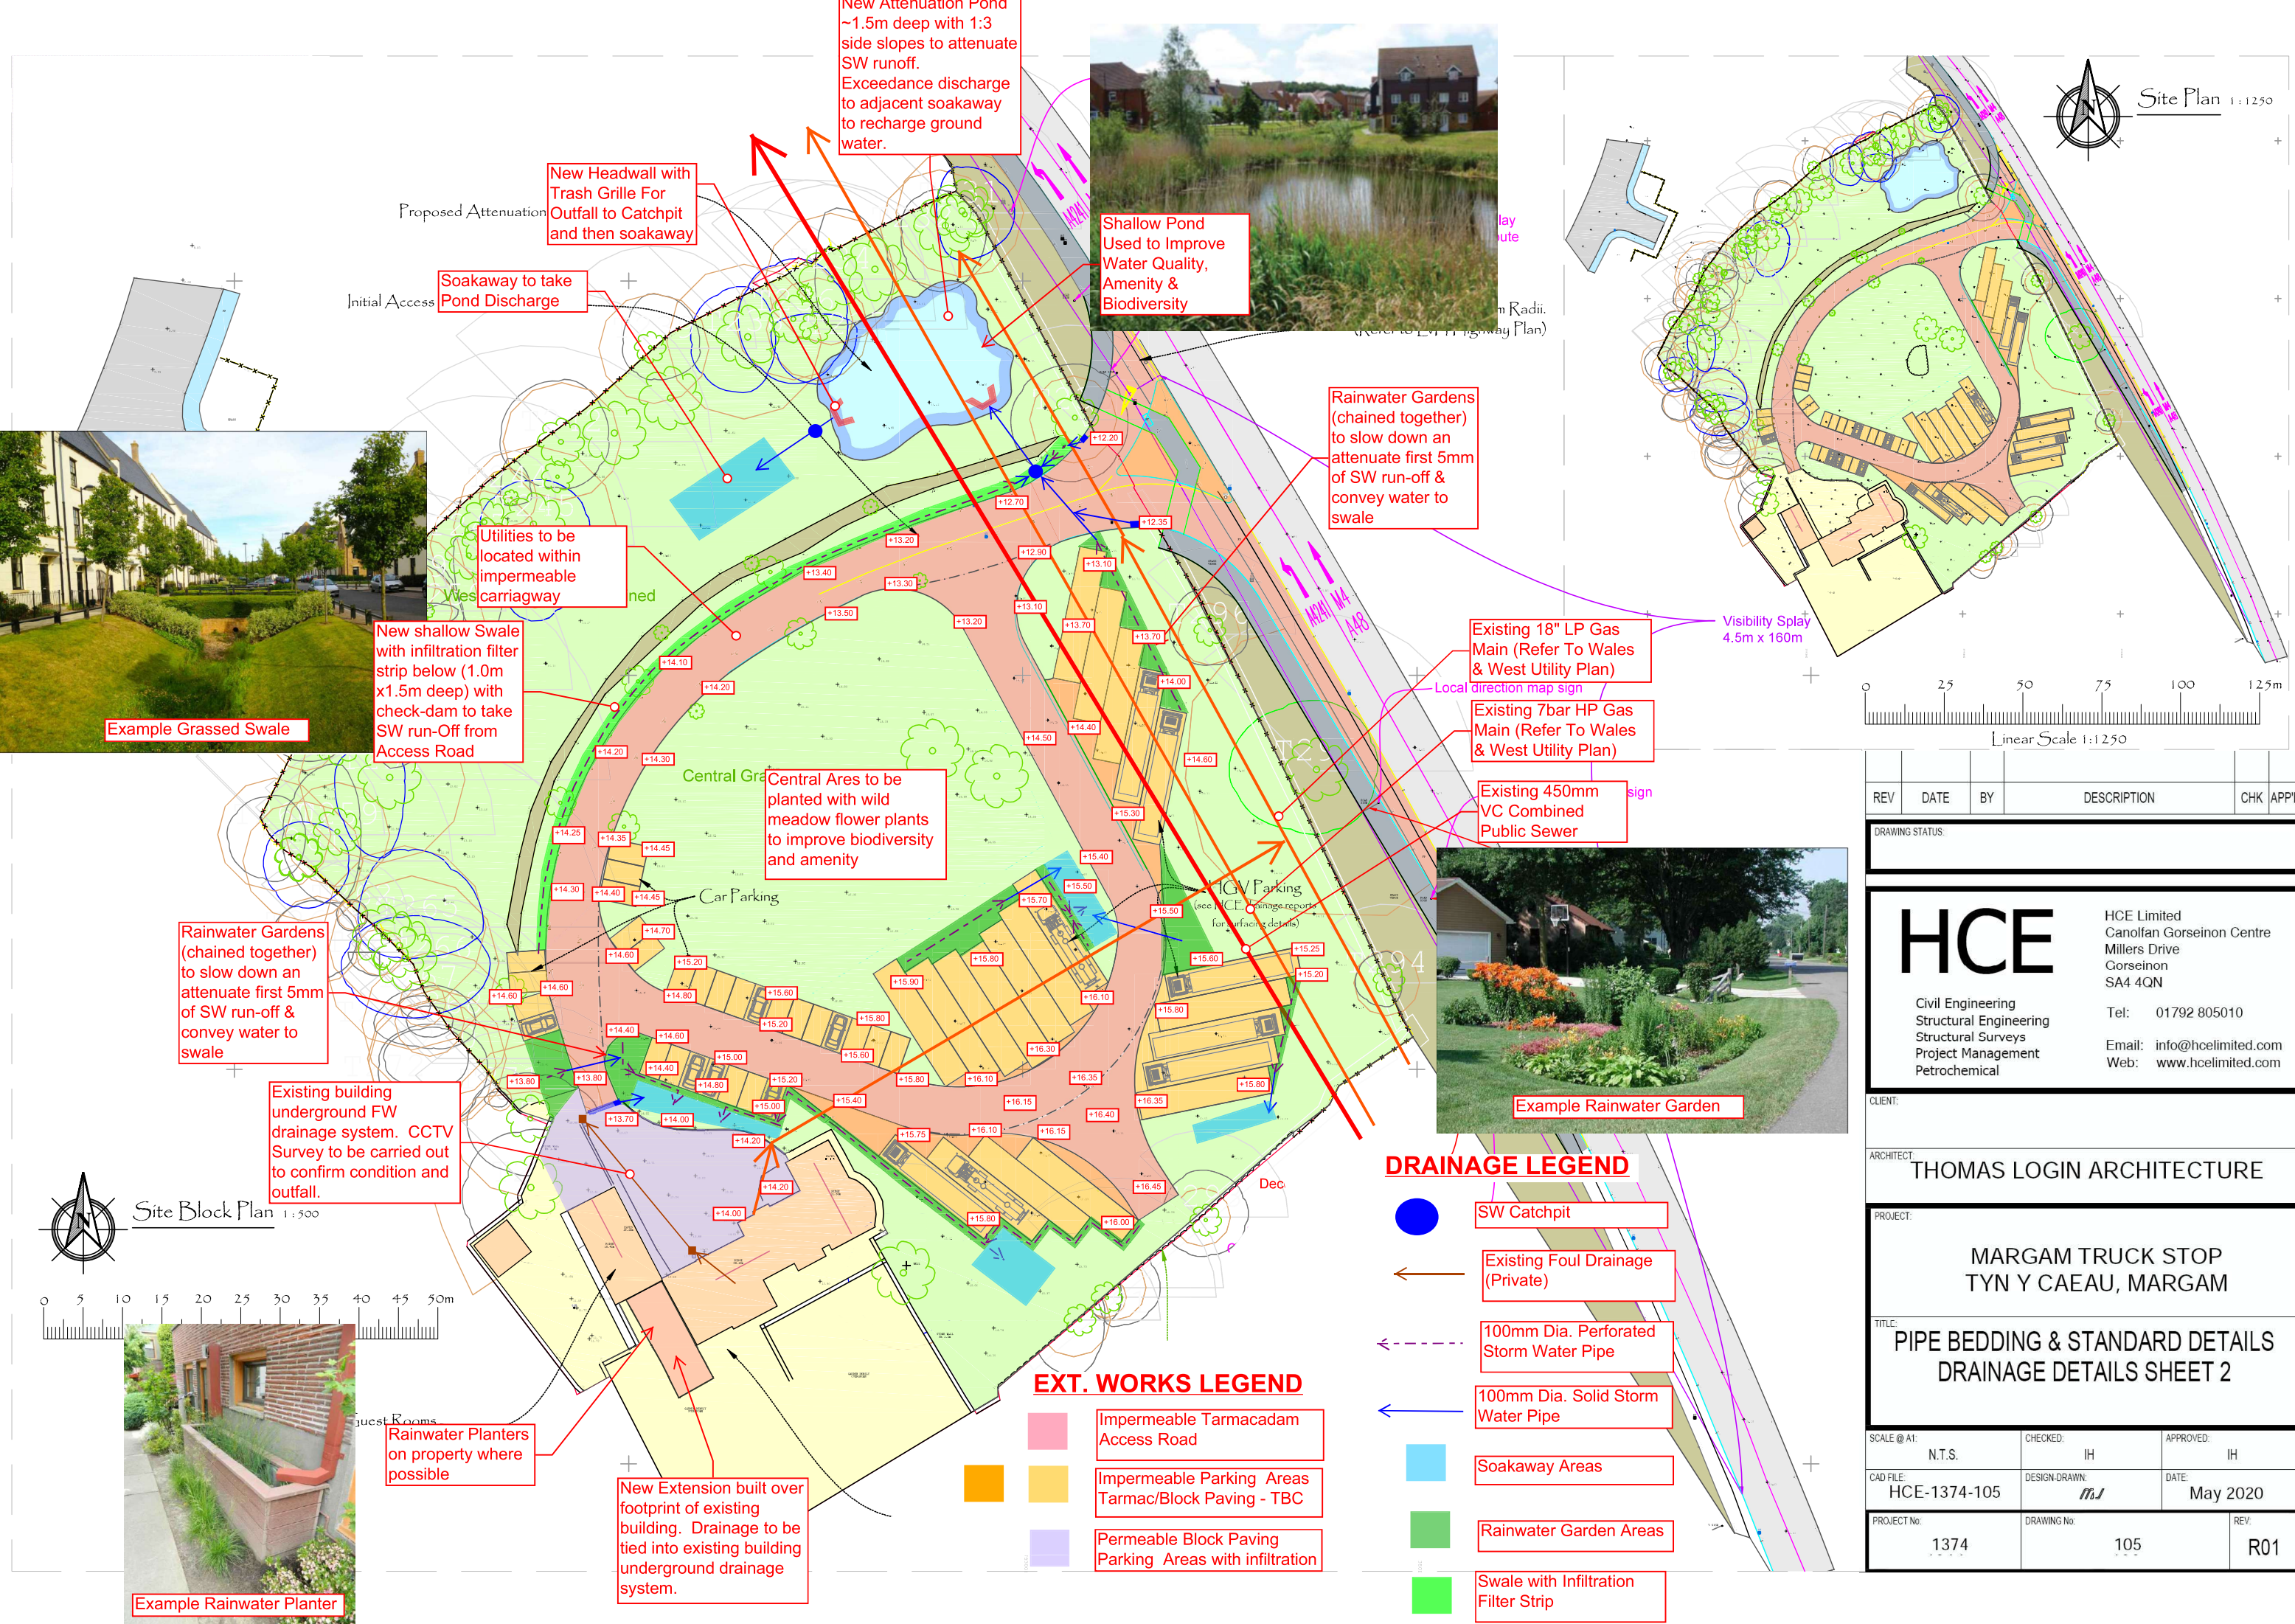

EXT. WORKS LEGEND

 
- Impermeable Tarmac/Access Road
- Impermeable Parking Areas Tarmac/Block Paving - TBC
- Permeable Block Paving Parking Areas with infiltration

DRAINAGE LEGEND

- SW Catchpit
- Existing Foul Drainage (Private)
- 100mm Dia. Perforated Storm Water Pipe
- 100mm Dia. Solid Storm Water Pipe
- Soakaway Areas
- Rainwater Garden Areas
- Swale with Infiltration Filter Strip



Site Plan 1:1250



REV	DATE	BY	DESCRIPTION	CHK	APP'D
-----	------	----	-------------	-----	-------

DRAWING STATUS:

HCE

Civil Engineering
Structural Engineering
Structural Surveys
Project Management
Petrochemical

HCE Limited
Canolfan Gorseion Centre
Millers Drive
Gorseion
SA4 4QN

Tel: 01792 805010
Email: info@hcelimited.com
Web: www.hcelimited.com

CLIENT:

ARCHITECT: THOMAS LOGIN ARCHITECTURE

PROJECT: MARGAM TRUCK STOP
TYN Y CAEU, MARGAM

TITLE: PIPE BEDDING & STANDARD DETAILS
DRAINAGE DETAILS SHEET 2

SCALE @ A1: N.T.S.	CHECKED: IH	APPROVED: IH
CAD FILE: HCE-1374-105	DESIGN-DRAWN: m/j	DATE: May 2020
PROJECT No: 1374	DRAWING No: 105	REV: R01