


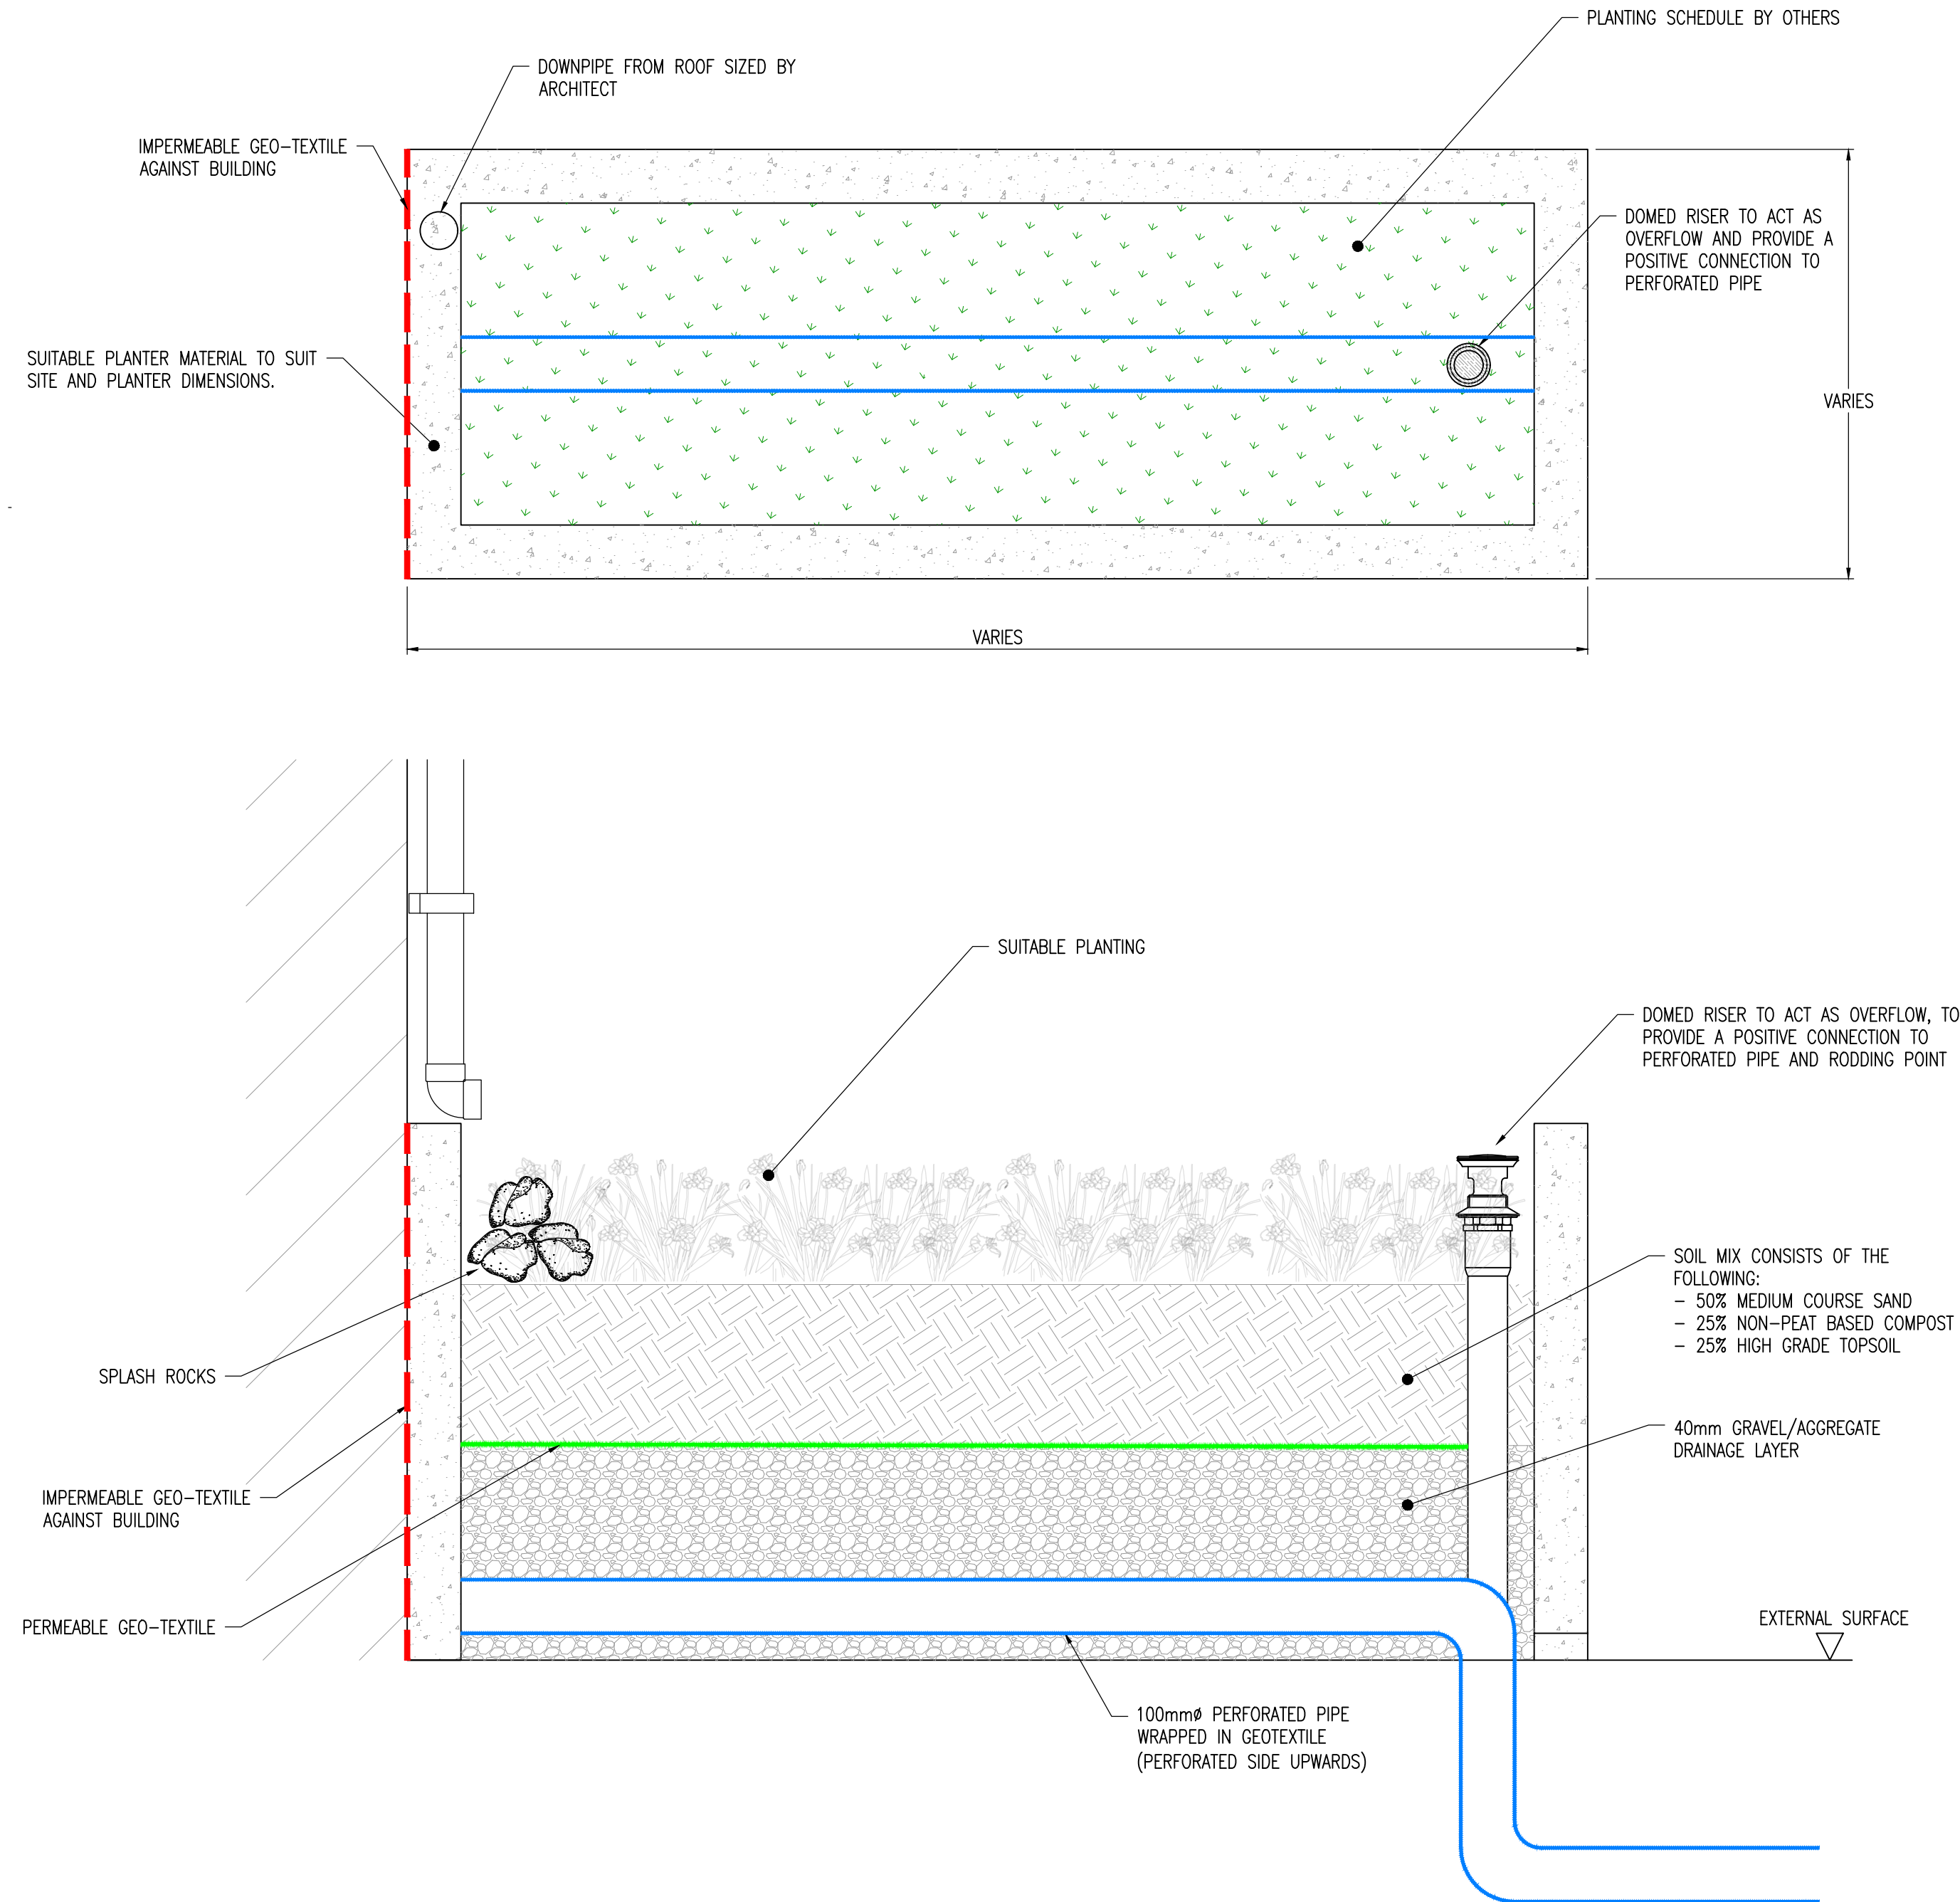

TYPICAL RAIN PLANTER DETAILS
SCALE 1:10

- GENERAL NOTES
- DO NOT SCALE THIS DRAWING.
 - CONTRACTOR TO CHECK ALL DIMENSIONS AND REPORT ALL ERRORS AND OMISSIONS TO THE ENGINEER.
 - ANY DISCREPANCY TO BE REPORTED IMMEDIATELY TO THE ENGINEER.
 - THIS DRAWING TO BE READ IN CONJUNCTION WITH ALL RELEVANT ARCHITECTS, SUBCONTRACTORS AND SPECIALISTS DRAWINGS AND SPECIFICATIONS.

Rev.	Detail	By	Date
------	--------	----	------

Revisions

Reinforcement schedules nos.

CB3
CONSULT

Structural & Civil Engineering Consultants

First Floor
7 St James Crescent
Swansea
SA1 6DP

Telephone +44 1792 473 182
e-mail admin@cb3consult.co.uk
web www.cb3consult.co.uk

Client
LIFE PROPERTY GROUP LTD

Project
HOUSING DEVELOPMENT –
26 ALFRED STREET,
NEATH,
SA11 1EH

Drawing Title
DRAINAGE
STANDARD DETAILS

PRELIMINARY

Project No. C1616	Drawing No. C-SK03
Scales AS STATED	Date 12.08.20
Drawn H	Checked DH
Sheet Size A1	Revision