





Reproduced from an Ordnance Survey map with the permission of the
Controller of Her Majesty's Stationary Office.
©Crown Copyright. All rights reserved.

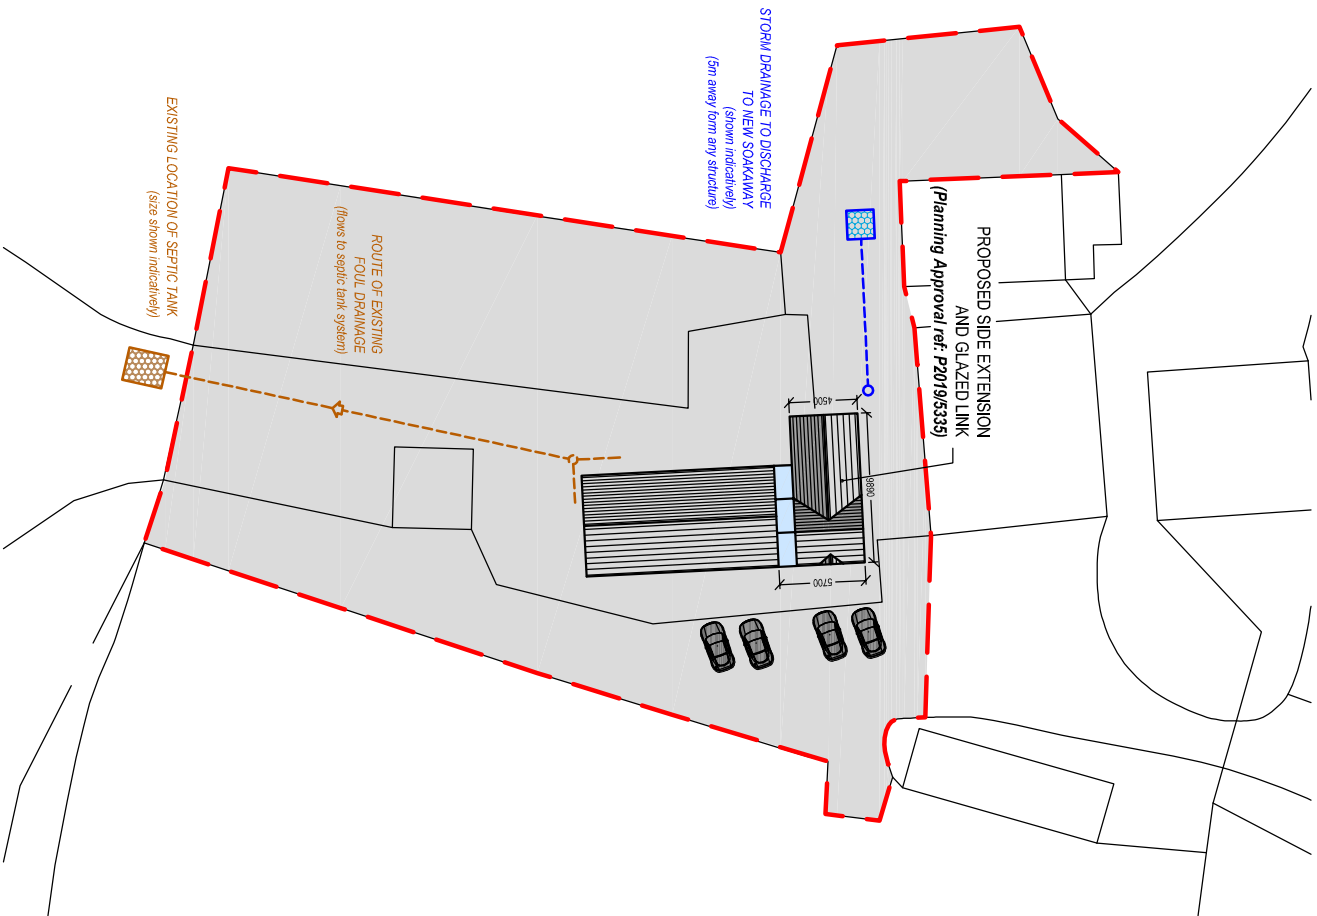

EXISTING DRAINAGE PLAN
Scale 1:500

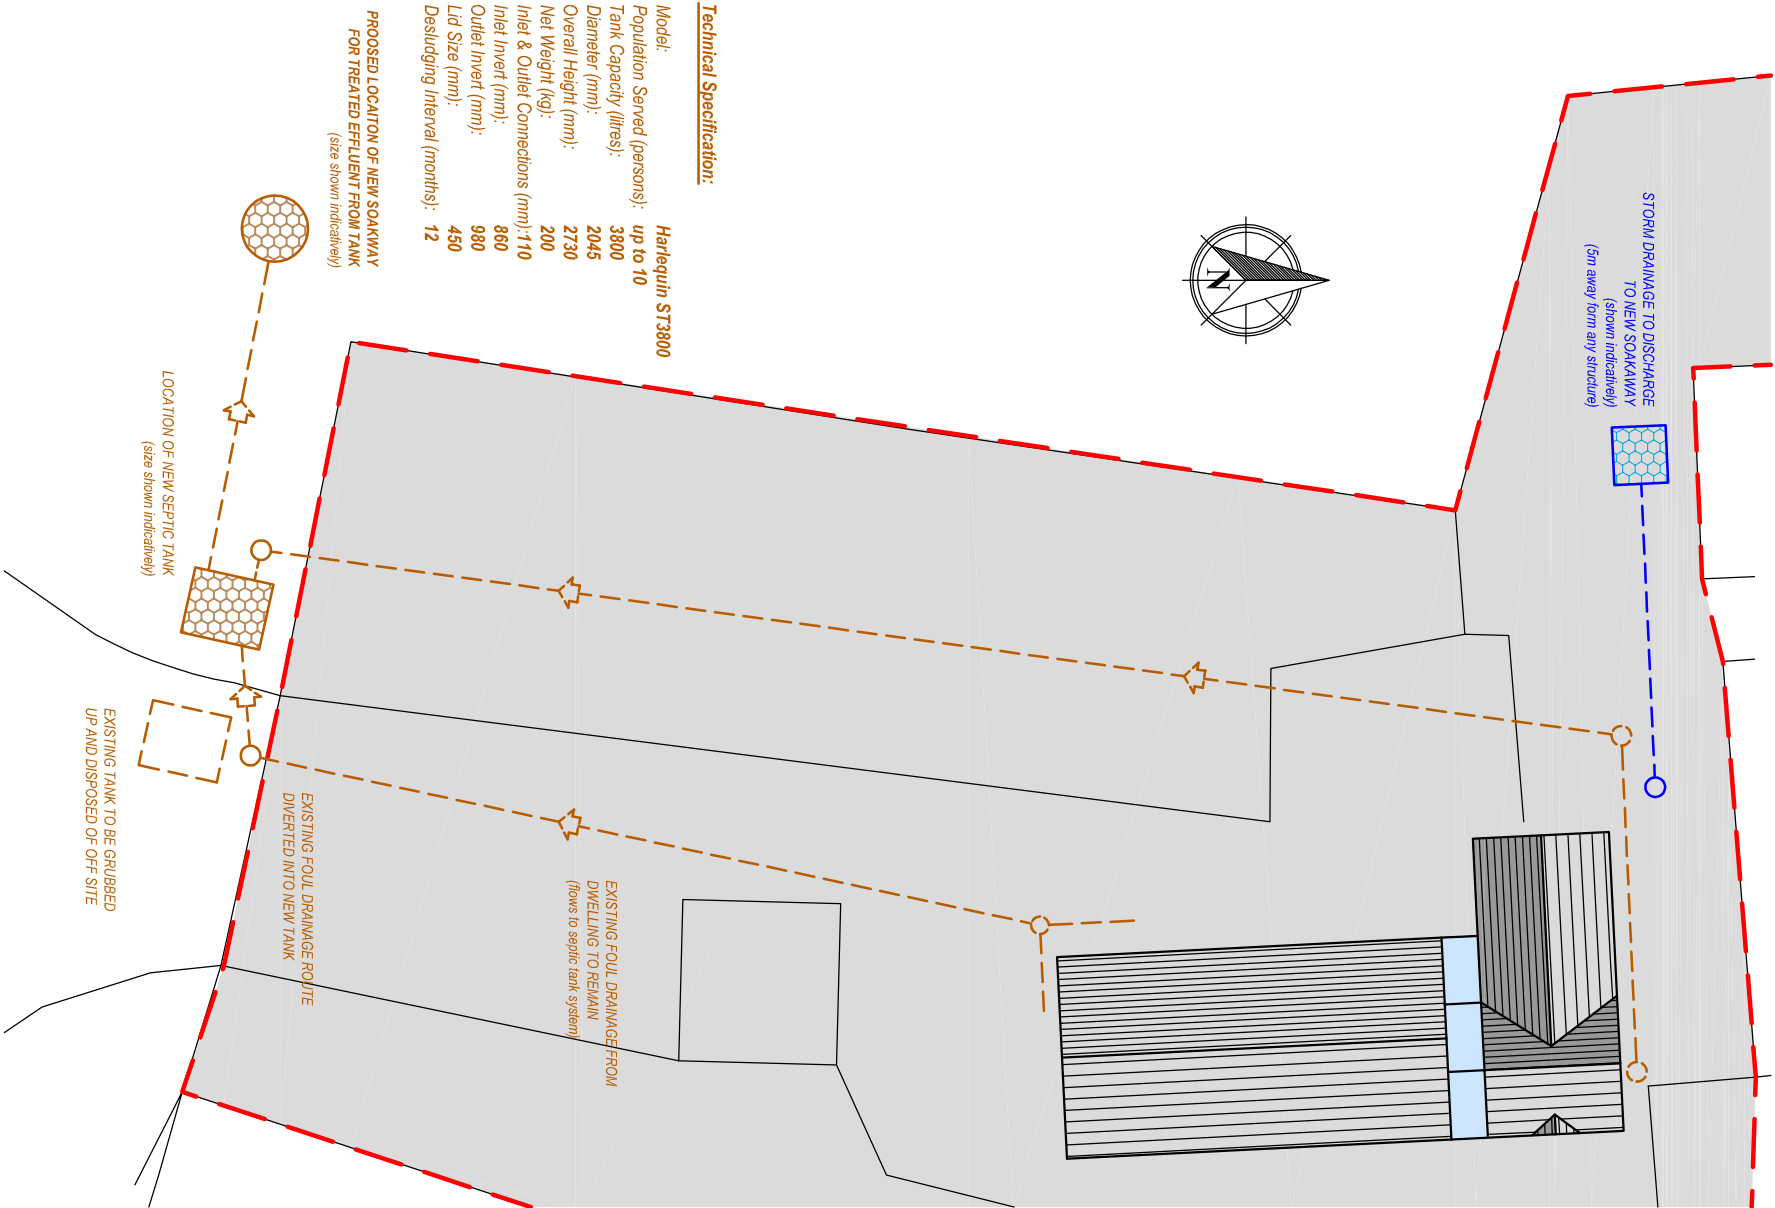

Technical Specification:

Model:	Harlequin ST3800
Population Served (persons):	up to 10
Tank Capacity (litres):	3800
Diameter (mm):	2045
Overall Height (mm):	2730
Net Weight (kg):	200
Inlet & Outlet Connections (mm):	110
Inlet Invert (mm):	860
Outlet Invert (mm):	980
Lid Size (mm):	450
Desludging Interval (months):	12

PROPOSED LOCATION OF NEW SOAKAWAY
FOR TREATED EFFLUENT FROM TANK
(size shown indicatively)

LOCATION OF NEW SEPTIC TANK
(size shown indicatively)

EXISTING TANK TO BE GRUBBED
UP AND DISPOSED OF OFF SITE

EXISTING FOUL DRAINAGE ROUTE
DIVERTED INTO NEW TANK

EXISTING FOUL DRAINAGE FROM
DWELLING TO REMAIN
(flows to septic tank system)

PROPOSED DRAINAGE PLAN
Scale 1:250

Client:

Mr. C. Budd & Dr. S. Reynolds
Clipentan Farm
Taigwaith

Project Title:

PROPOSED REPLACEMENT
OF
EXISTING SEWERAGE
TREATMENT SYSTEM

General Notes:

1. Do not scale from this drawing, take figured dimensions only.
2. Dimensions are in millimetres unless otherwise stated.

Drawing Issue:

PLANNING

Drawing Title:

EXISTING & PROPOSED DRAINAGE PLANS

Drawing No:	002	Revision:	
Date:	24-09-2020	Revised:	
Scale(s):	1:500 / 1:250	Paper Size:	A3



Cwm Planning & Design Ltd.
(architectural and Draughting Services)