
 


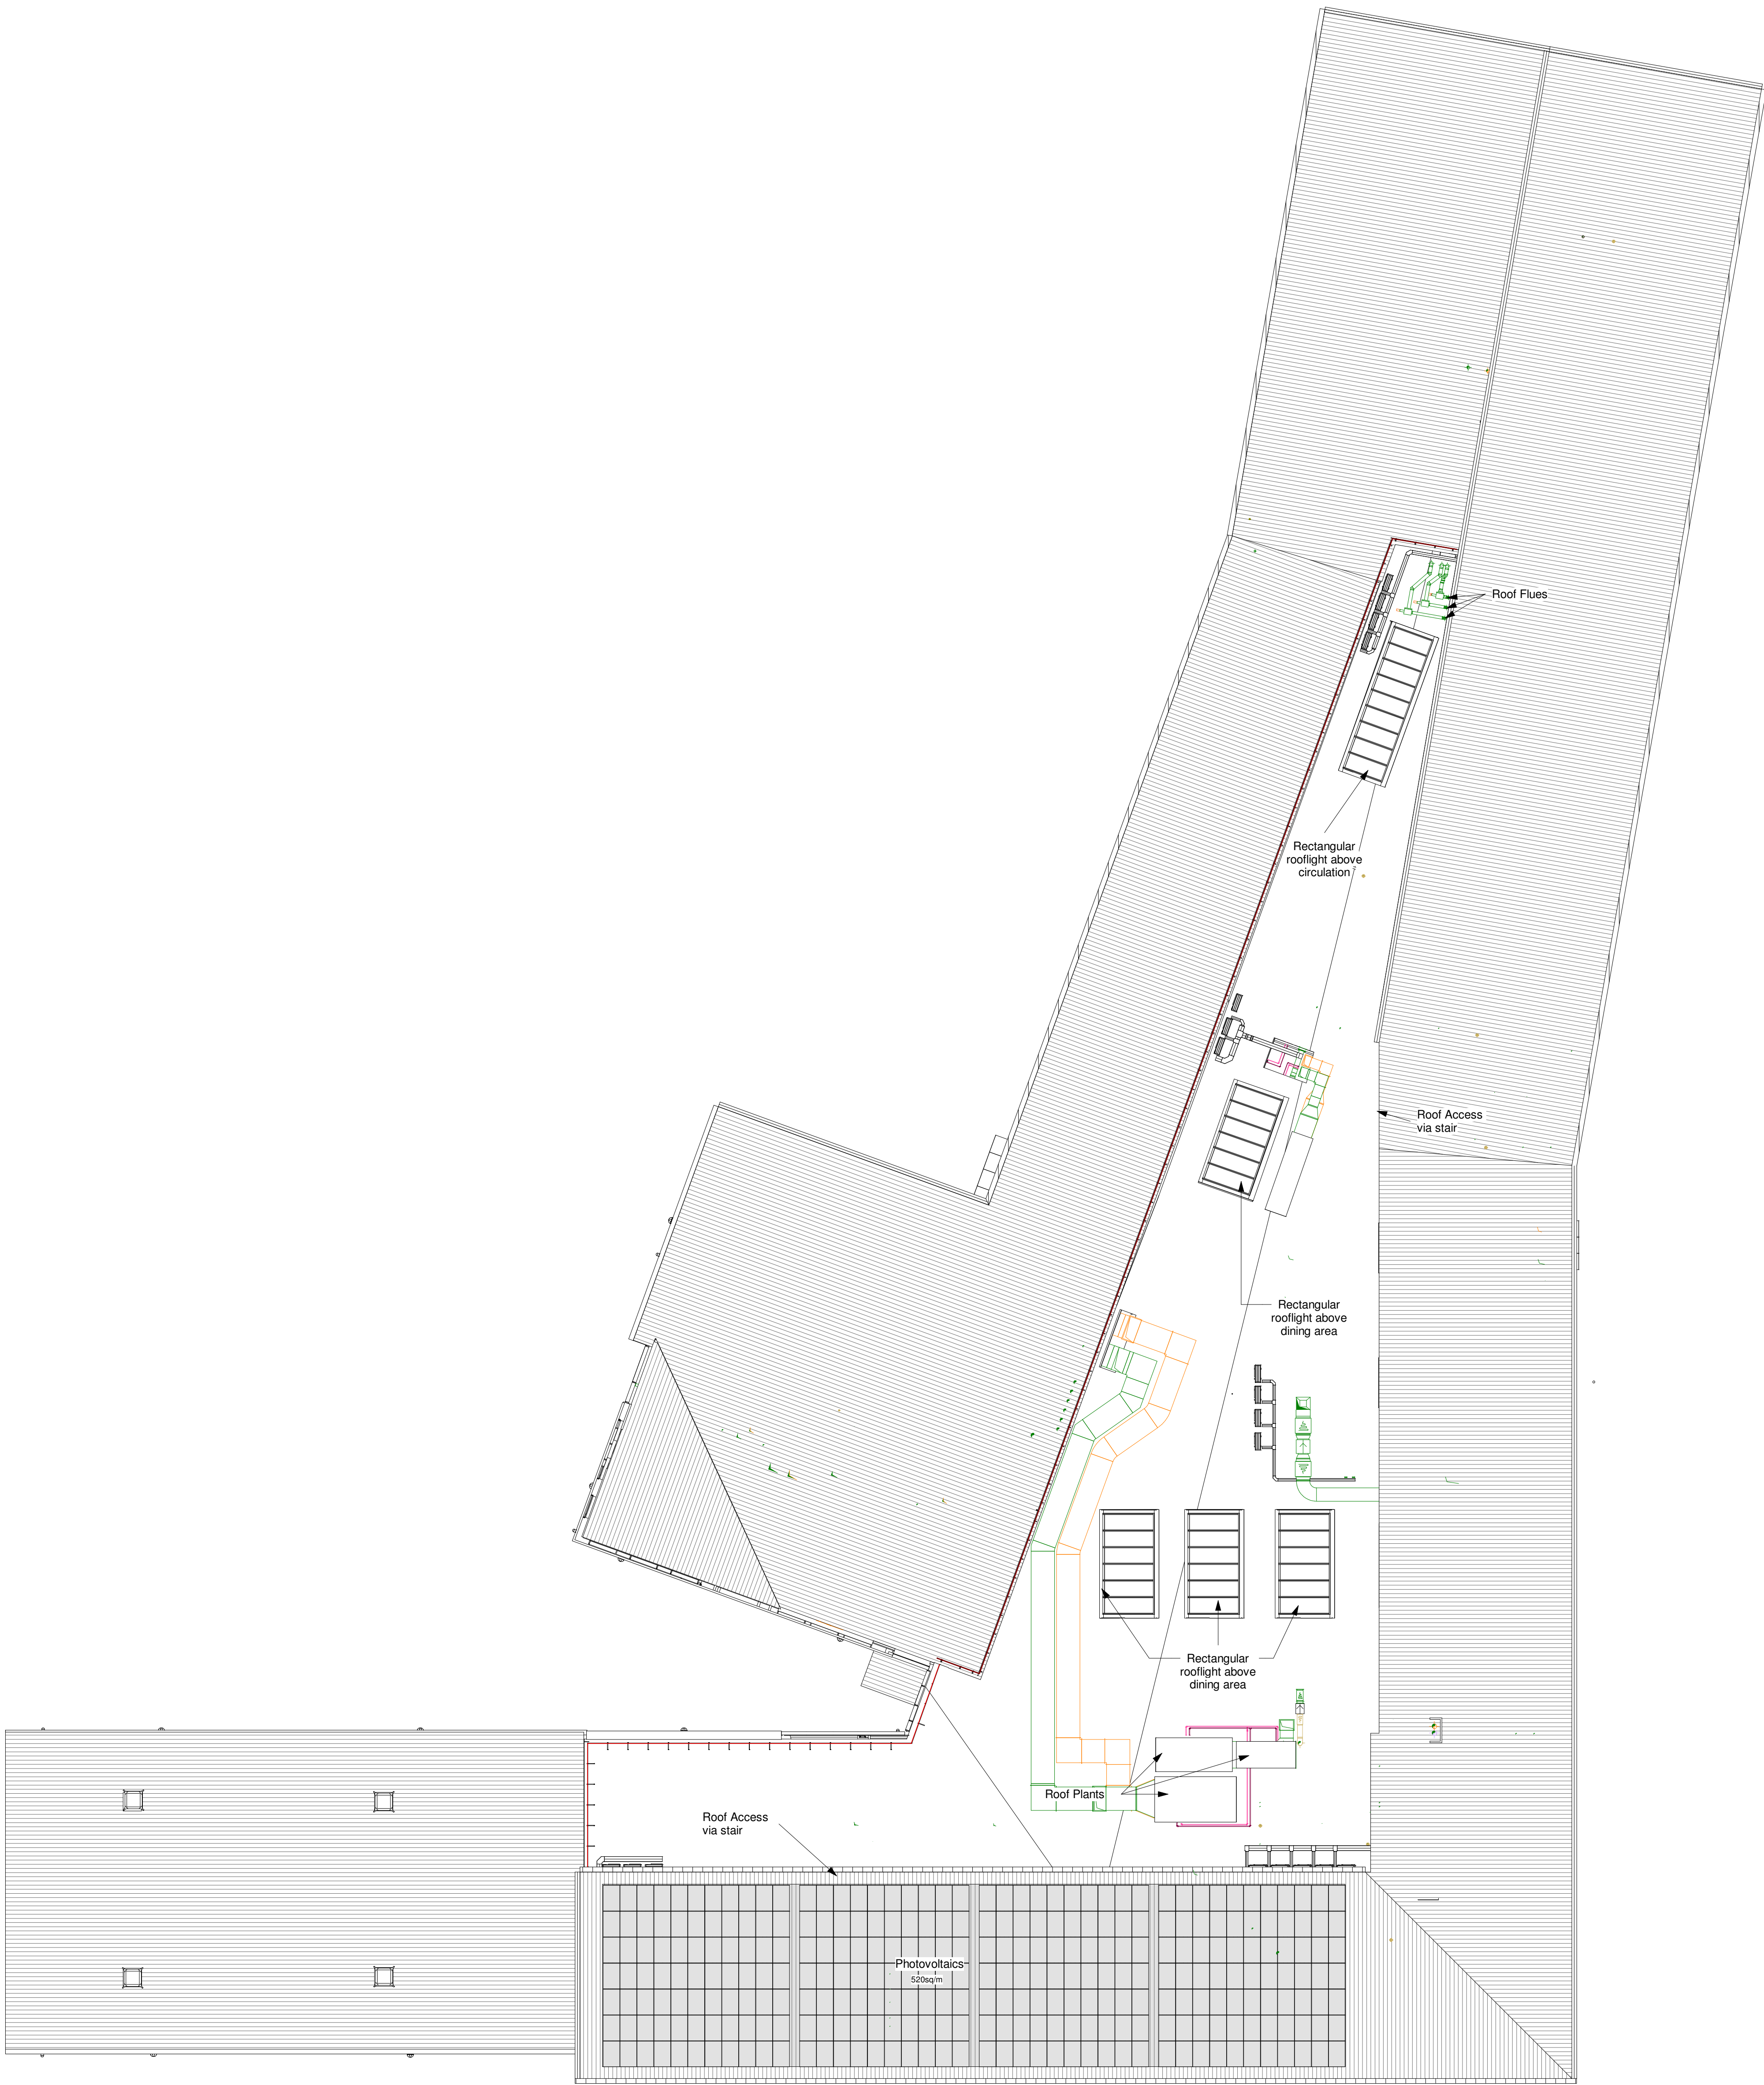

- Standing seam roof
- Anti Slip walkway
- Single ply membrane roof laid to falls
- Keeguard Foldshield or similar approved roof guarding
- Movement Joint
- Roof guard to standing seam roof
- Windcatcher

Note: Syphonic Drainage system outlet size and positions indicated indicatively only. System subject to specialist design.

General Note: MEP Roof plant omitted for clarity. Refer to MEP subcontractor drawings.



This drawing must not be scaled. Figured dimensions and levels to be used. Any inaccuracies must be notified to the architect. Detail drawings and large scale drawings take precedence over smaller drawings.

A1

Rev:	Planning Submission.	13/05/19	Chk'd:
P01	Roof Plants Shown	23/09/20	
C01			

STATUS

S2 - Issued for Information

powelldobson
ARCHITECTS

Cardiff · Swansea · London t +44 (0)33 33 201 001 www.powelldobson.com @PDArchitects

PDA Job No: 18080	
26W007 - PDA - 00 - RF- DR - A - 05 - 0007	REV C01
UPRN	ORIGINATOR
VOLUME	LEVEL
TYPE	ROLE
CLASS	NUMBER

Contract: Neath Port Talbot County Borough Council
Cefn Saeson School
Title: Planning Roof Plan

Scale: As indicated
Date: 31/01/2019
Drawn: ARB
Checked: AD