


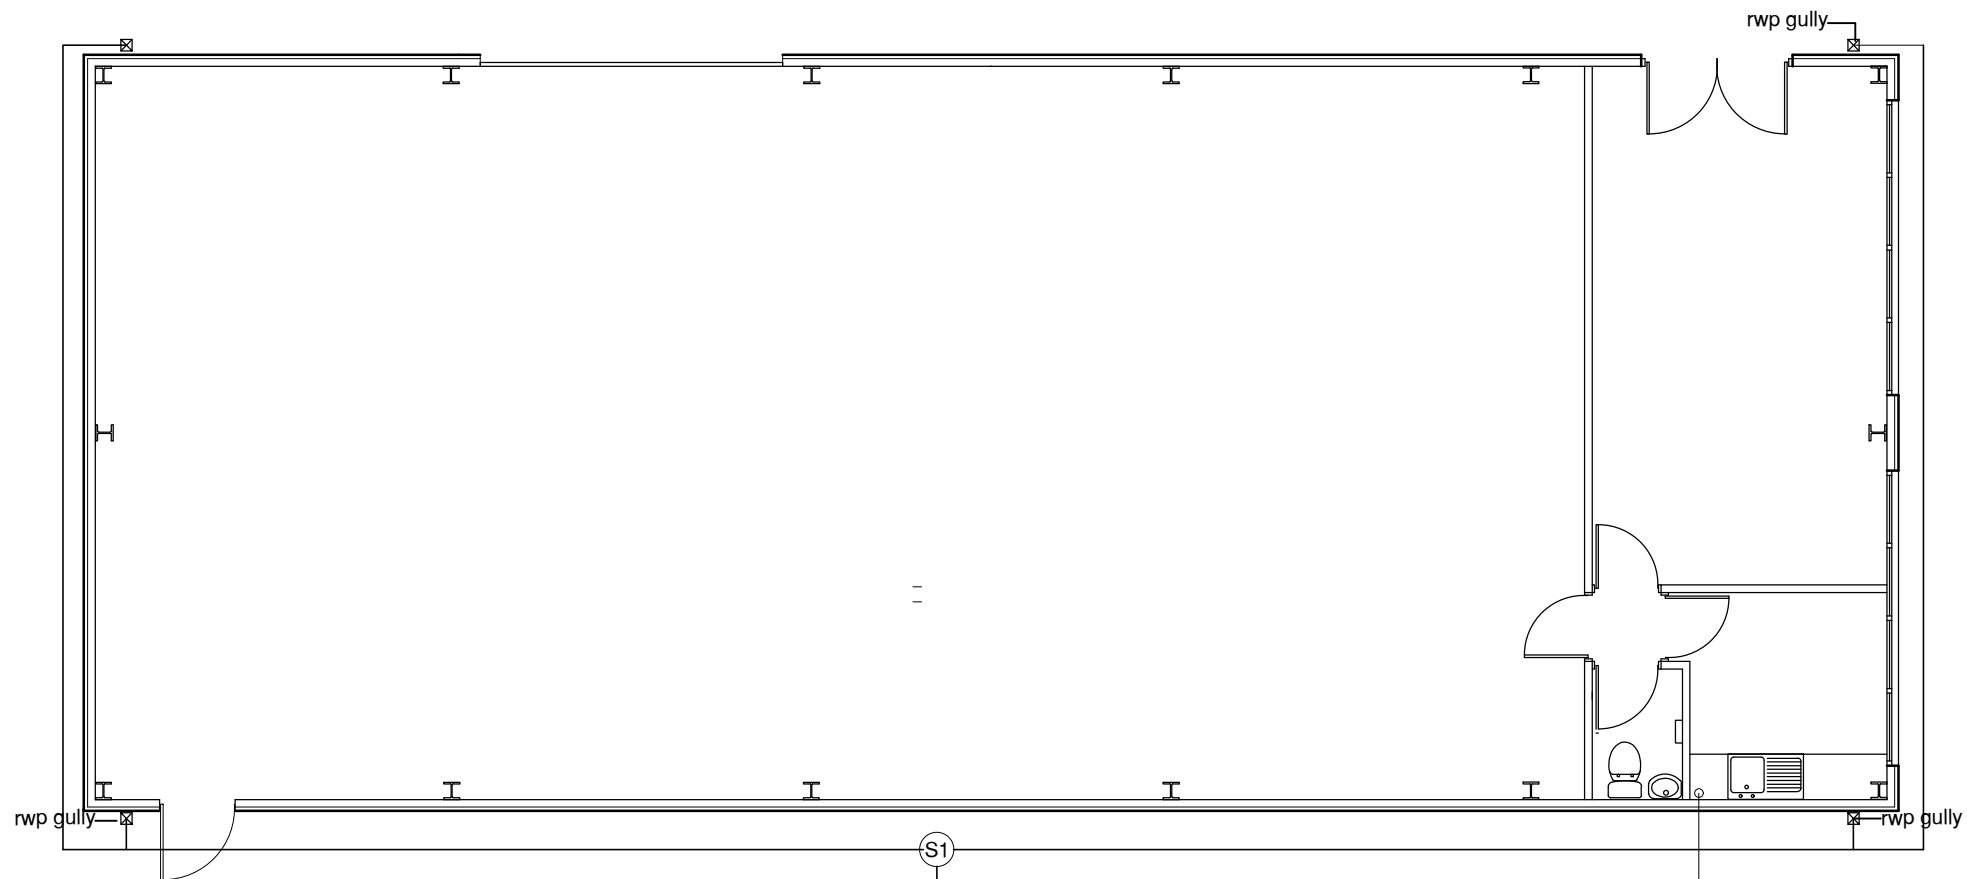

S1
to existing stormwater
connection

F1
to existing foul connection in
service road

THIS DRAWING IS COPYRIGHT ©

Ken Bateman
Chartered Surveyor
B.Sc. (Hons.) MRICS, C. Bus. & Mgmt.

Appin Fairview Chwyd y Ffager Morthyr Tydfil
CF48 1HW

project
Proposed Industrial Building
at
Unit 25a
Edwards Works
Llandarcy
Neath
SA10 6JY

title
Drainage Layout

Date: Jan 2021
Scale: A3@ 1:50
Drawn:

Drawing No.	Rev.
GA 003	