


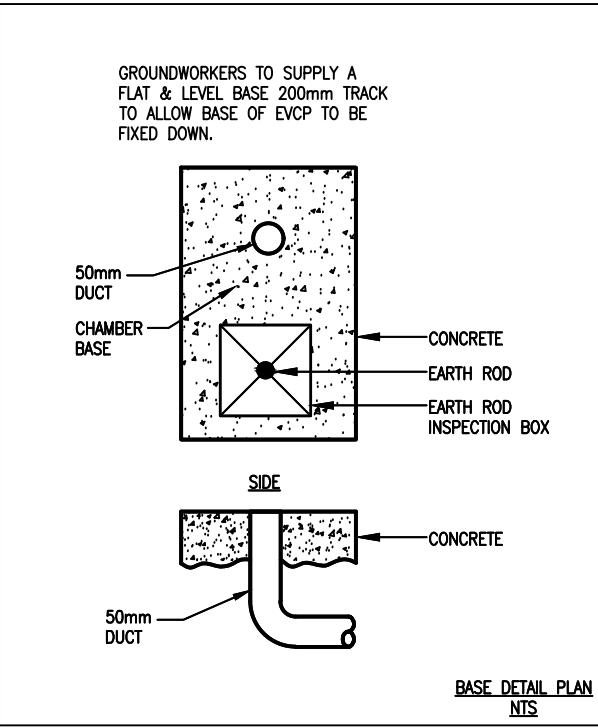
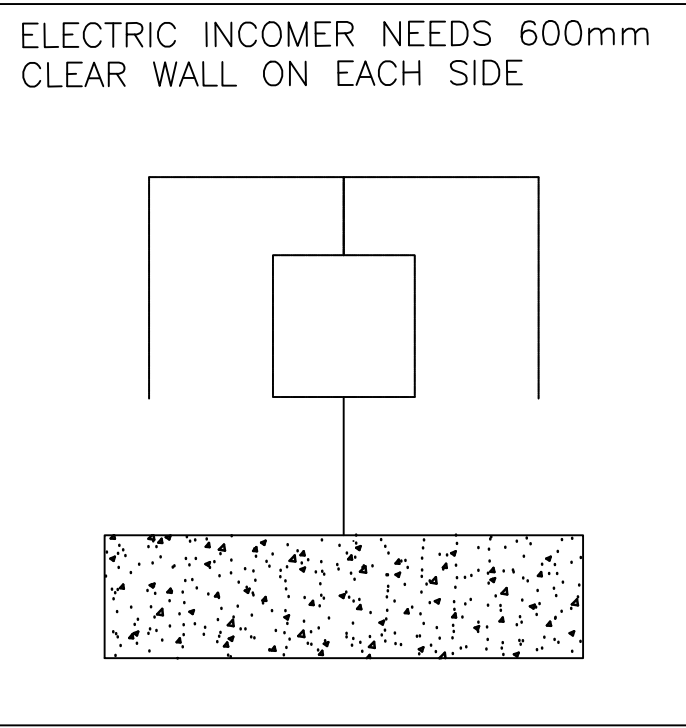
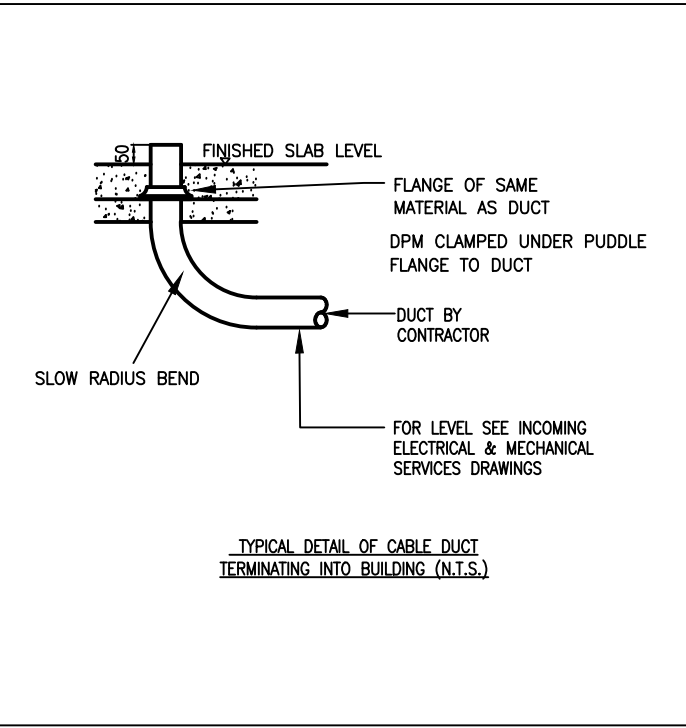
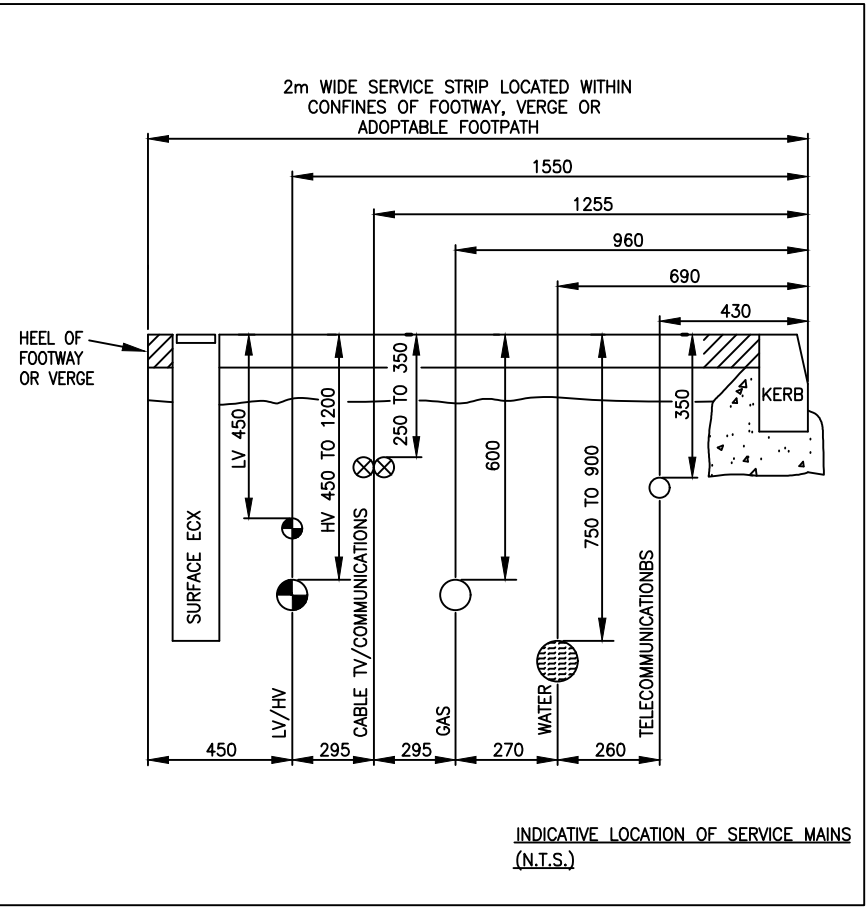


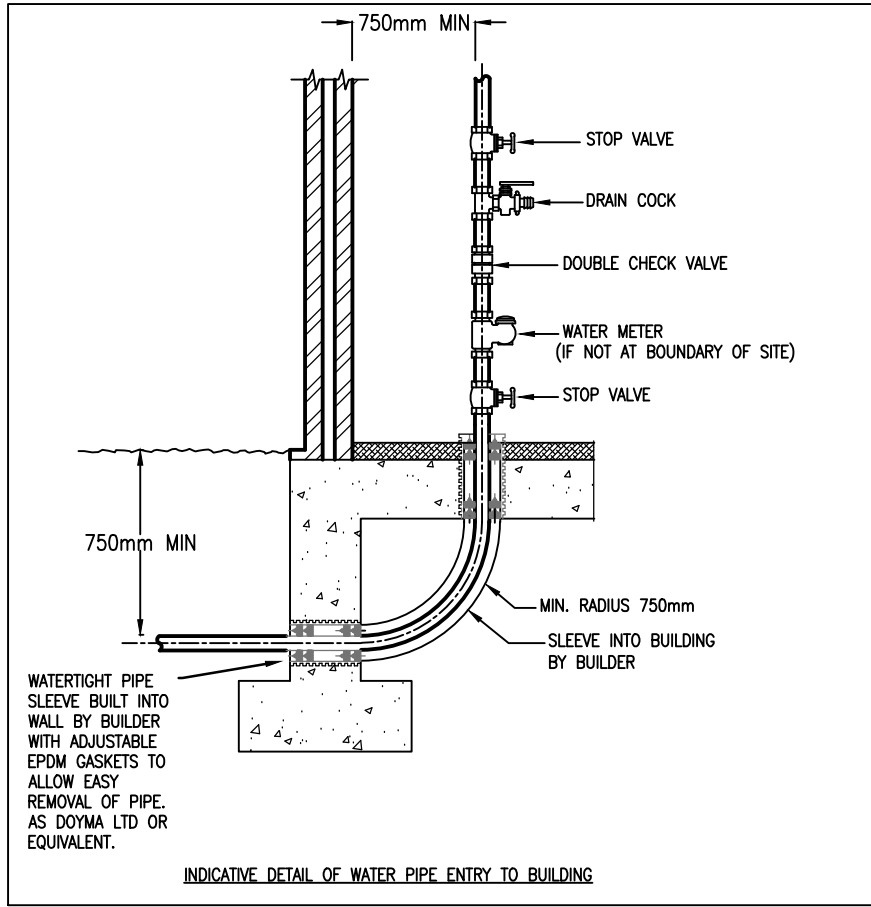

LUMINAIRE SCHEDULE				
Symbol	Label	Qty	Catalog Number	Description
	2FW9	3	FTS.094.FW mounted on 6m columns	FTS Luminaire - 10488 LUMENS
	FW9	0	FTS1.L094.FW mounted on 6m columns	FTSLuminaire - 10488 LUMENS
	A	7	FTS .L094FW BLS mounted on 6m columns c/w back shield	FACTOR SMALL WITH BLS
ALL LIGHTING COLUMNS 6m TALL				

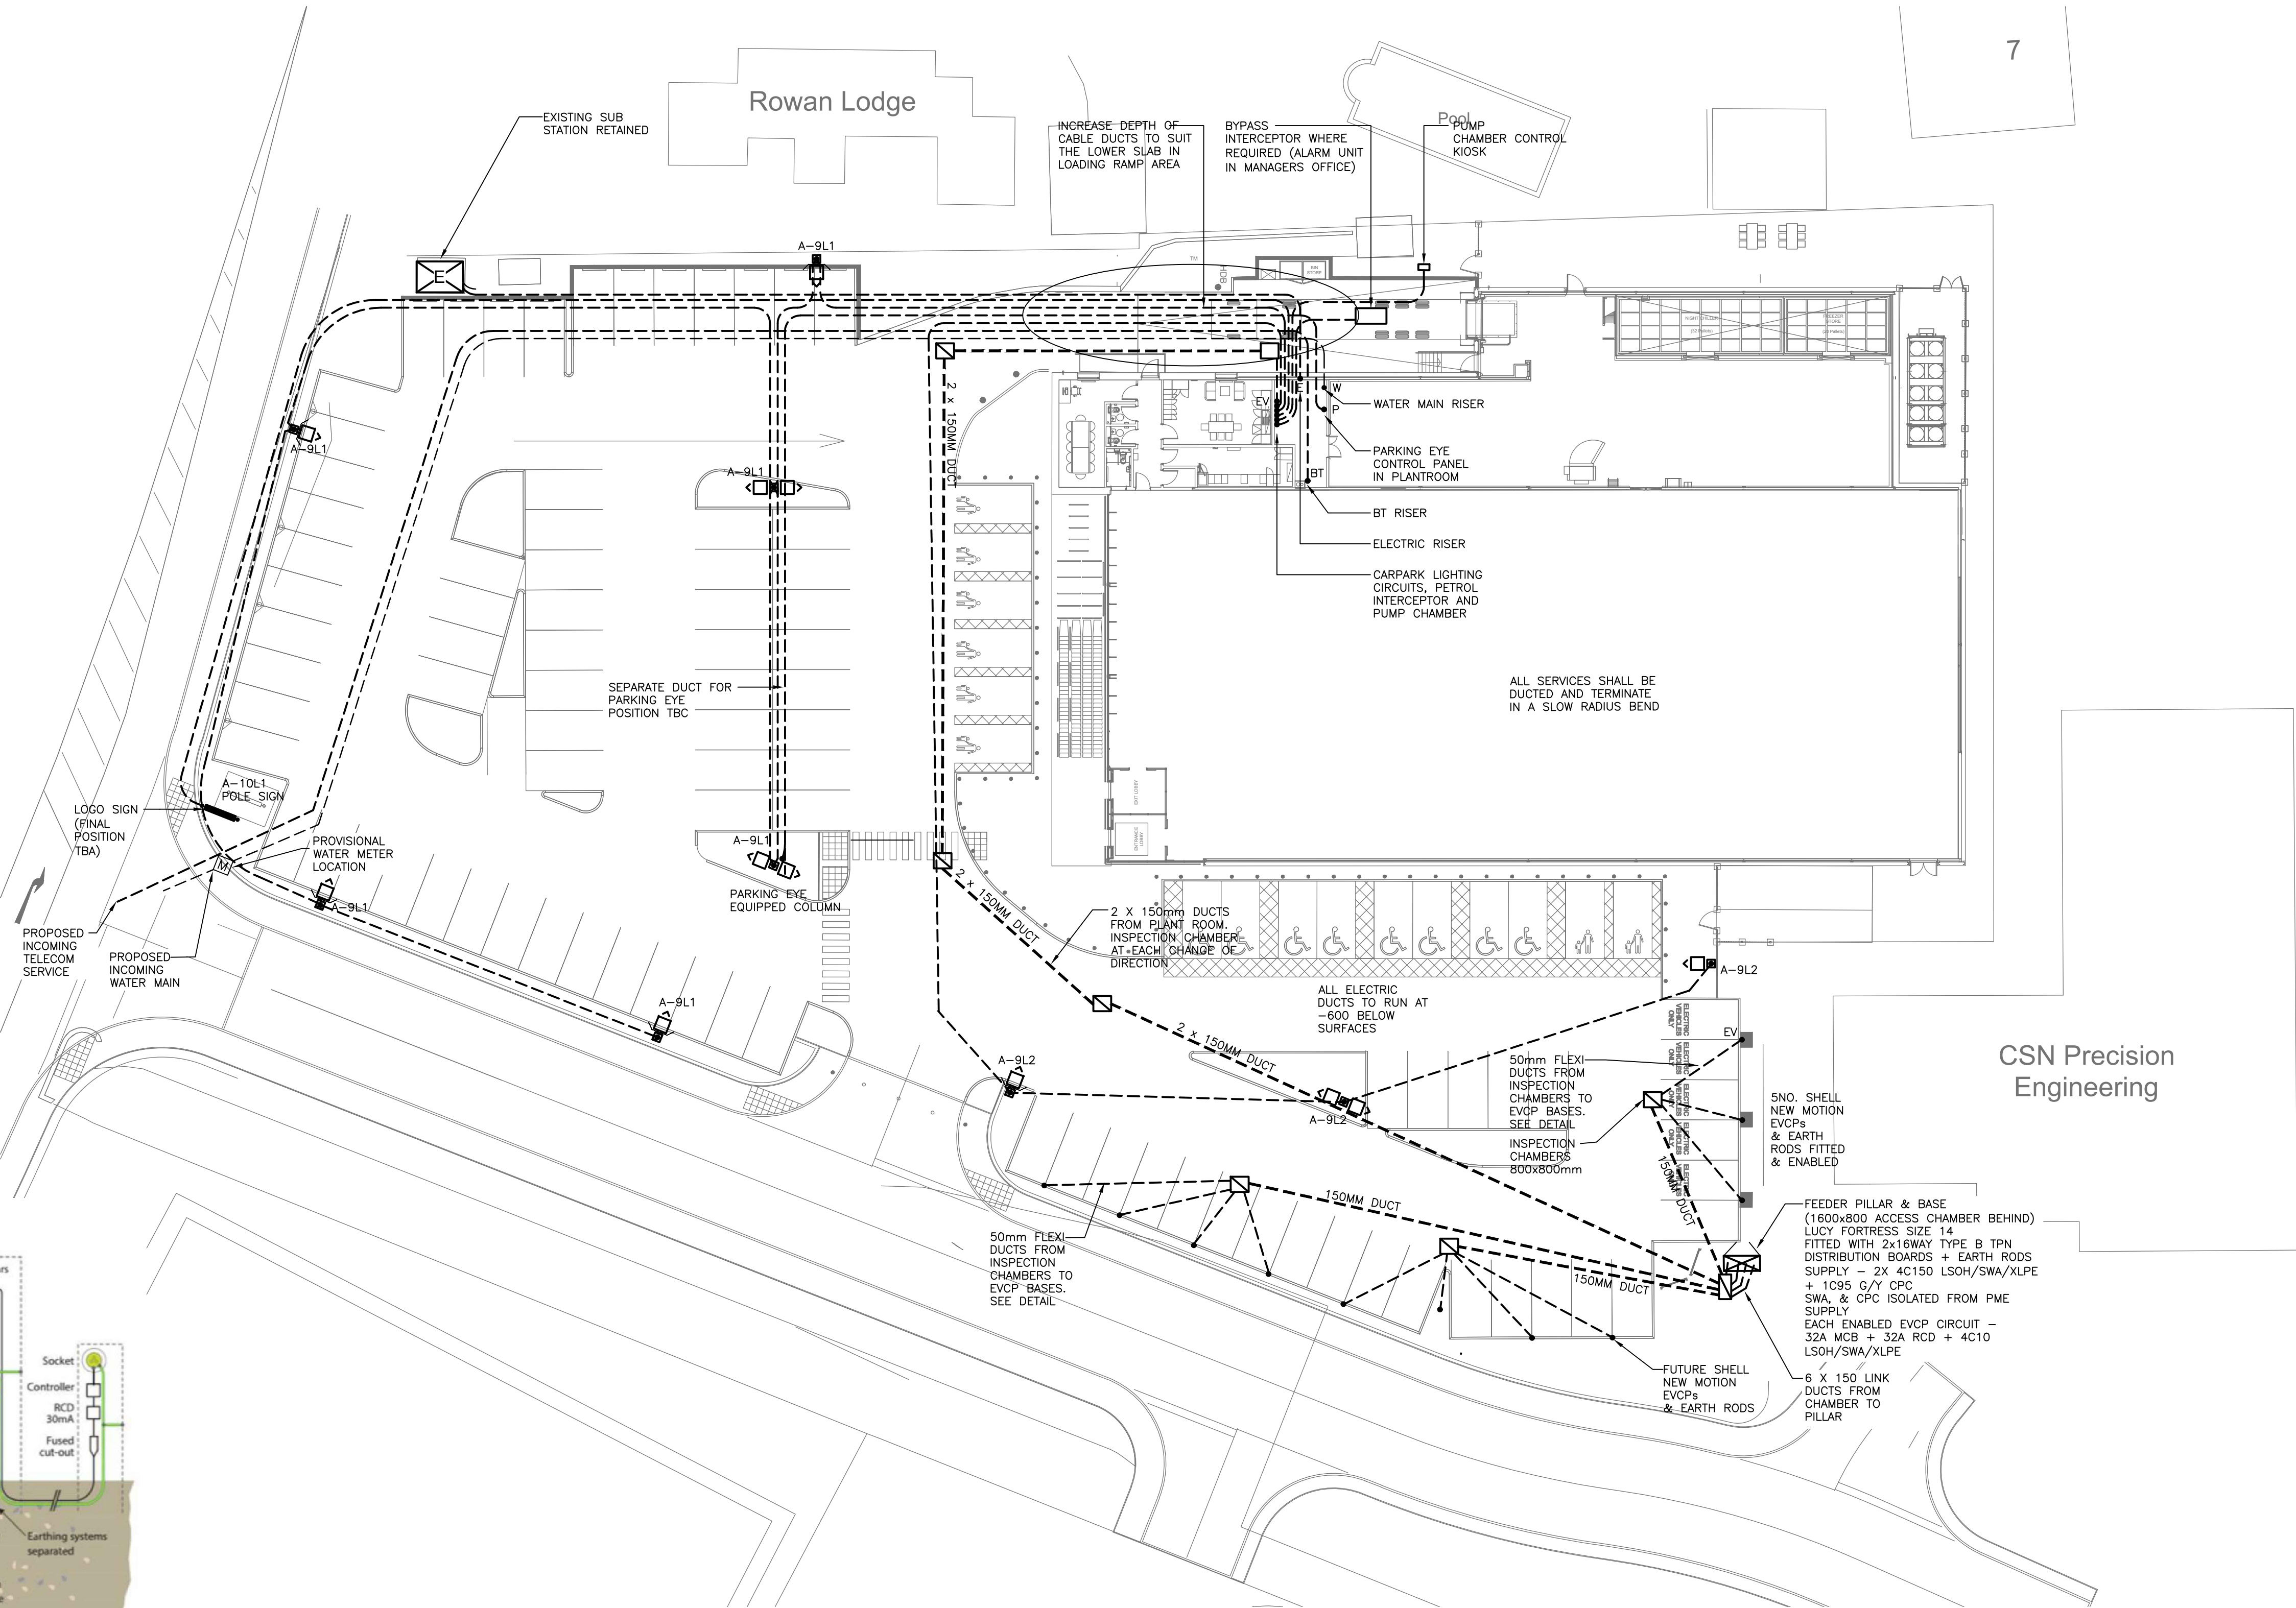

- NOTE
1. ALL TRENCHING AND DUCT LAYING BY G.C.
 2. TELECOM DUCT FREE ISSUE FROM B.T. AND LAID AT 600 DEEP.
 3. LIGHTING CABLE 600 DEEP (750 AND DUCTED UNDER ROAD) WITH WARNING TAPES.
 4. ELECTRICITY MAINS 600 DEEP WITH WARNING TAPES.
 5. OBTAIN 90mm GREY OPENREACH DUCTING FROM LOCAL OPENREACH DEPOT.
 6. OPENREACH DUCTING INSTALLATION, ENTRIES TO BUILDING ETC SHALL MEET THE REQUIREMENTS OF OPENREACH STANDARDS.
 7. ALL LIGHTING/POWER/CONTROL CABLING SHALL BE DRAWN INTO PVC DUCTING @ MIN 600 DEPTH WITH WARNING TAPE.
 8. DRAW PITS TO BE PROVIDED AT ALL CHANGE OF DIRECTION AND MAX 30 METER SPACINGS. MIN SIZE 600 x 600
 9. ALSO REFER TO UTILITY SUPPLIER RECORD DRAWINGS AND PROPOSALS FOR DIVERSIONS AND NEW SUPPLIES.

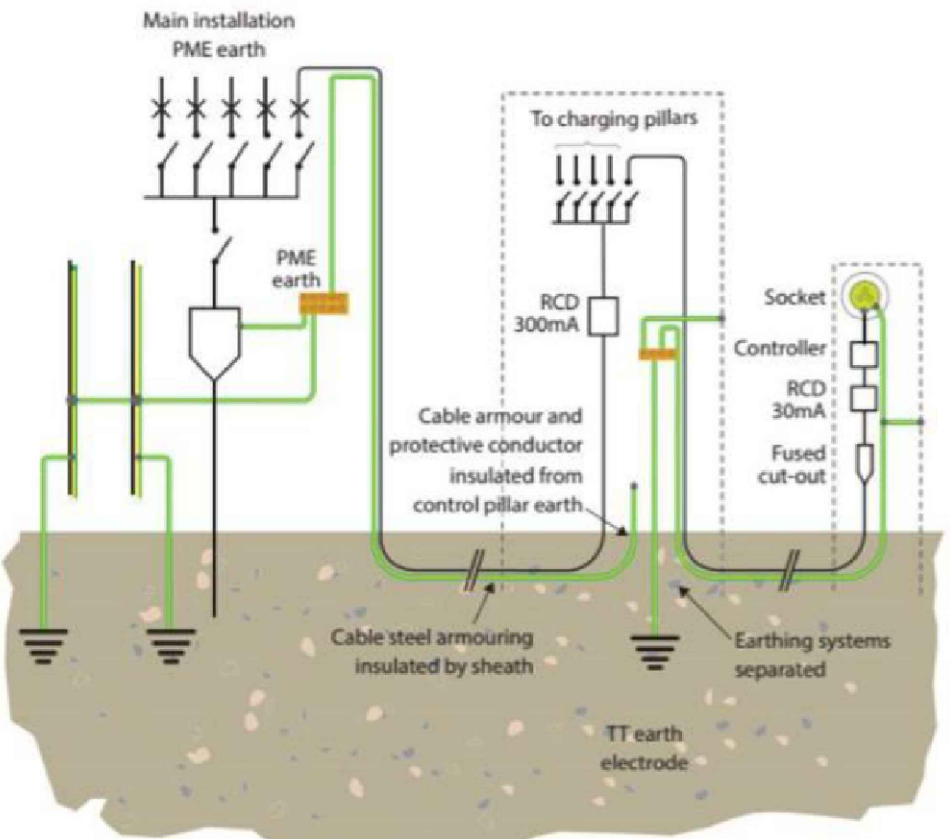

General Arrangement (FEEDER PILLAR)

B	14.05.20	JC LC	ELECTRIC VEHICLE CHARGING & LIGHTING REVISED
A	31.03.20	MG	FIRST ISSUE
Issue	Date	By	Description

BMT BUILDING MANAGEMENT TECHNOLOGY

Unit 2 Forest Business Park
Oswin Road
Leicester
LE3 1HR

Tel: (0166) 244 0331
E-Mail: <firstname.surname>@bmt-ltd.co.uk

Client:

ALDI STORES LTD (CARDIFF)

Architect:

KENDALL KINGSCOTT LTD

Drawing Title:

**ALDI STORE ABBEY RD, NEATH
ELECTRICAL SERVICES
EXTERNAL SERVICES LAYOUT**

Drawing No:

B3590/E3

Scale:

1:250 @ A1

First Issue Date:

MAR 2020

Issue

B