

 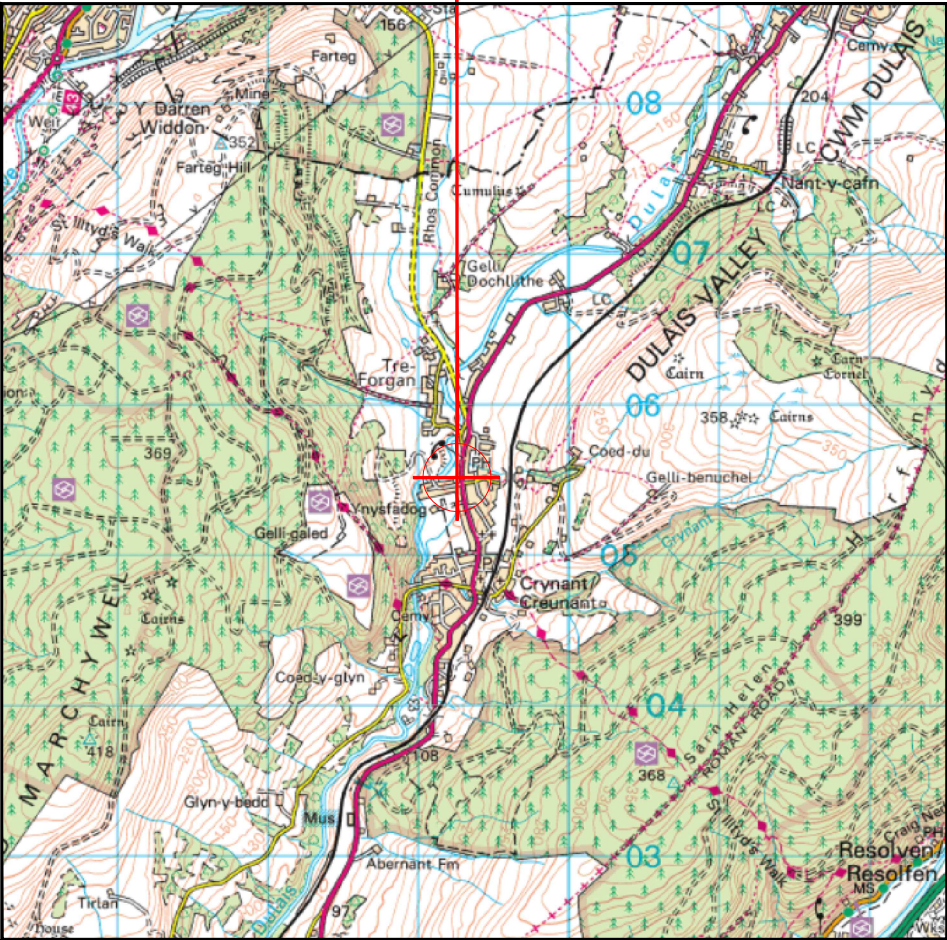


SITE LOCATION

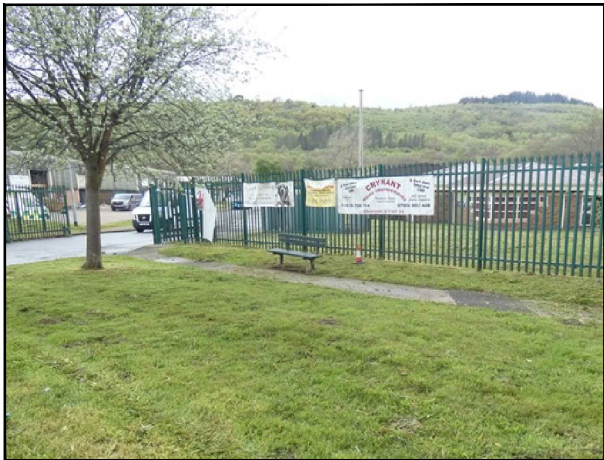


Reproduced by permission of Ordnance Survey on behalf of the Controller of Her Majesty's Stationery Office
All rights reserved. © Crown Copyright licence no. 100022432

SITE AREA PLAN




SITE PHOTOGRAPH

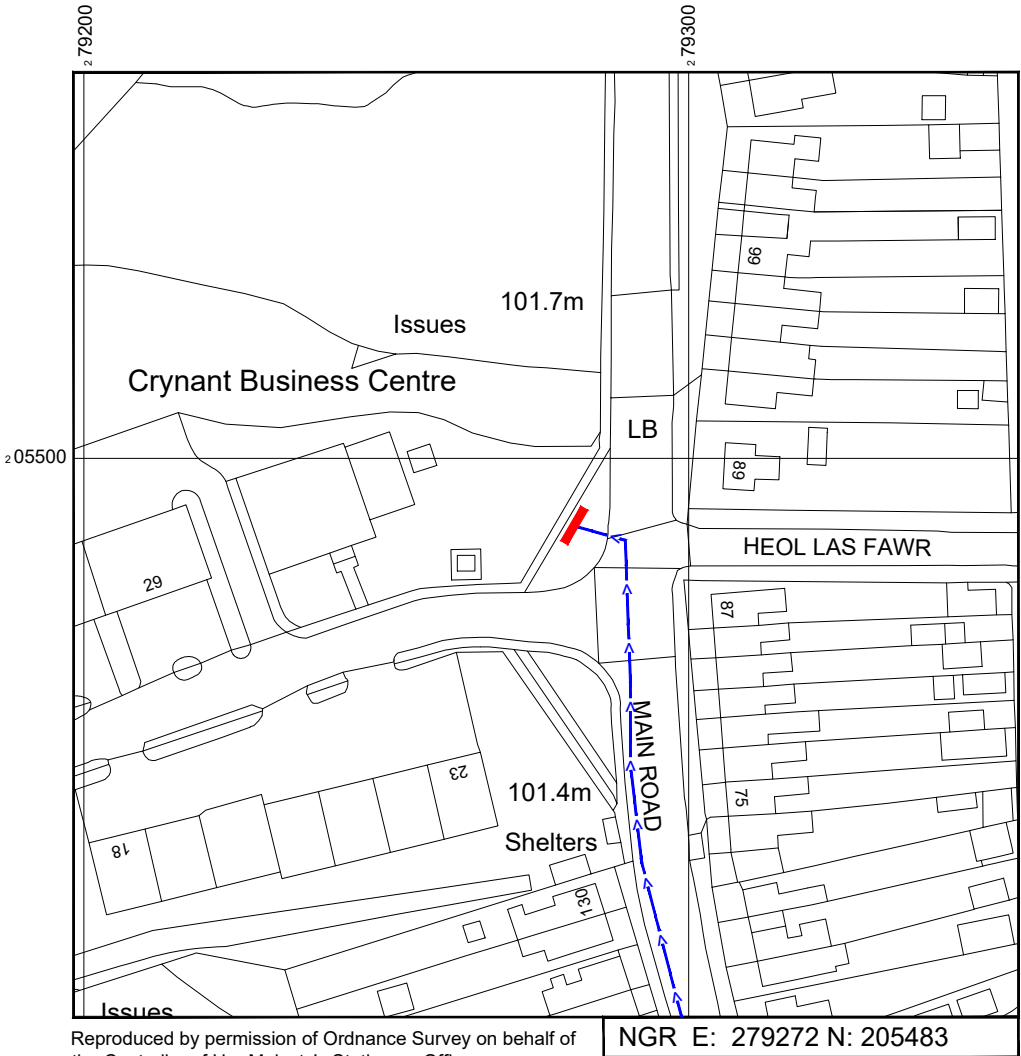

Reproduced by permission of Ordnance Survey on behalf of the Controller of Her Majesty's Stationery Office
All rights reserved. © Crown Copyright licence no. 100062043

 SITE LOCATION PLAN



GOOGLE MAPS QR CODE

GOOGLE MAPS - <https://goo.gl/maps/P5aLBoit8SAThAtU6>

GOOGLE STREETVIEW - <https://goo.gl/maps/QDGy8enEpwLuDbh68>

NOTES:

1. ALL DIMENSIONS IN MM UNLESS OTHERWISE NOTED.

DIRECTIONS TO SITE:

Head northwest on M4. At junction 43, take the A465 exit to Neath/CastellNedd/Merthyr Tydl. At Llandarcy Interchange, take the 1st exit onto B4290. Turn right onto Darcy Business Park. Turn right toward Pen-Y-Heol/B4290. Continue onto Pen-Y-Heol/B4290. Turn right onto New Rd/A4230. At the roundabout, take the 2nd exit and stay on New Rd/A4230. At the roundabout, take the 2nd exit onto A474. At the roundabout, take the 1st exit onto the A465 ramp to Merthyr Tydl/Merthyr Tydful/Merthyr. Merge onto A465. Take the A4109 exit toward Seven Sisters/Blaendulais/Tonna/B4434. At the roundabout, take the 3rd exit onto Main Rd/A4109. Follow Main Rd and site location is on the left hand side.

Site Provider's
Property Boundary:



Access Route To Site:



Access Route:



Master:	MBNL / EE:	Project:	Purpose of Issue:	Issue:
M001	MBNL	5G UNILATERAL	Planning	A
Date:	15/08/2021	Revision / Upgrade Description:		
Drawn:	CDN	First Issue - Site nomination dated: TBC		
Checked:	DH			
Approved:	SD			

CK Hutchison
Networks (UK)
Limited

Great Brighams Mead,
Vastern Road, Reading,
Berkshire, England,
RG1 8DJ

Design Consultant & Principal Contractor:



WHP Telecoms

Unit 1 Maple Park,
Low Fields Avenue, Leeds
LS12 6HH

Tel: 01133023550
e-mail: info@whptelecoms.com

Site Name:
MAIN ROAD STREETWORKS

Site ID:
NPT17240

Address:
MAIN ROAD, TREFORGAN, CRYNANT,
NEATH PORT TALBOT, WALES,
SA10 8NY


Title:
002 SITE LOCATION PLAN

Project:
5G UNILATERAL

Purpose of Issue:
PLANNING

EE Cell ID:	MBNL Cell ID:	Cell ID:
N/A	N/A	N/A

Master Drawing No:	Issue:
NPT17240_M001	A

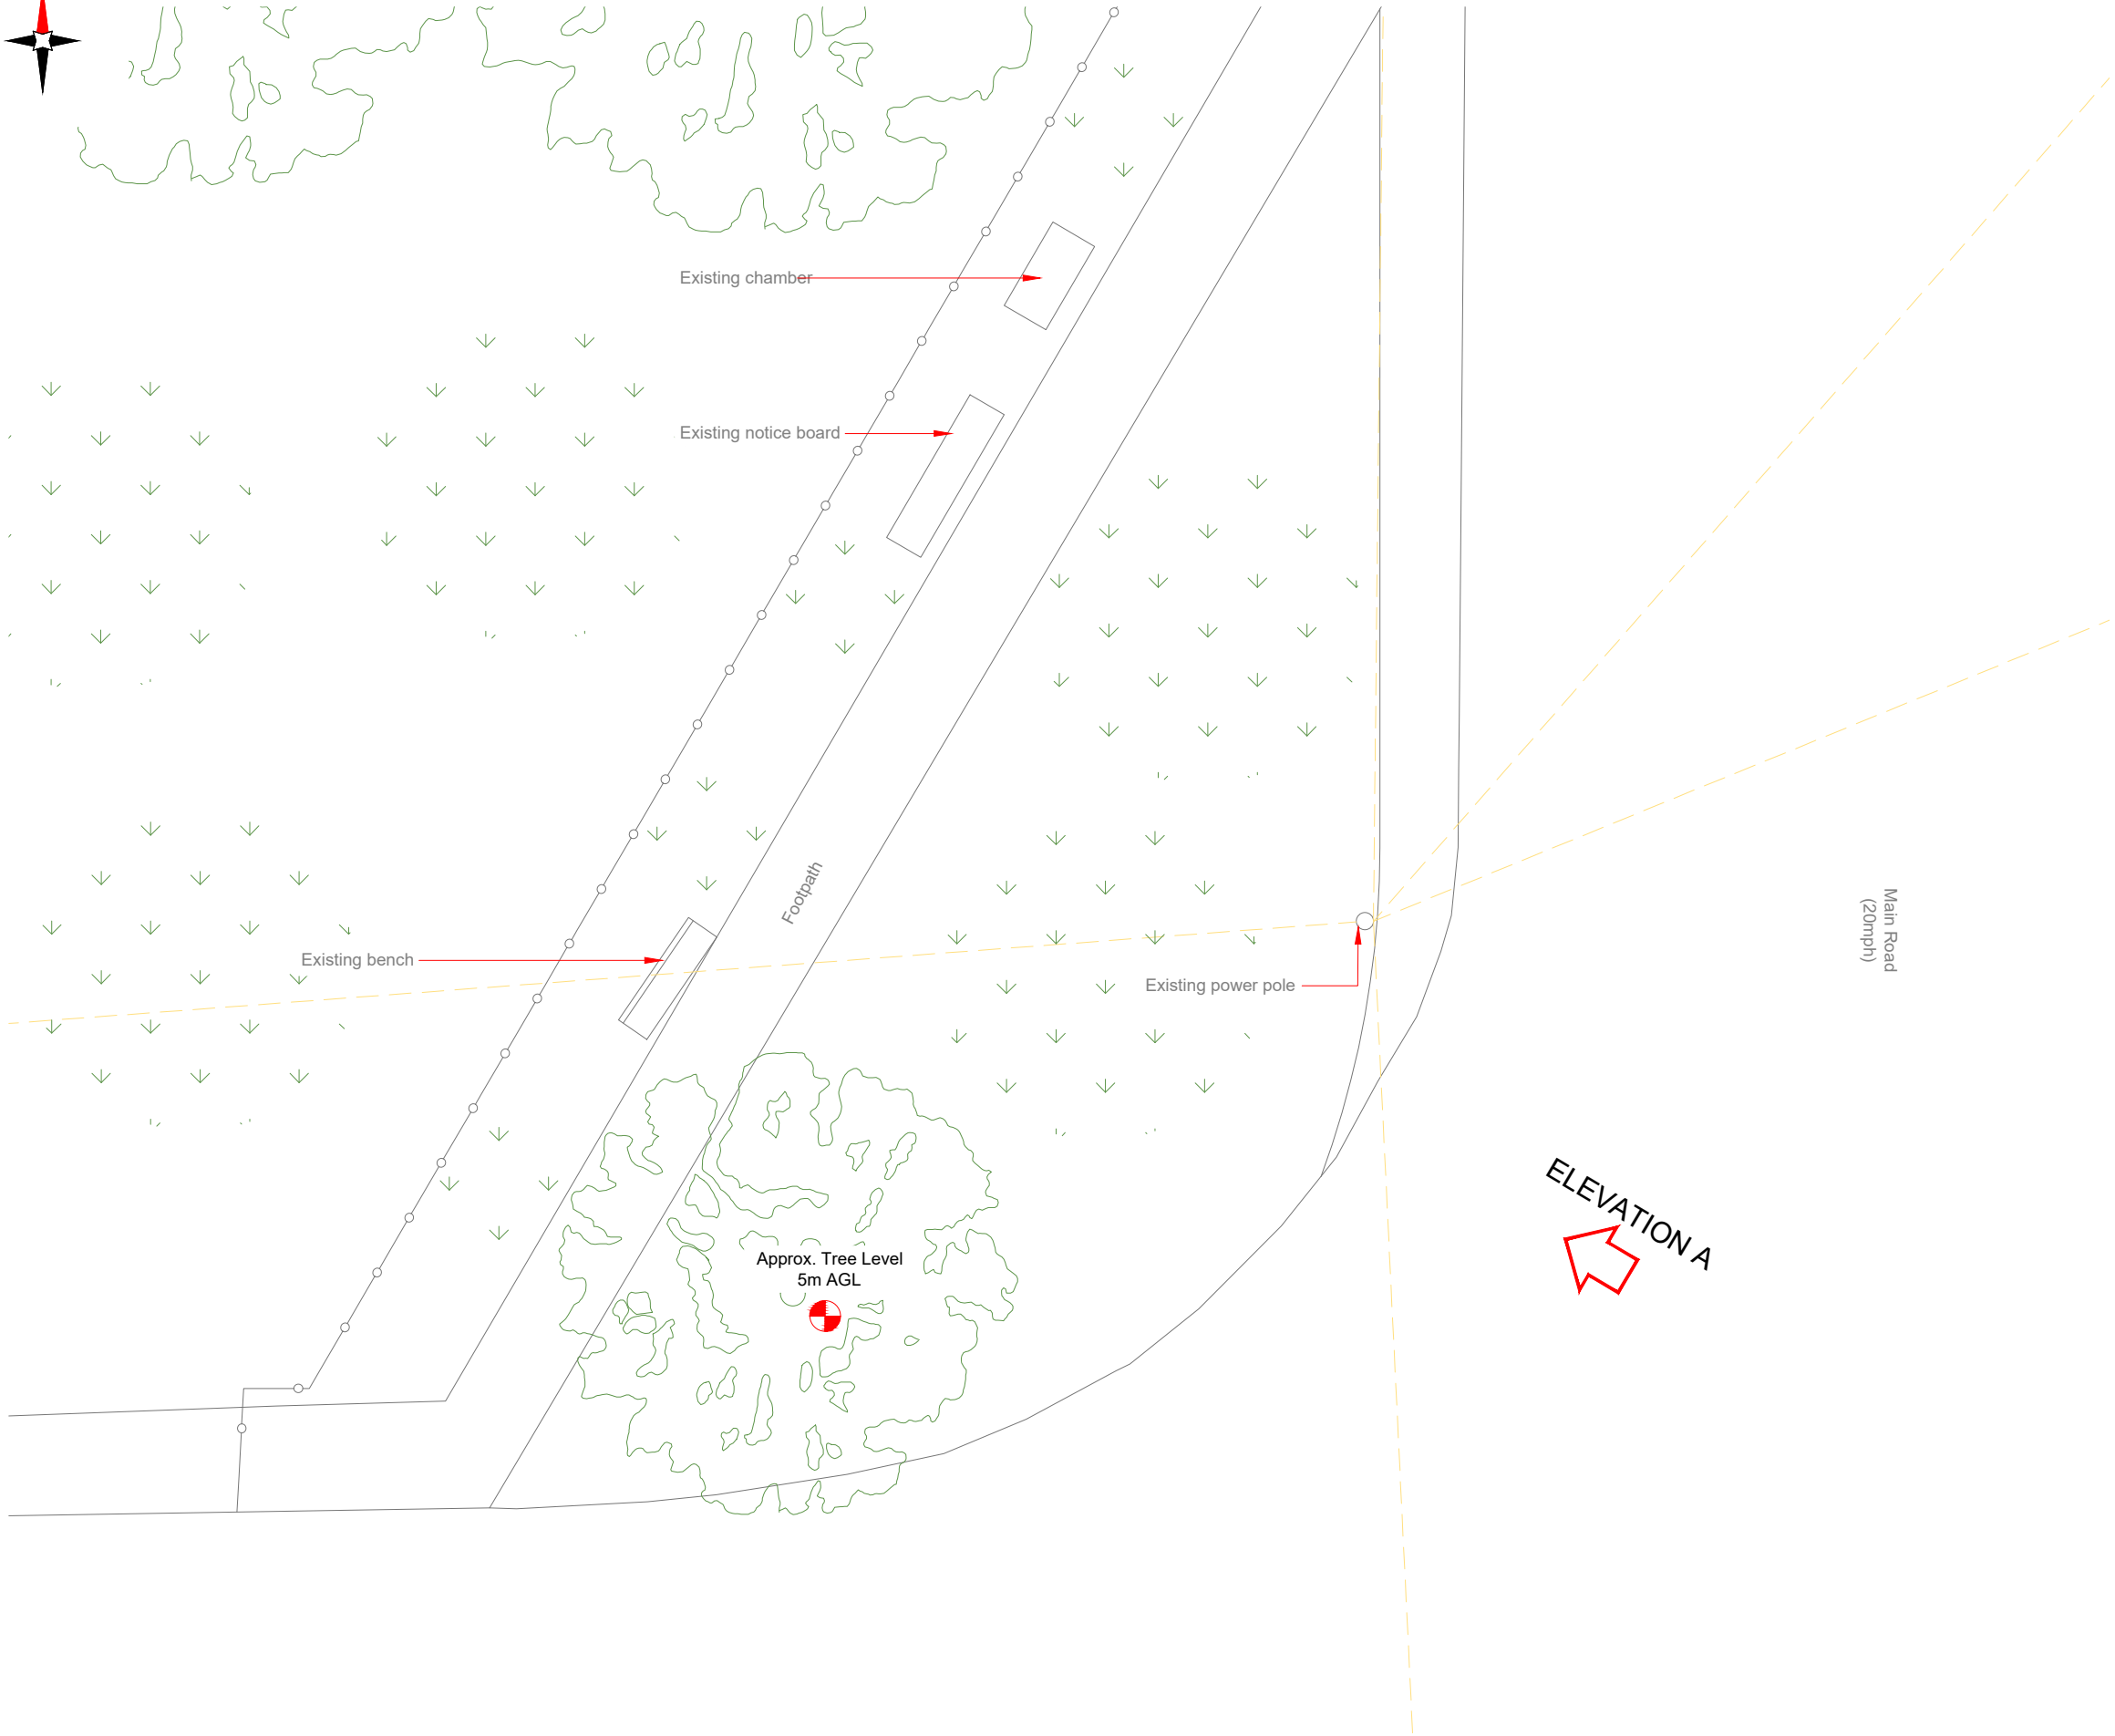


100mm

50mm

10mm

 EXISTING SITE PLAN



- NOTES:
- ALL DIMENSIONS IN MM UNLESS OTHERWISE NOTED.

Master:	MBNL / EE:	Project:	Purpose of Issue:	Issue:
M001	MBNL	5G UNILATERAL	Planning	A
Date:	15/08/2021	Revision / Upgrade Description:		
Drawn:	CDN	First Issue - Site nomination dated: TBC		
Checked:	DH			
Approved:	SD			

CK Hutchison
Networks (UK)
Limited

Great Brighams Mead,
Vastern Road, Reading,
Berkshire, England,
RG1 8DJ

Design Consultant & Principal Contractor:



WHP Telecoms

Unit 1 Maple Park,
Low Fields Avenue, Leeds
LS12 6HH

Tel: 01133023550
e-mail: info@whptelecoms.com

Site Name:
MAIN ROAD STREETWORKS

Site ID:
NPT17240

Address:
MAIN ROAD, TREFORGAN, CRYNANT,
NEATH PORT TALBOT, WALES,
SA10 8NY

Title:
100 EXISTING SITE PLAN

Project:
5G UNILATERAL


Purpose of Issue:
PLANNING

EE Cell ID:	MBNL Cell ID:	Cell ID:
N/A	N/A	N/A
Master Drawing No: NPT17240_M001		
Issue: A		


100mm

50mm

10mm

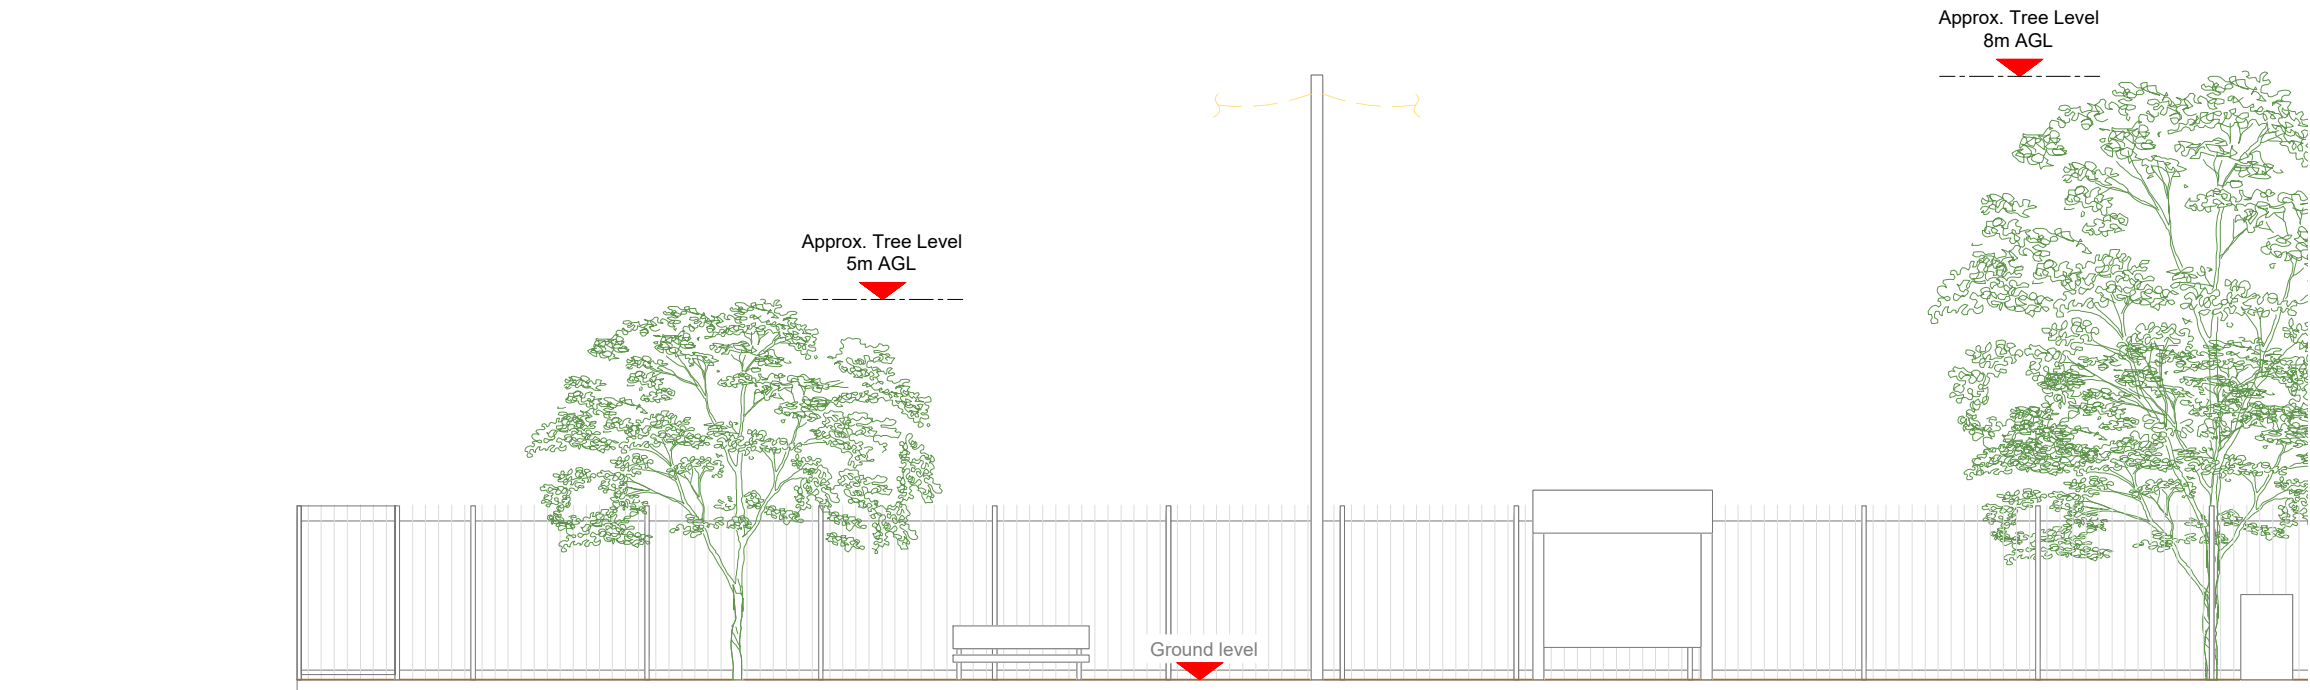

EXISTING ELEVATION A

 

- NOTES:
- ALL DIMENSIONS IN MM UNLESS OTHERWISE NOTED.

Master:	MBNL / EE:	Project:	Purpose of Issue:	Issue:
M001	MBNL	5G UNILATERAL	Planning	A
Date:	15/08/2021	Revision / Upgrade Description:		
Drawn:	CDN	First Issue - Site nomination dated: TBC		
Checked:	DH			
Approved:	SD			

CK Hutchison
Networks (UK)
Limited

Great Brighams Mead,
Vastern Road, Reading,
Berkshire, England,
RG1 8DJ

Design Consultant & Principal Contractor:



WHP Telecoms

Unit 1 Maple Park,
Low Fields Avenue, Leeds
LS12 6HH

Tel: 01133023550
e-mail: info@whptelecoms.com

Site Name:
MAIN ROAD STREETWORKS

Site ID:
NPT17240

Address:
MAIN ROAD, TREFORGAN, CRYNANT,
NEATH PORT TALBOT, WALES,
SA10 8NY


Title:
150 EXISTING ELEVATION A

Project:
5G UNILATERAL


Purpose of Issue:
PLANNING

EE Cell ID: N/A	MBNL Cell ID: N/A	Cell ID: N/A
--------------------	----------------------	-----------------

Master Drawing No: NPT17240_M001	Issue: A
-------------------------------------	-------------

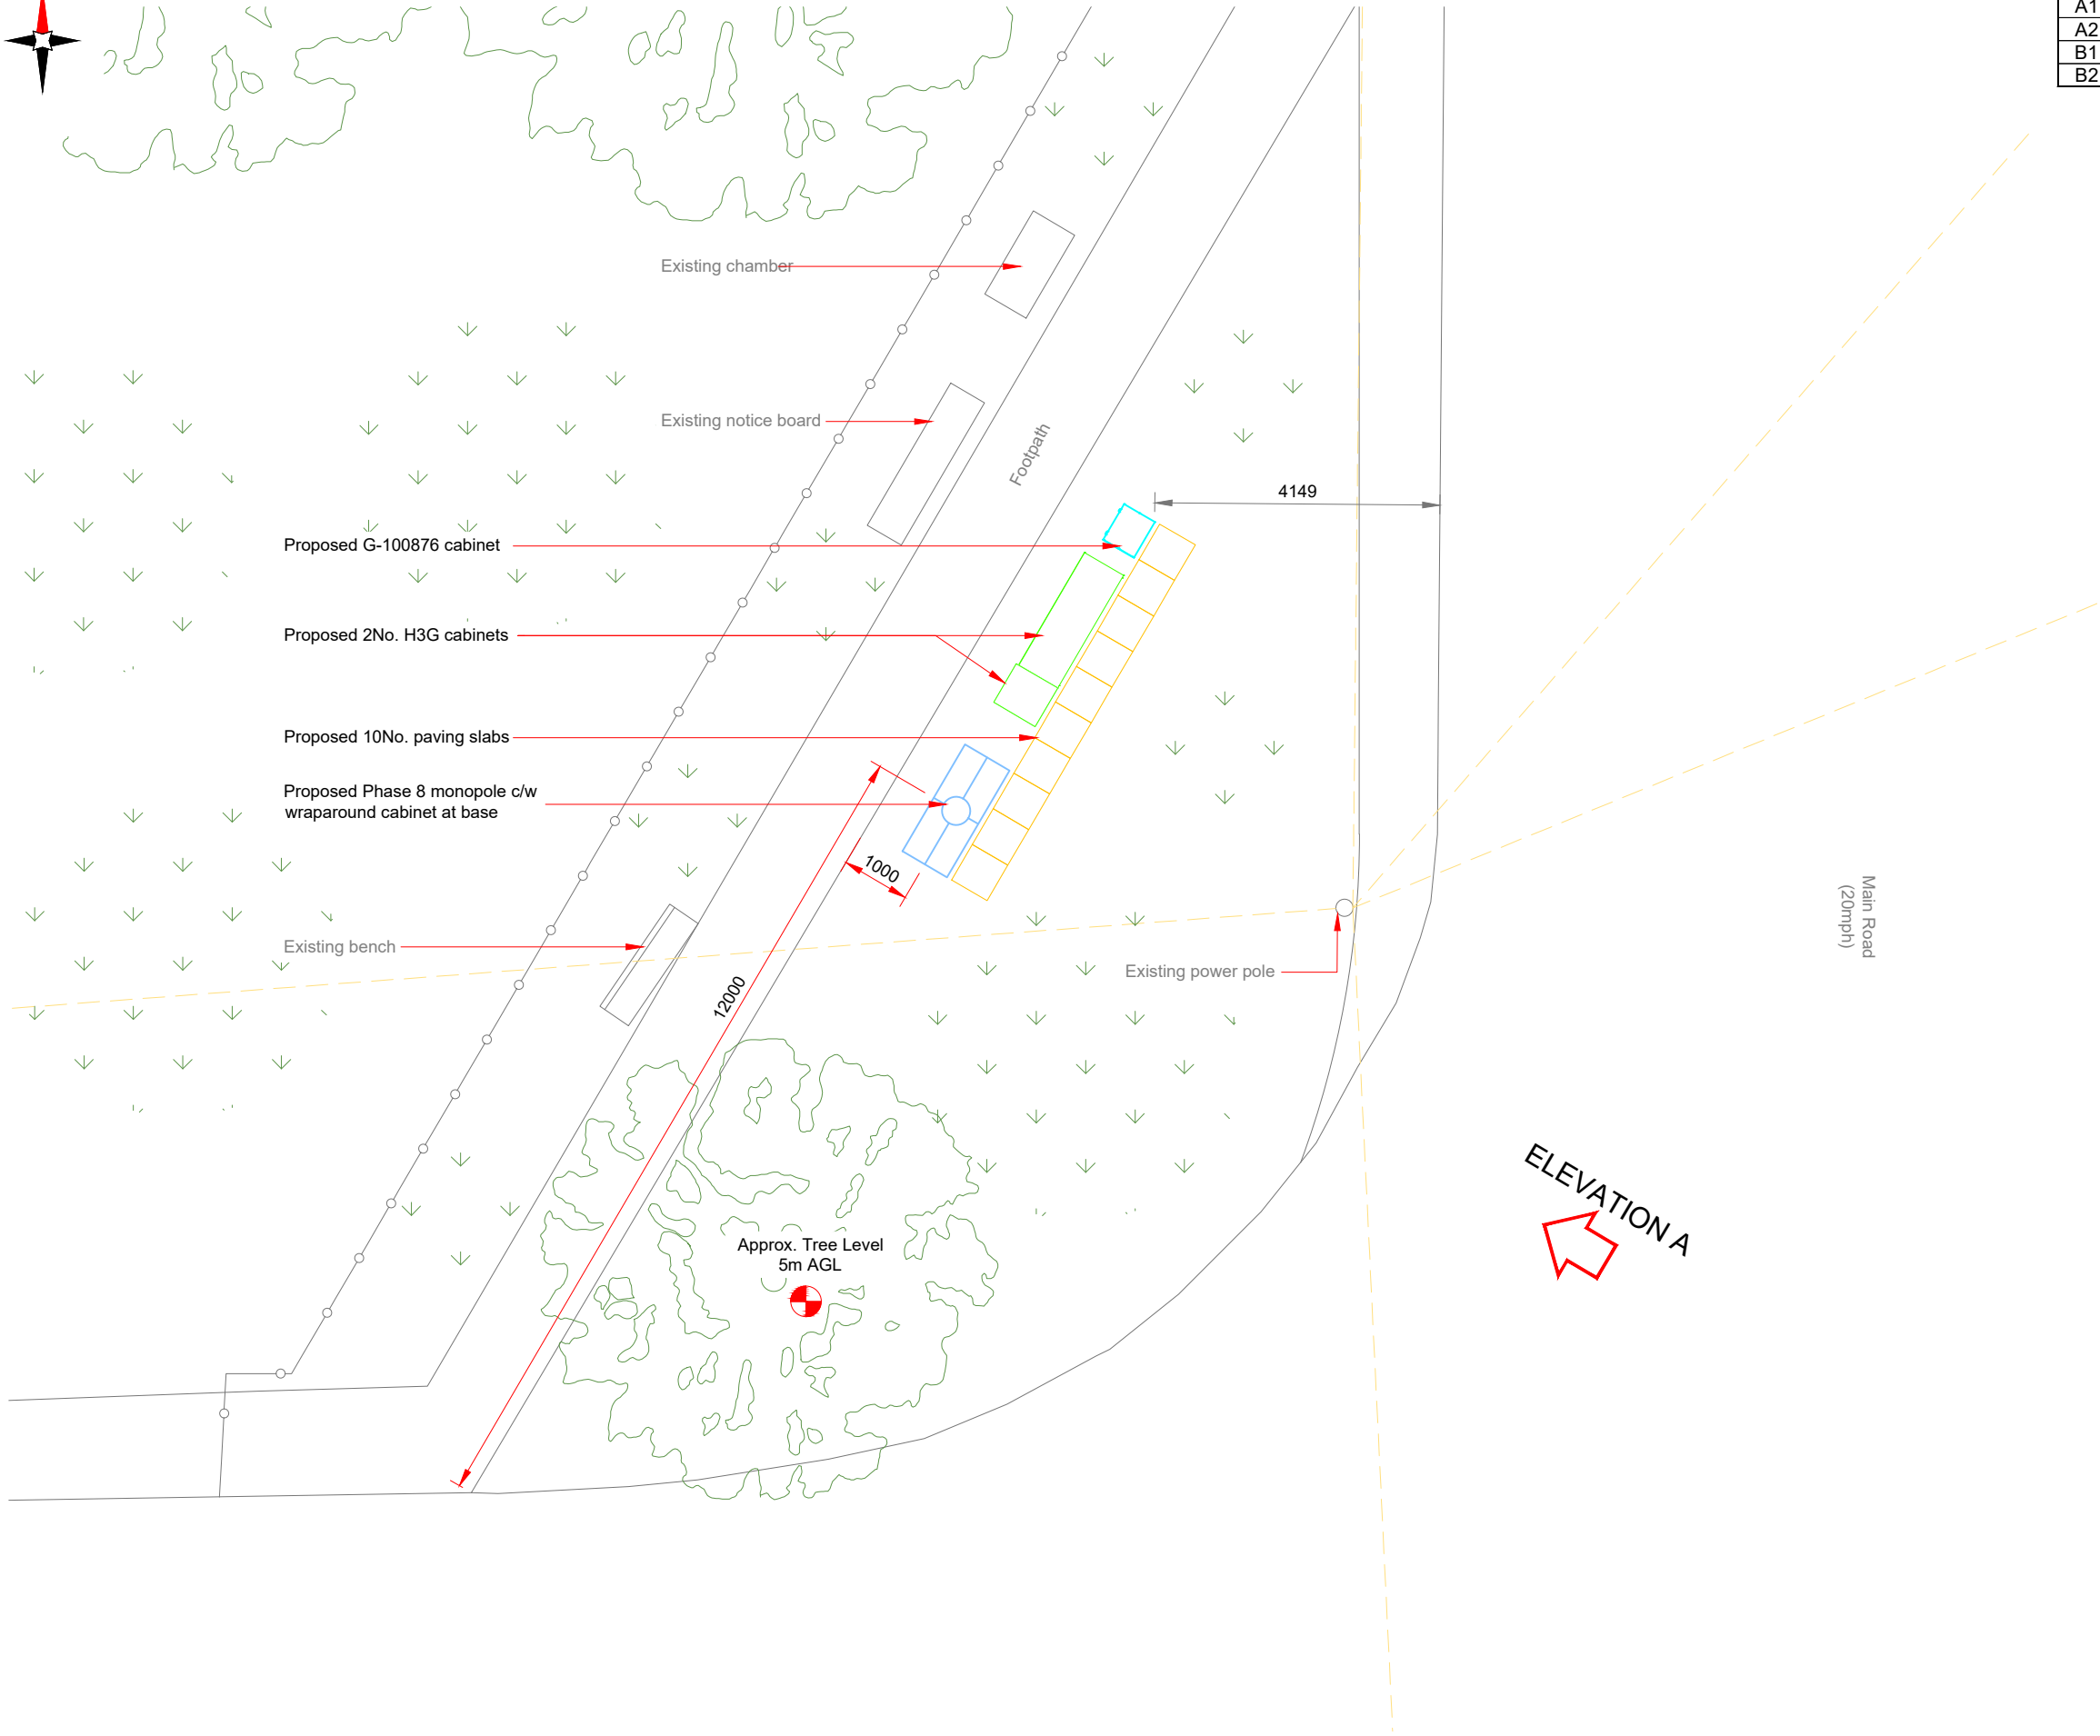

PROPOSED SITE PLAN

 

Antenna Aperture ID	Proposed 4G/5G Bearing
A1	20°
A2	20°
B1	185°
B2	185°

NOTES:
1. ALL DIMENSIONS IN MM UNLESS OTHERWISE NOTED.

Master:	MBNL / EE:	Project:	Purpose of Issue:	Issue:
M001	MBNL	5G UNILATERAL	Planning	A
Date:	15/08/2021	Revision / Upgrade Description:		
Drawn:	CDN	First Issue - Site nomination dated: TBC		
Checked:	DH			
Approved:	SD			

CK Hutchison Networks (UK) Limited

Great Brighams Mead,
Vastern Road, Reading,
Berkshire, England,
RG1 8DJ

Design Consultant & Principal Contractor:



WHP Telecoms
Unit 1 Maple Park,
Low Fields Avenue, Leeds
LS12 6HH

Tel: 01133023550
e-mail: info@whptelecoms.com

Site Name: **MAIN ROAD STREETWORKS**

Site ID: **NPT17240**

Address:
**MAIN ROAD, TREFORGAN, CRYNANT,
NEATH PORT TALBOT, WALES,
SA10 8NY**

Title: **210 PROPOSED SITE PLAN**

Project: **5G UNILATERAL**

Purpose of Issue: **PLANNING**


EE Cell ID:	MBNL Cell ID:	Cell ID:
N/A	N/A	N/A

Master Drawing No:	Issue:
NPT17240_M001	A

Antenna Aperture ID	Proposed 4G/5G Bearing
A1	20°
A2	20°
B1	185°
B2	185°

NOTES:

1. ALL DIMENSIONS IN MM UNLESS OTHERWISE NOTED.

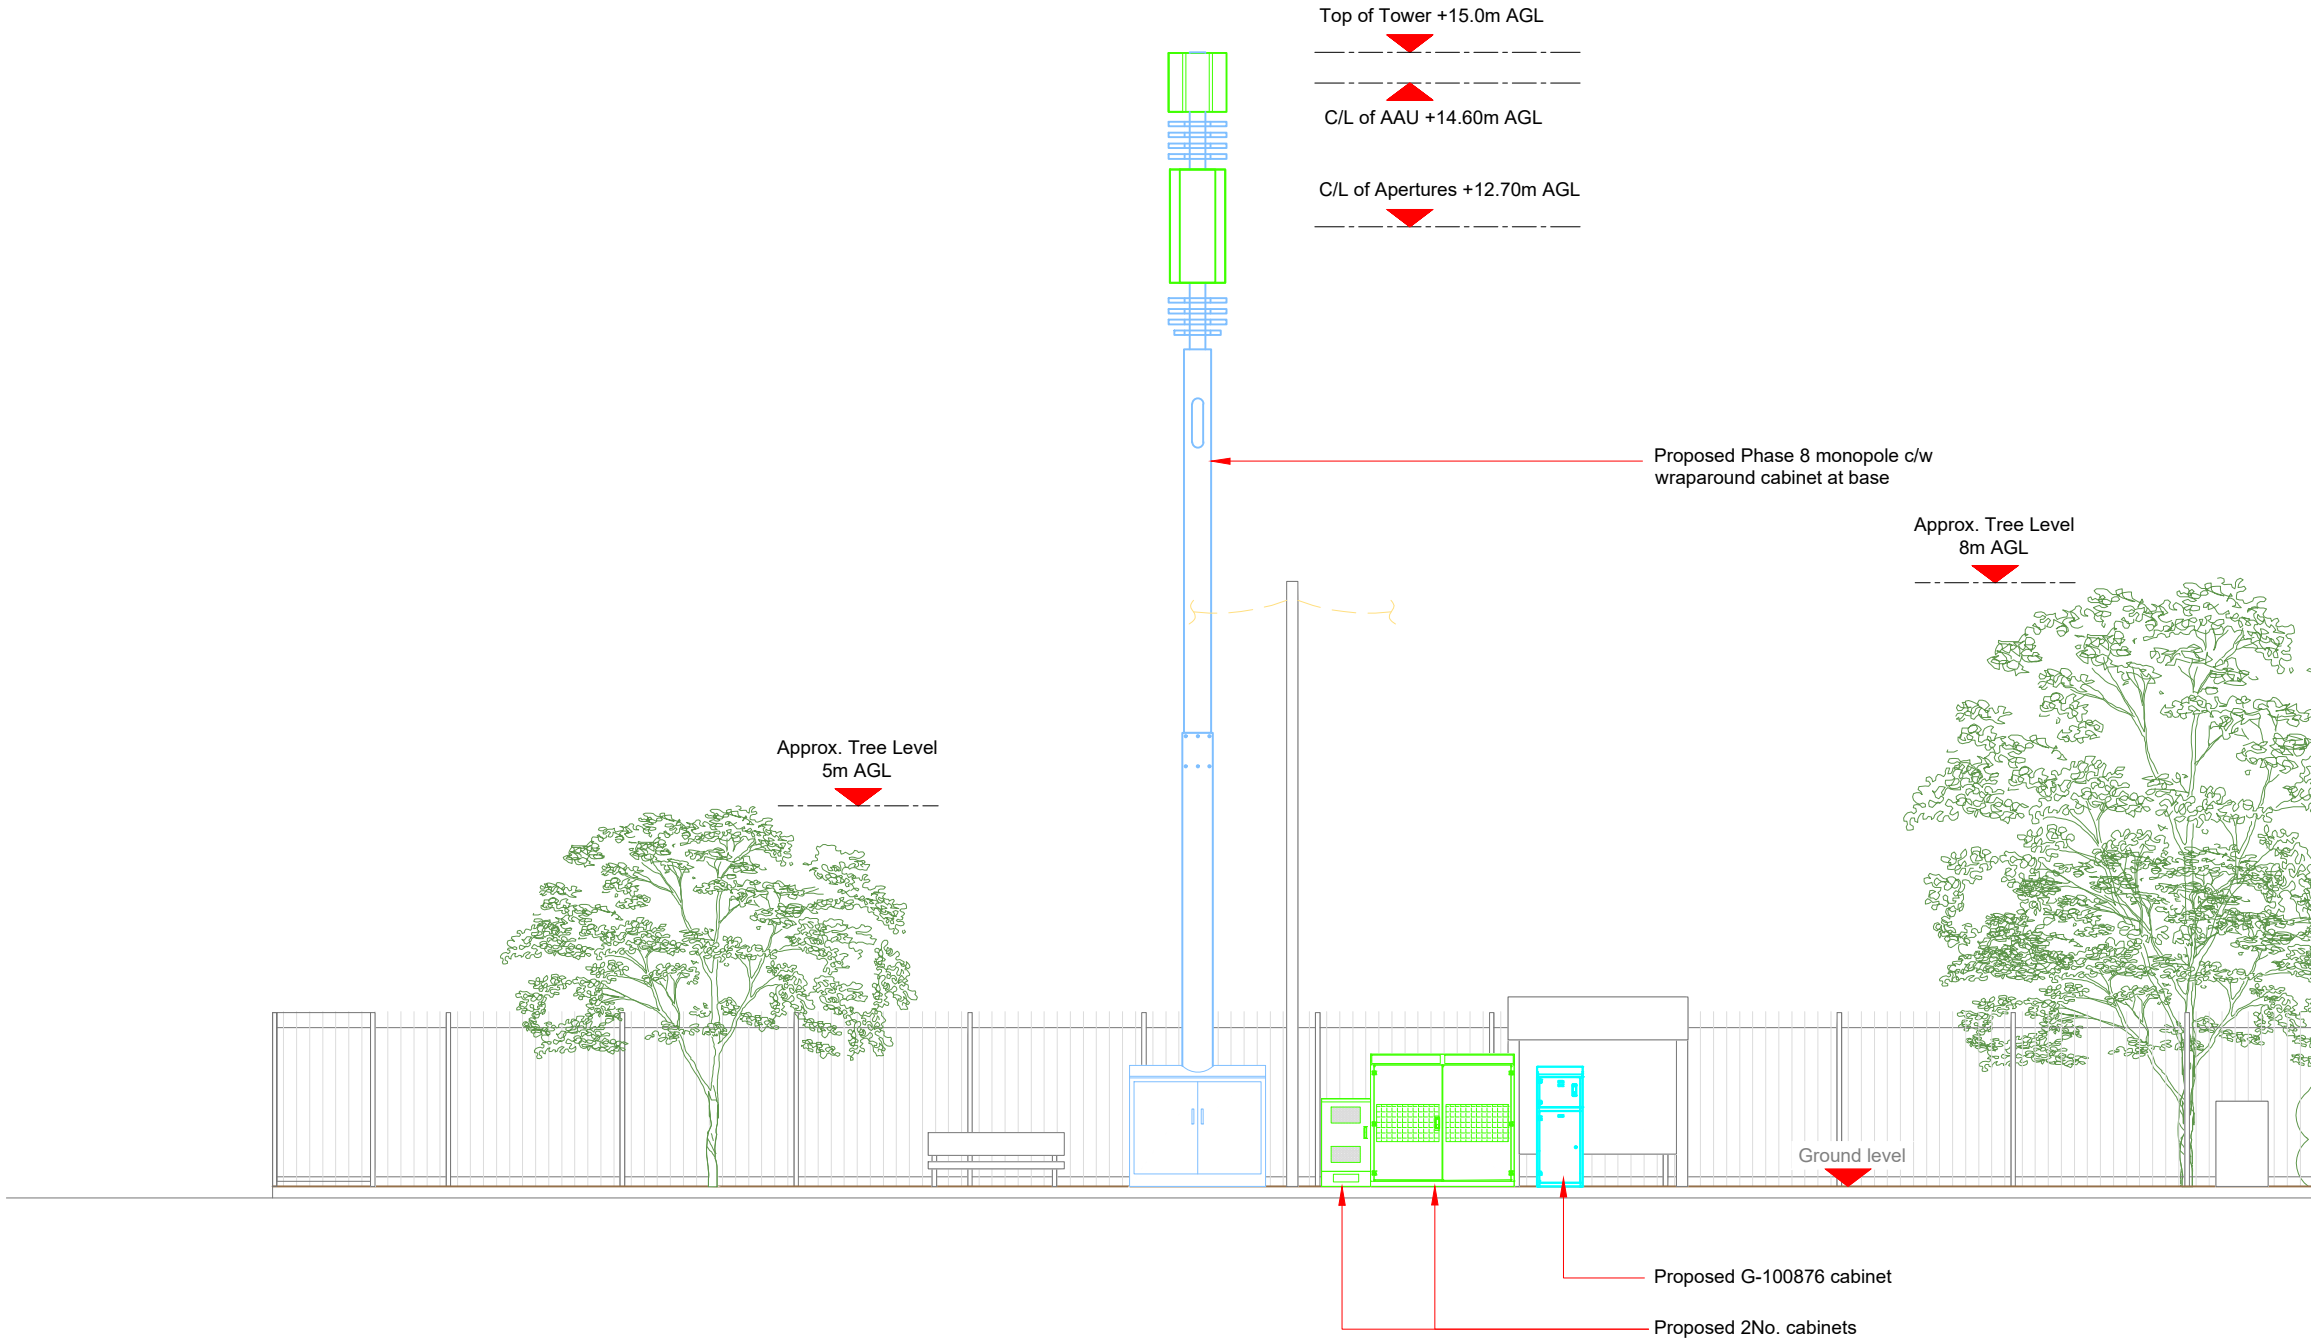

Master:	MBNL / EE:	Project:	Purpose of Issue:	Issue:
M001	MBNL	5G UNILATERAL	Planning	A
Date:	15/08/2021	Revision / Upgrade Description:		
Drawn:	CDN	First Issue - Site nomination dated: TBC		
Checked:	DH			
Approved:	SD			

CK Hutchison Networks (UK) Limited

Great Brighams Mead,
Vastern Road, Reading,
Berkshire, England,
RG1 8DJ

Design Consultant & Principal Contractor:



WHP Telecoms

Unit 1 Maple Park,
Low Fields Avenue, Leeds
LS12 6HH

Tel: 01133023550
e-mail: info@whptelecoms.com

Site Name: **MAIN ROAD STREETWORKS**

Site ID: **NPT17240**

Address: **MAIN ROAD, TREFORGAN, CRYNANT,
NEATH PORT TALBOT, WALES,
SA10 8NY**

Title: **260 PROPOSED ELEVATION**

Project: **5G UNILATERAL**

Purpose of Issue: **PLANNING**

EE Cell ID:	MBNL Cell ID:	Cell ID:
N/A	N/A	N/A

Master Drawing No:	Issue:
NPT17240_M001	A