


001.
NEW - Sprinkler pump house


 
002.
NEW - Sprinkler tank 01

003.
NEW - Sprinkler tank 02

004.
NEW - Electrical service building

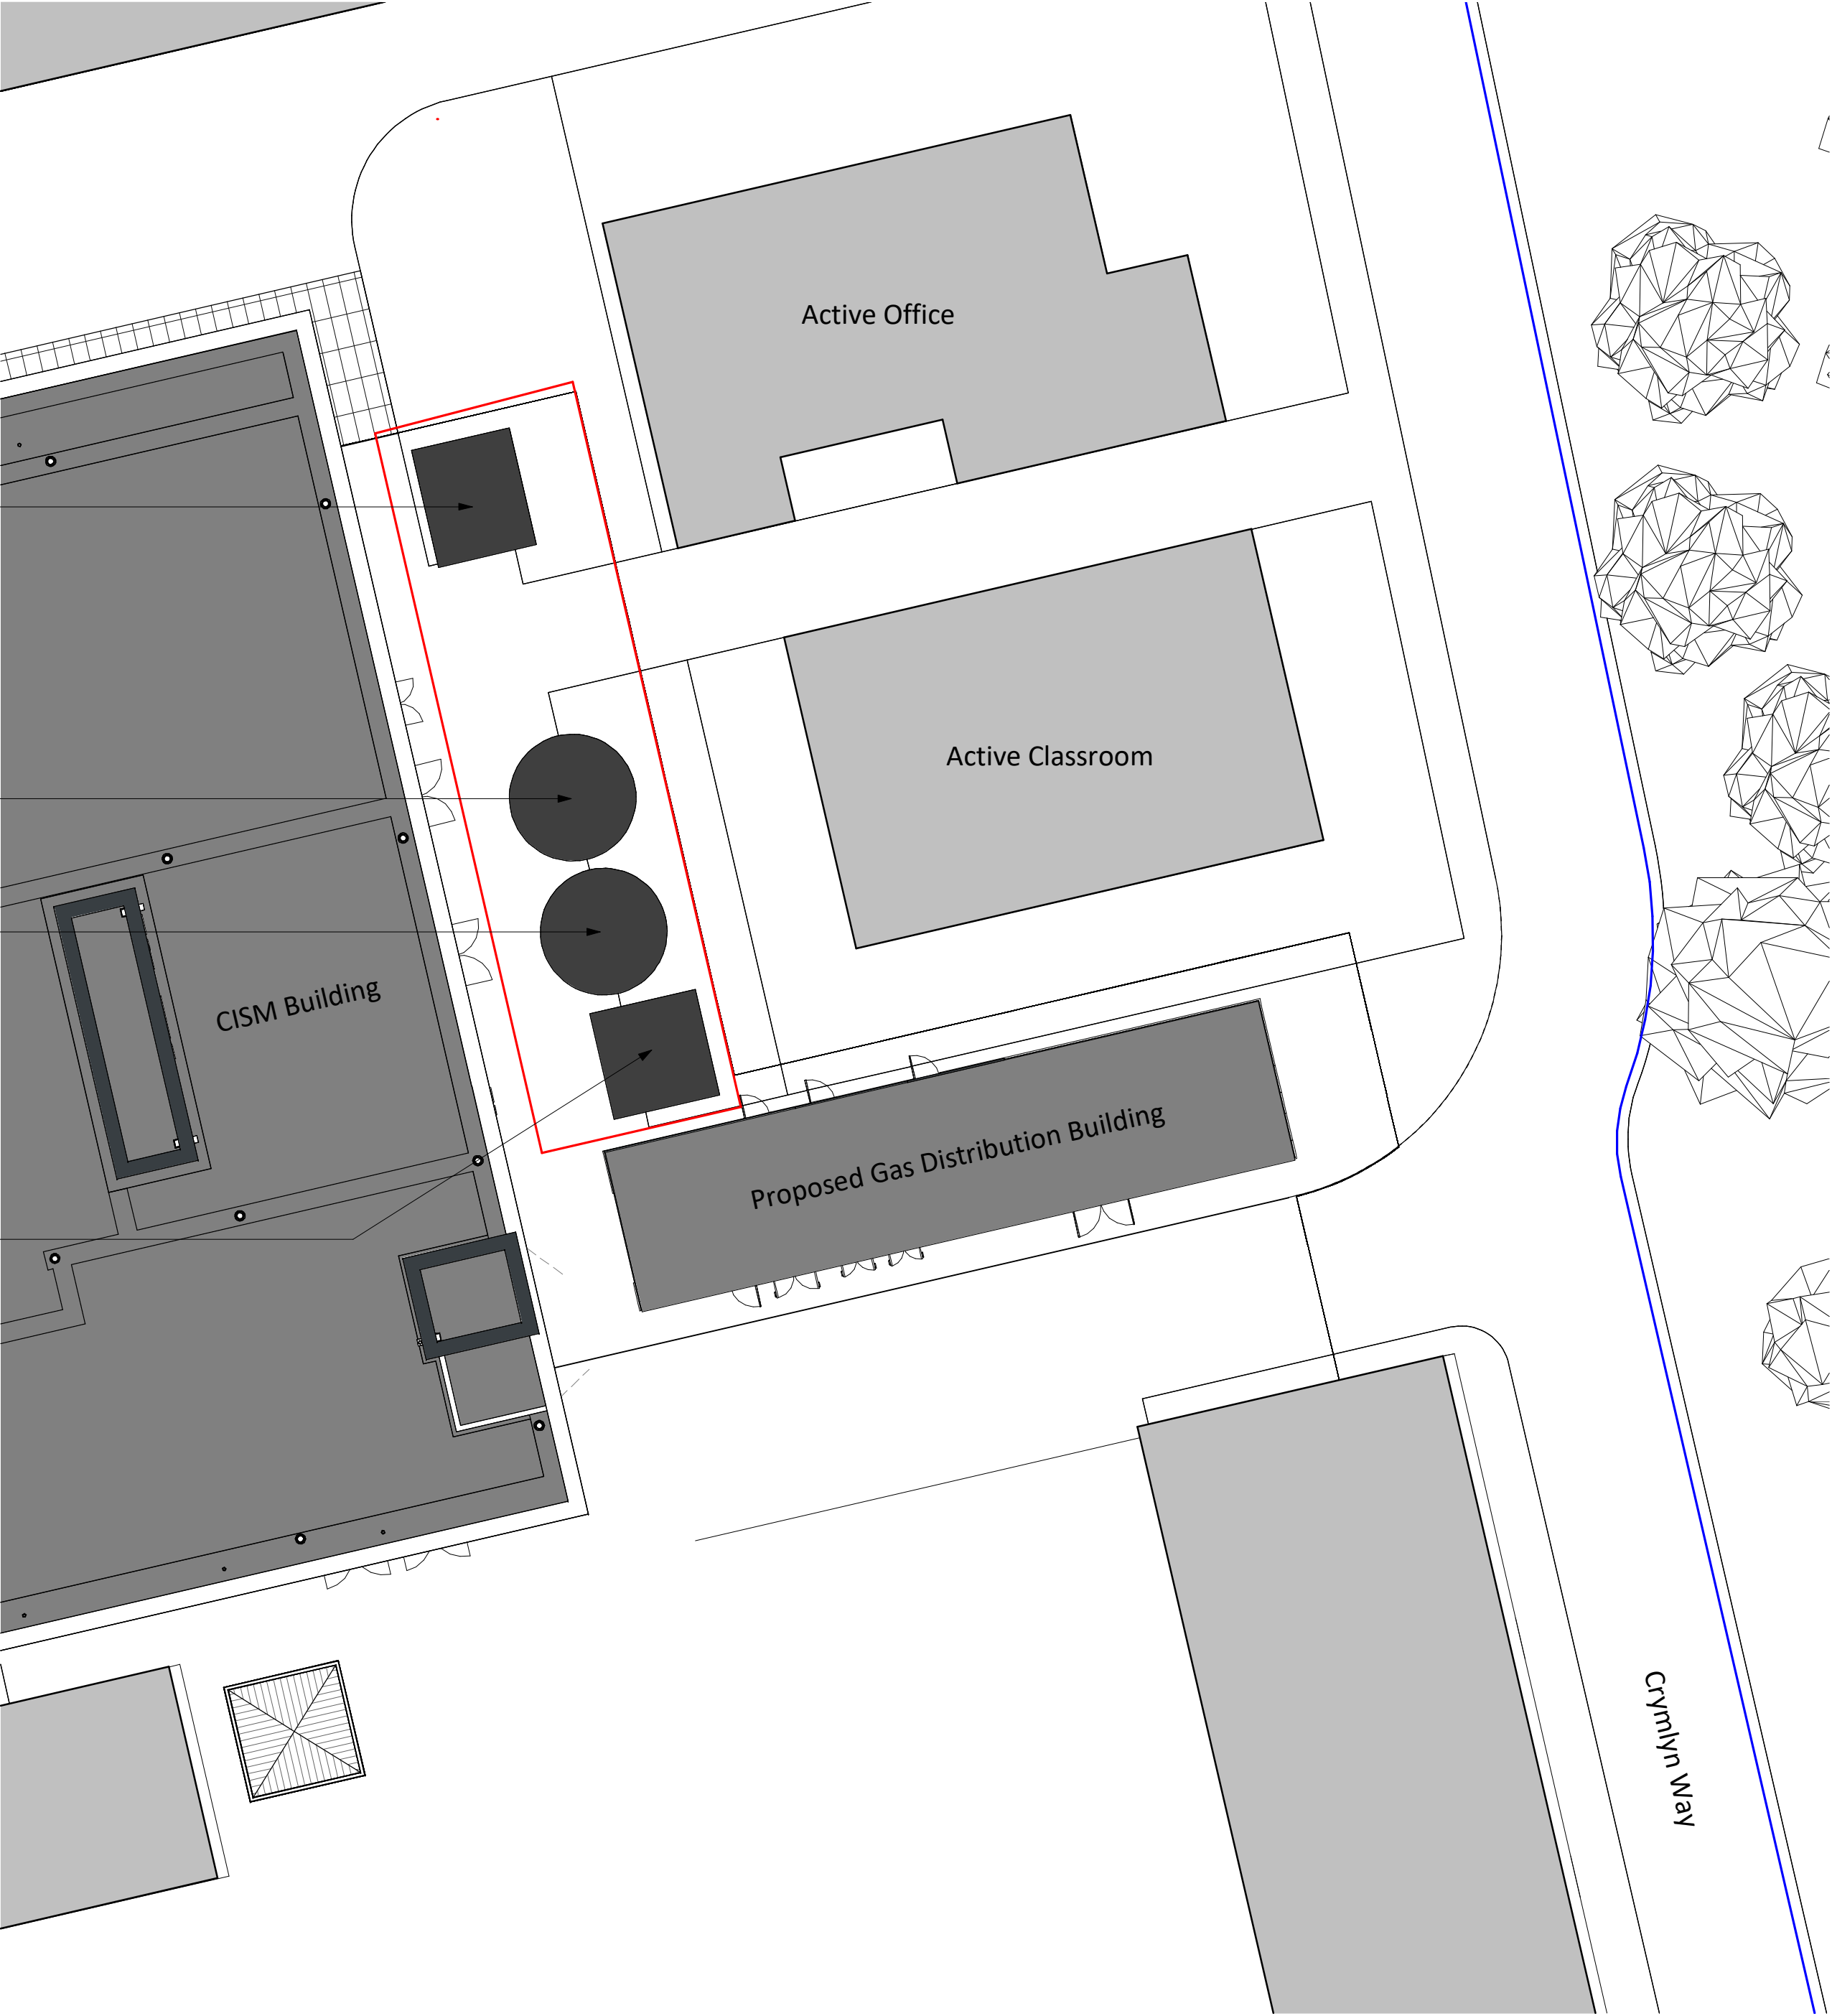

Proposed site plan
1 : 200

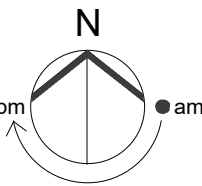

STATUS	REV	DATE	DESCRIPTION	REVISED BY
CLIENT				RC
Swansea University				CHECKED BY
				PW
ORIGINATOR NO				152296

CONSULTANT
STRIDE TREGLOWN
www.stride-treglown.com © Stride Treglown Limited 2017
PROJECT
CISM
SU Bay Campus

DRAWING TITLE
Proposed Site Plan

SUITABILITY STATUS	SCALE
S1 : SUITABLE FOR CO-ORDINATION	1 : 200 @ A2
PROJECT ORIGINATOR ZONE LEVEL TYPE ROLE CLASS NUMBER	REVISION
CISM-STL-XX-00-DR-A-ZZZZ-0632	