
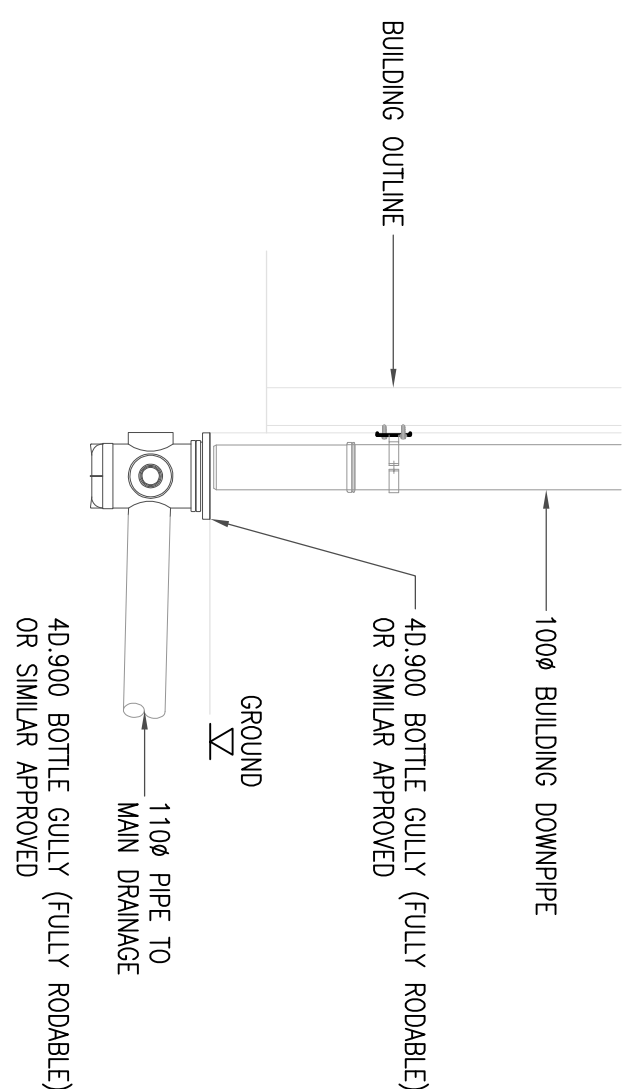
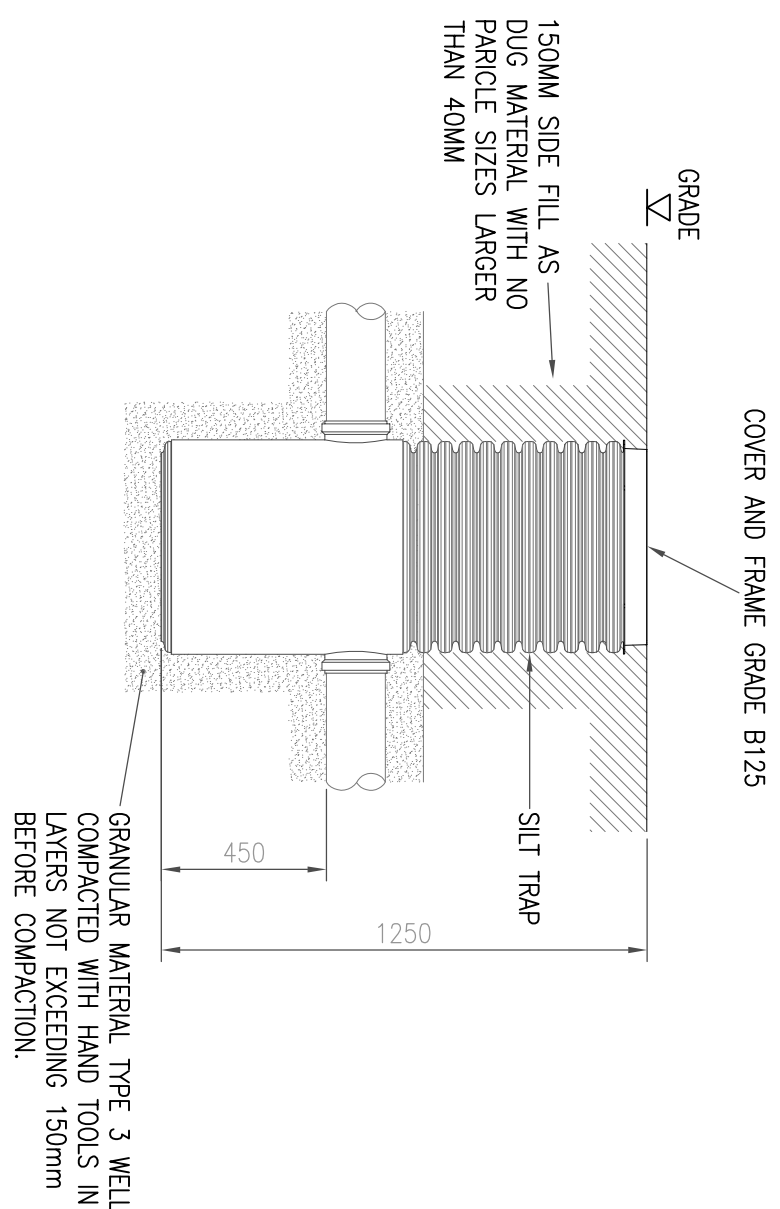
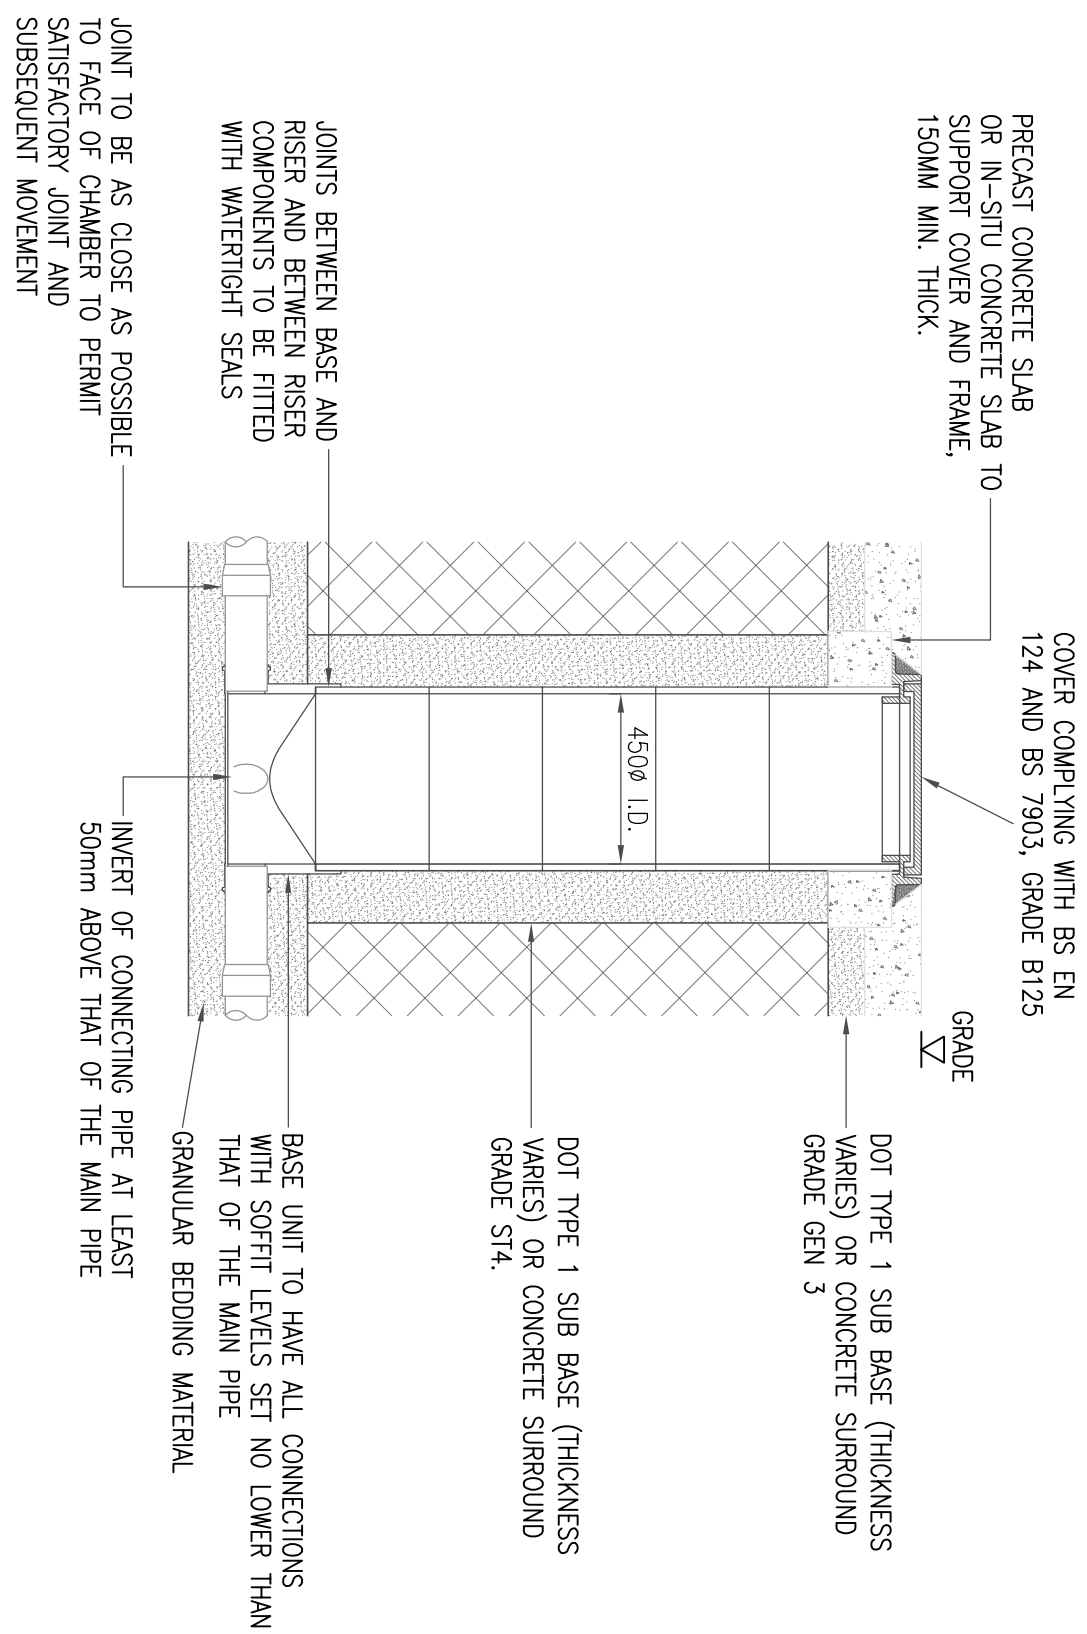
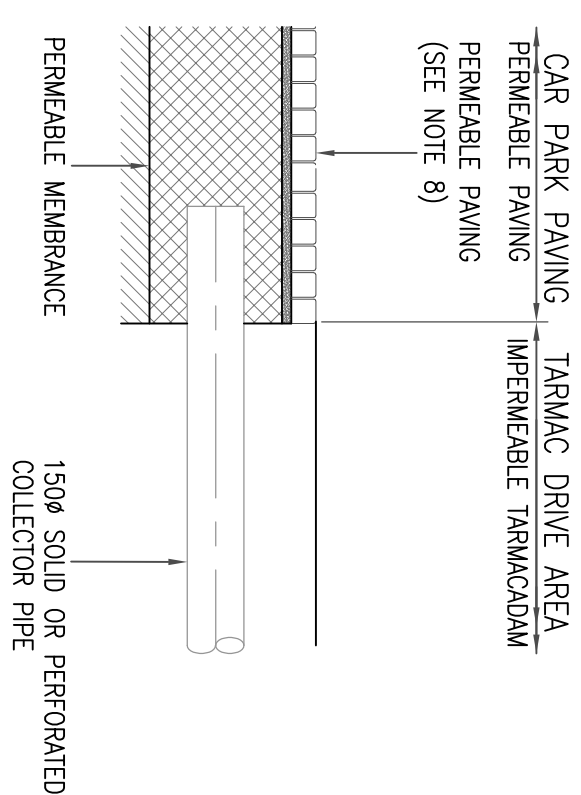
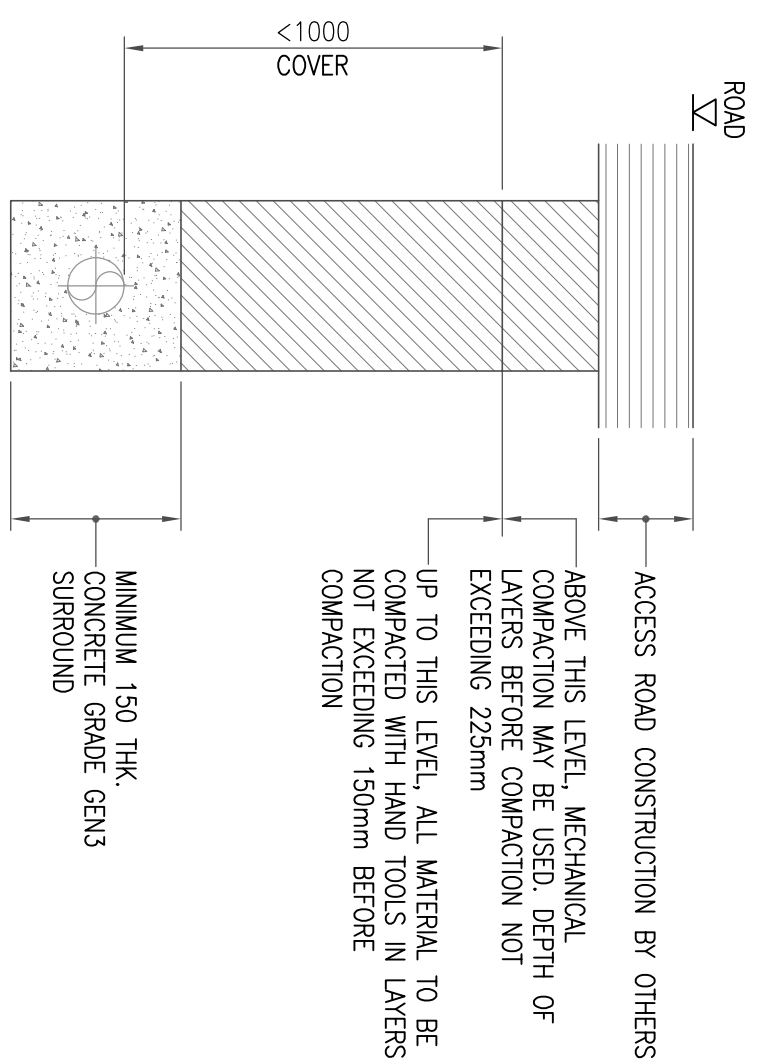


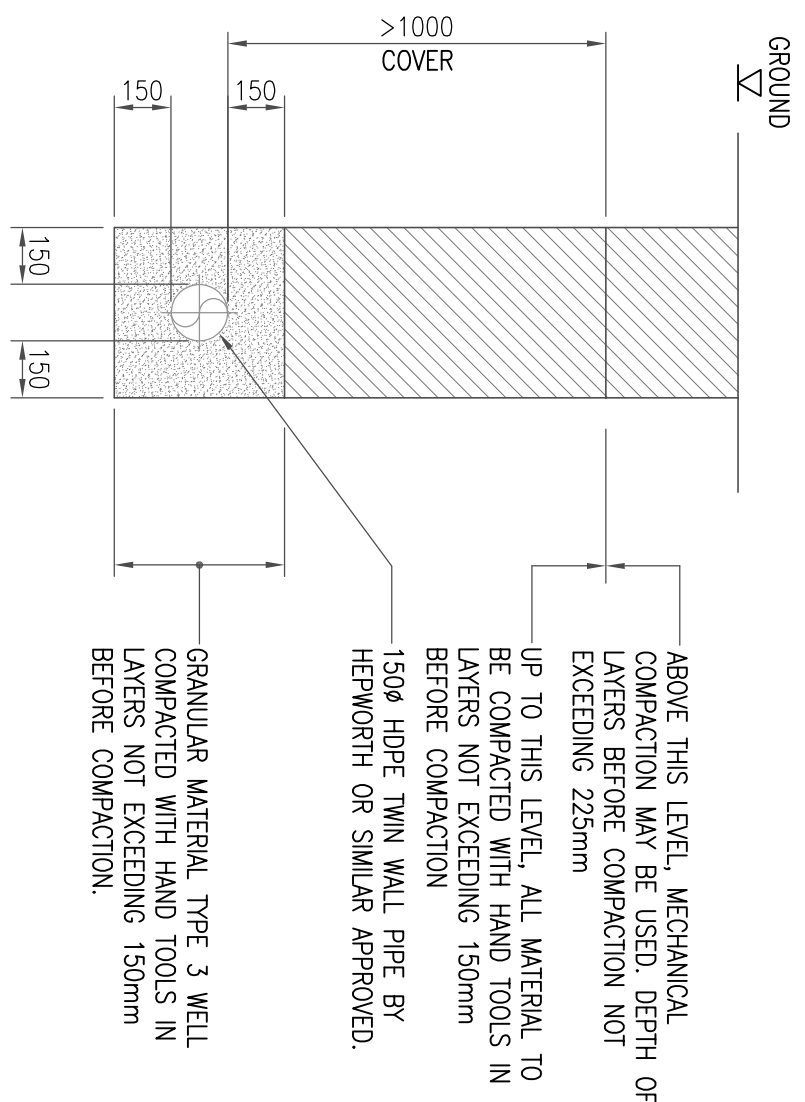

- NOTES:
1. PLASTIC CHAMBERS, AND RINGS SHALL COMPLY WITH BS EN 13398-1 AND BS EN 13398-2 OR HAVE EQUIVALENT INDEPENDENT APPROVAL.
2. MORAR BEDDING AND HAUNCHING TO COVER AND FRAME TO CHAINSE E67 SEWERS FOR ADOPTION 7TH ED.
3. ALL PIPEWORK, BENEATH VEHICULAR AREAS AND WITHIN 1m OF SUCH AREAS SHALL, WHERE COVER IS LESS THAN 1200mm, RECEIVE A FULL CONCRETE BED AND SURROUND, 900mm ELSEWHERE.
4. ALL PIPEWORK, BENEATH BUILDING FOOTPRINT TO RECEIVE FULL CONCRETE BED AND SURROUND.
5. MASS CONCRETE SURROUND TO PIPES, GULLIES TO BE GRADE GEN 3.
6. INFILL MATERIAL SHOULD BE COMPACTED TO 95% PROCTOR DENSITY IN MAXIMUM 150mm LAYERS.
7. ALL TRENCH BACKFILL MATERIAL TO BE APPROVED, FREE FROM SHARP EDGES AND DELETERIOUS MATTER.
8. REQUIREMENTS FOR KERBS AROUND PERMEABLE PAVING TO BE DETAILED BY THE CONTRACTOR.

REFERENCE DRAWINGS	
172-CL-001	DRAINAGE LAYOUT
172-RP-001	PROPOSED DRAINAGE STRATEGY

REV	DATE	DESCRIPTION	DESIGN	DRAWN	CHEK	APP
0	06/10/21	ISSUED FOR REVIEW	GP	RIL	GP	JW

THE INTELLECTUAL PROPERTY AND, WHERE APPLICABLE, COPYRIGHT IN THE DRAWING IS HELD BY CASTLE BUCH ENGINEERING LTD. AN IRREVOCABLE, NON-TRANSFERABLE, ROYALTY-FREE LICENSE TO USE THE DRAWING AND THE INFORMATION CONTAINED WITHIN IT IS GRANTED TO THE CLIENT FOR WHOM IT WAS PRODUCED, SUBJECT TO FULL PAYMENT OF THE FEES FOR THE PROJECT TO WHICH THE DRAWING RELATES. THE FULL TERMS OF THE LICENSING ARRANGEMENTS ARE CONTAINED IN CASTLE BUCH ENGINEERING LTD TERMS AND CONDITIONS OF BUSINESS, OR THE CONTRACT FOR THE PROJECT AS APPROPRIATE.



Castell Bach
Engineering Ltd

PROJECT MARGAM YC & FOOTBALL CLUB

PROPOSED DRAINAGE DETAILS

SCALE AS SHOWN	PROJECT No 172	DOCUMENT No 172-CL-002	REV 0
-------------------	-------------------	---------------------------	----------