

Dimensions are not to be scaled from this drawing


Untitled Map

Write a description for your map.



Kingfisher Lighting

Part of the Luceco PLC group of companies LUCECO

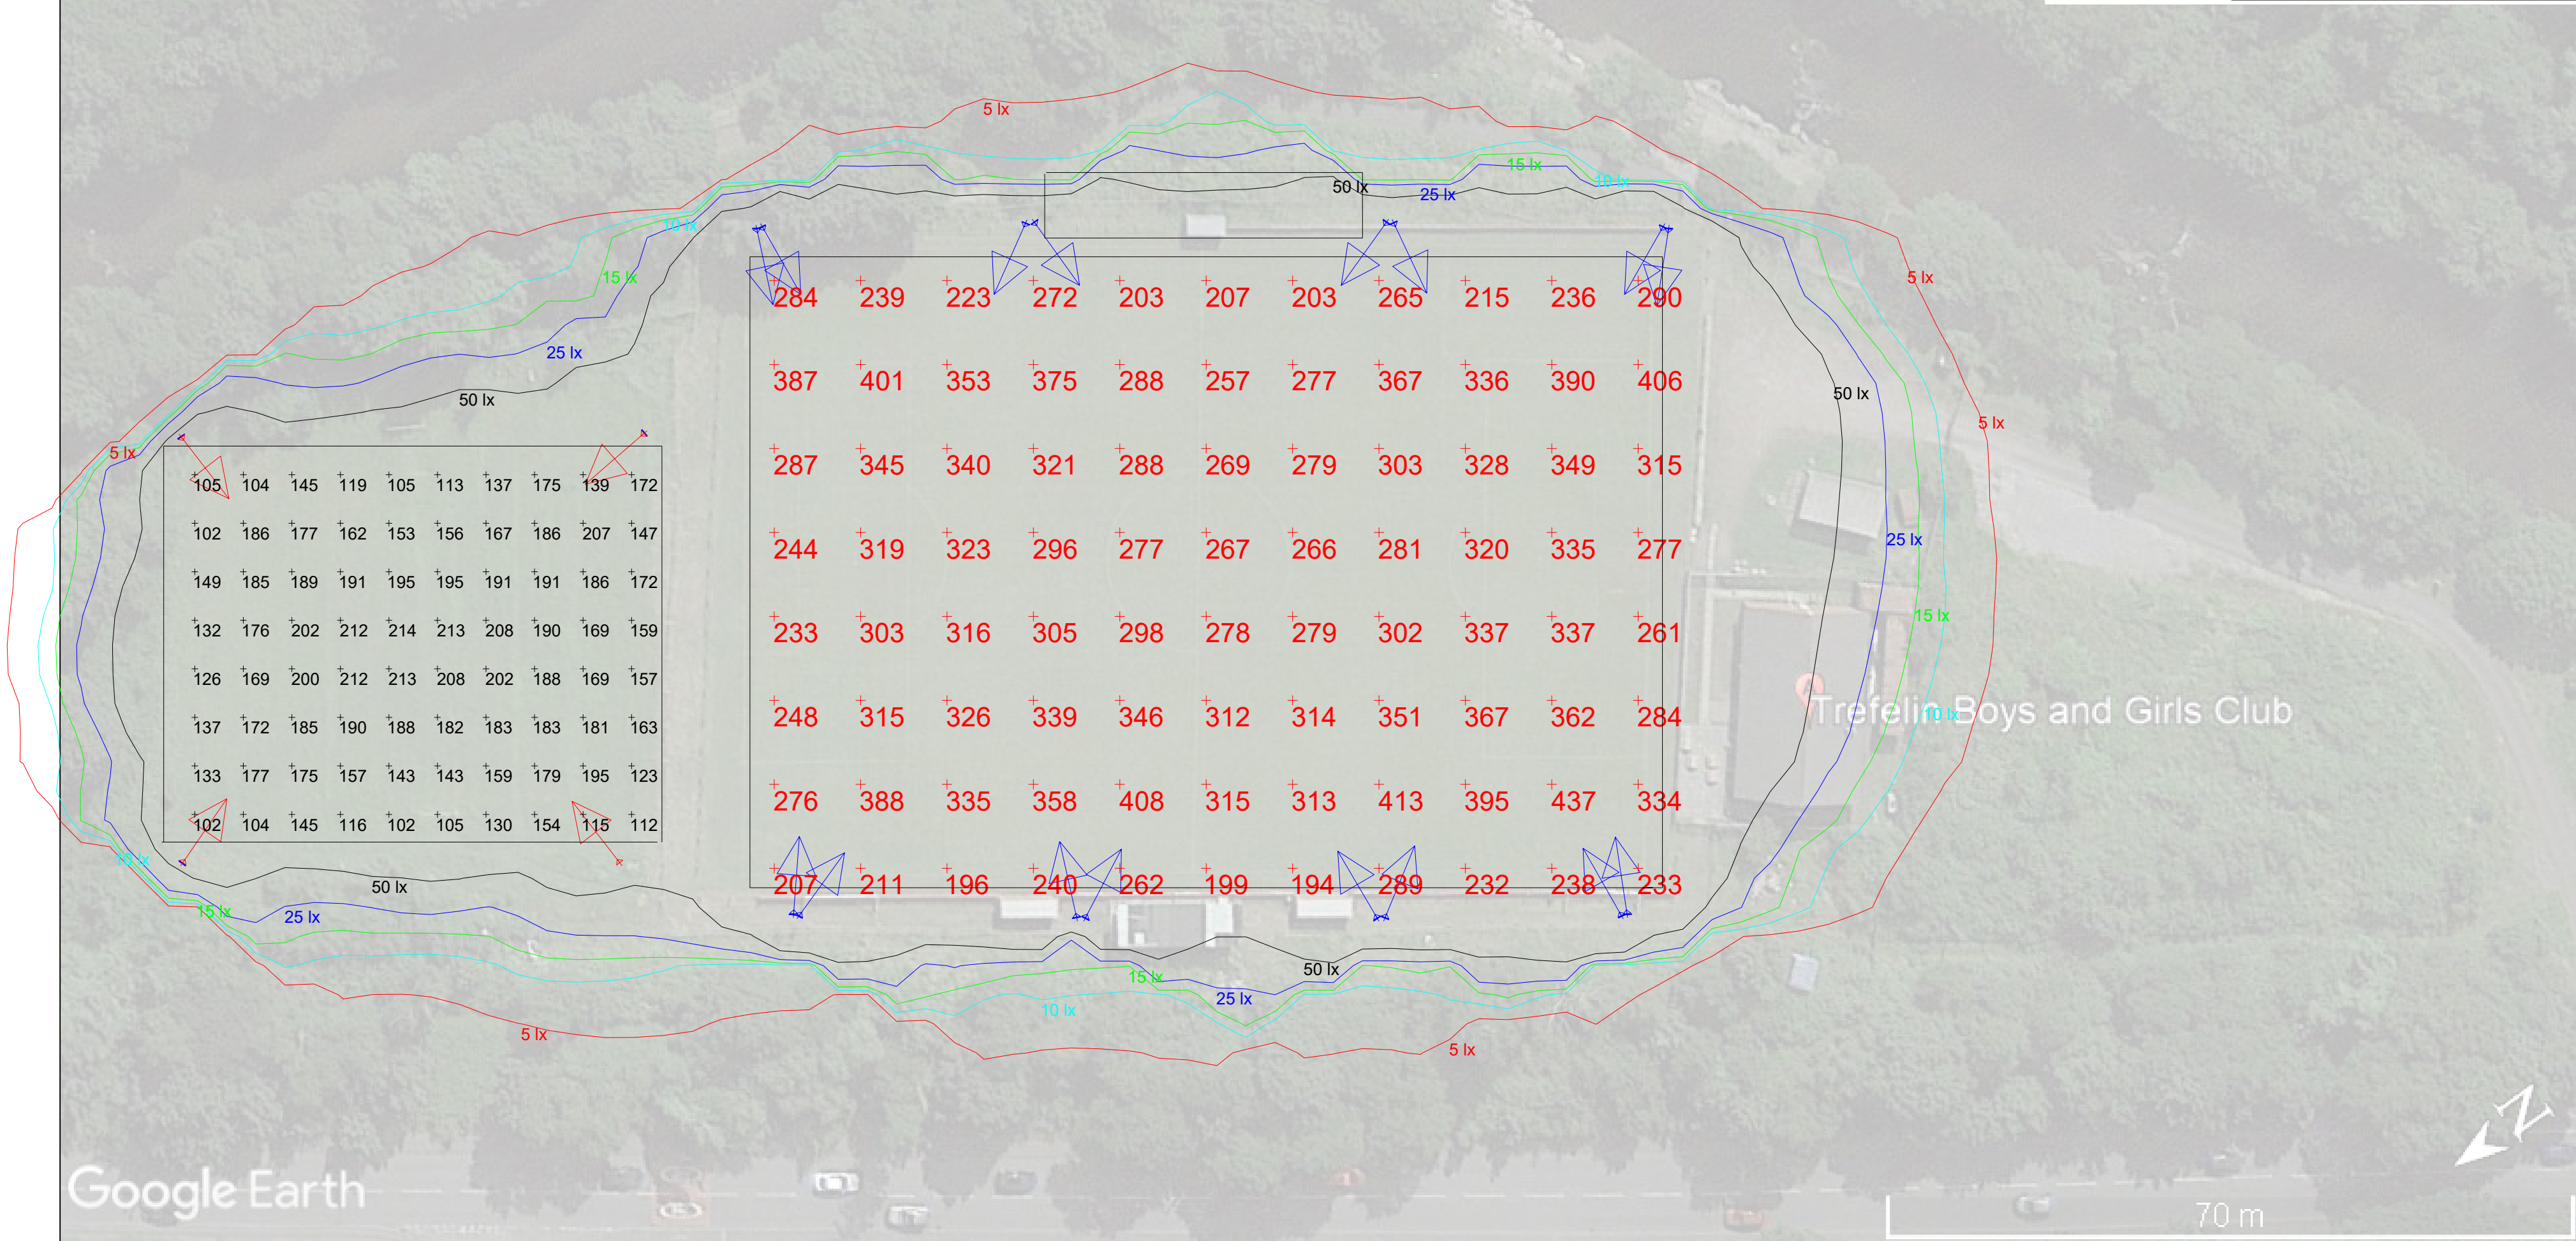

Calculation Summary							
Scene: 1							
Label	CalcType	Units	Avg	Max	Min	Min/Avg	Min/Max
Football Field	Illuminance	Lux	299.88	437	194	0.65	0.44
ISO	Illuminance	Lux	53.21	450	0	0.00	0.00
Training Area	Illuminance	Lux	163.16	214	102	0.63	0.48

Luminaire Schedule				
Scene: 1				
Symbol	Qty	Label	Arrangement	Description
	16	A	SINGLE	1 x Amnis 1350W Short Narrow Throw Mounted @ 15m New
	4	B	SINGLE	1 x Amnis 900W Short Narrow Throw Mounted @ 10m New

Trefelin RFU - 250 Lux 0.6 & 100 Lux 0.6 Training Field		Scale 1: 500 at A2	Project Number D1 - DESIGN A TREFELIN F.C
		Date 06/08/2020	Drawing No. Design 1
Lighting Designer : Tom Ford			
A lighting applications design service is provided by us in good faith and without charge, relating to Kingfisher products only. As such, whilst every endeavor is made for accuracy from information provided by yourselves, the final responsibility for the suitability of the design lies with the client. The company cannot, therefore, accept any liability or consequential loss incurred.			