


Luminaire Schedule					
Symbol	Qty	Label	Lum. Lumens	LLF	Description
	2	D	812	0.900	6w LED Semita Urban bulkhead with flood optic Wall Mounted at 1.8m
	2	A-BM	3690	0.900	30_5w (2 module) 525mA Italo 1 with S05 Optic Building Mounted at 5m
	3	B-BM	2510	0.900	20_5w (1 module) 525mA Italo 1 with STE-M Optic Column Mounted at 5m
Calculation Summary					
Label	Units	Avg	Max	Min	Uniformity
Block A Parking	Lux	15.58	32	8	0.51
Block B Access Road & Carpark	Lux	11.81	46	3	0.25
Block B Pathway	Lux	2.60	12	0	0.00



Kingfisher Lighting

Part of the Luceco PLC group of companies **LUCECO**

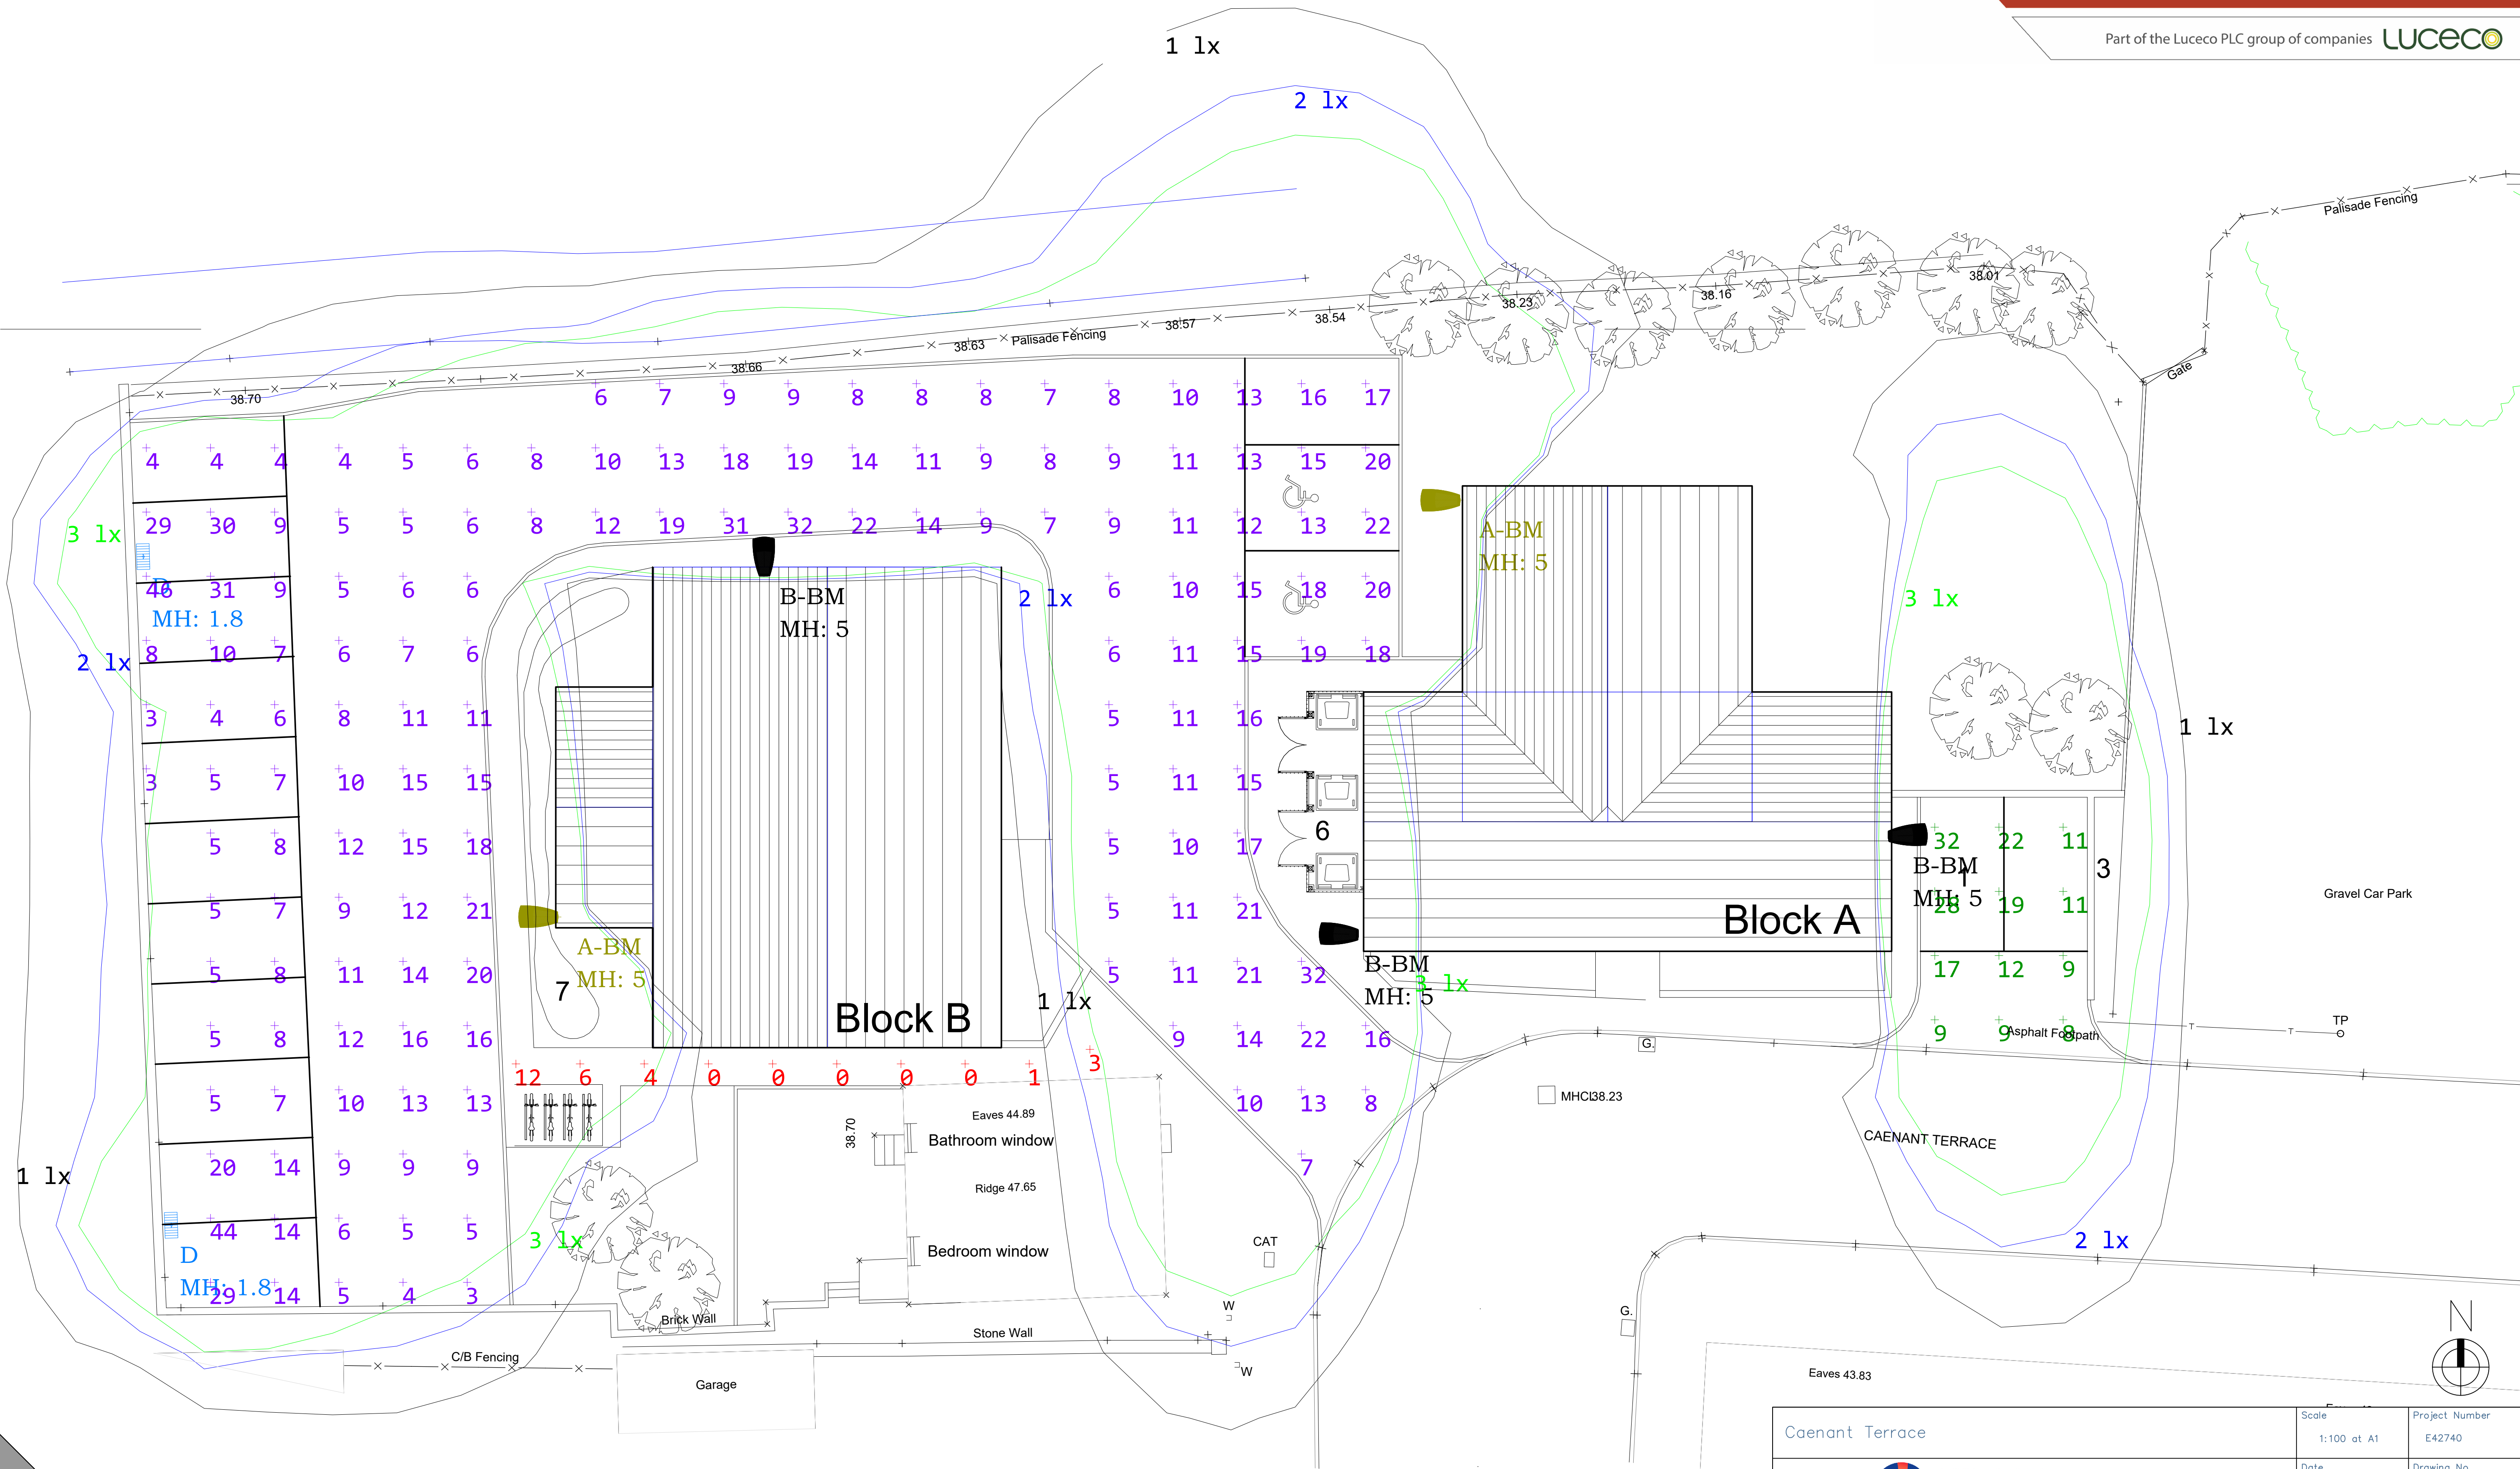

A1

	Scale 1:100 at A1	Project Number E42740
	Date 1 February 2022	Drawing No. 42740/PJ/B
	Lighting Designer : Paul James	

A lighting applications design service is provided by us in good faith and without charge, relating to Kingfisher products only. As such, whilst every endeavor is made for accuracy from information provided by yourselves, the final responsibility for the suitability of the design lies with the client. The company cannot, therefore, accept any liability or consequential loss incurred.