


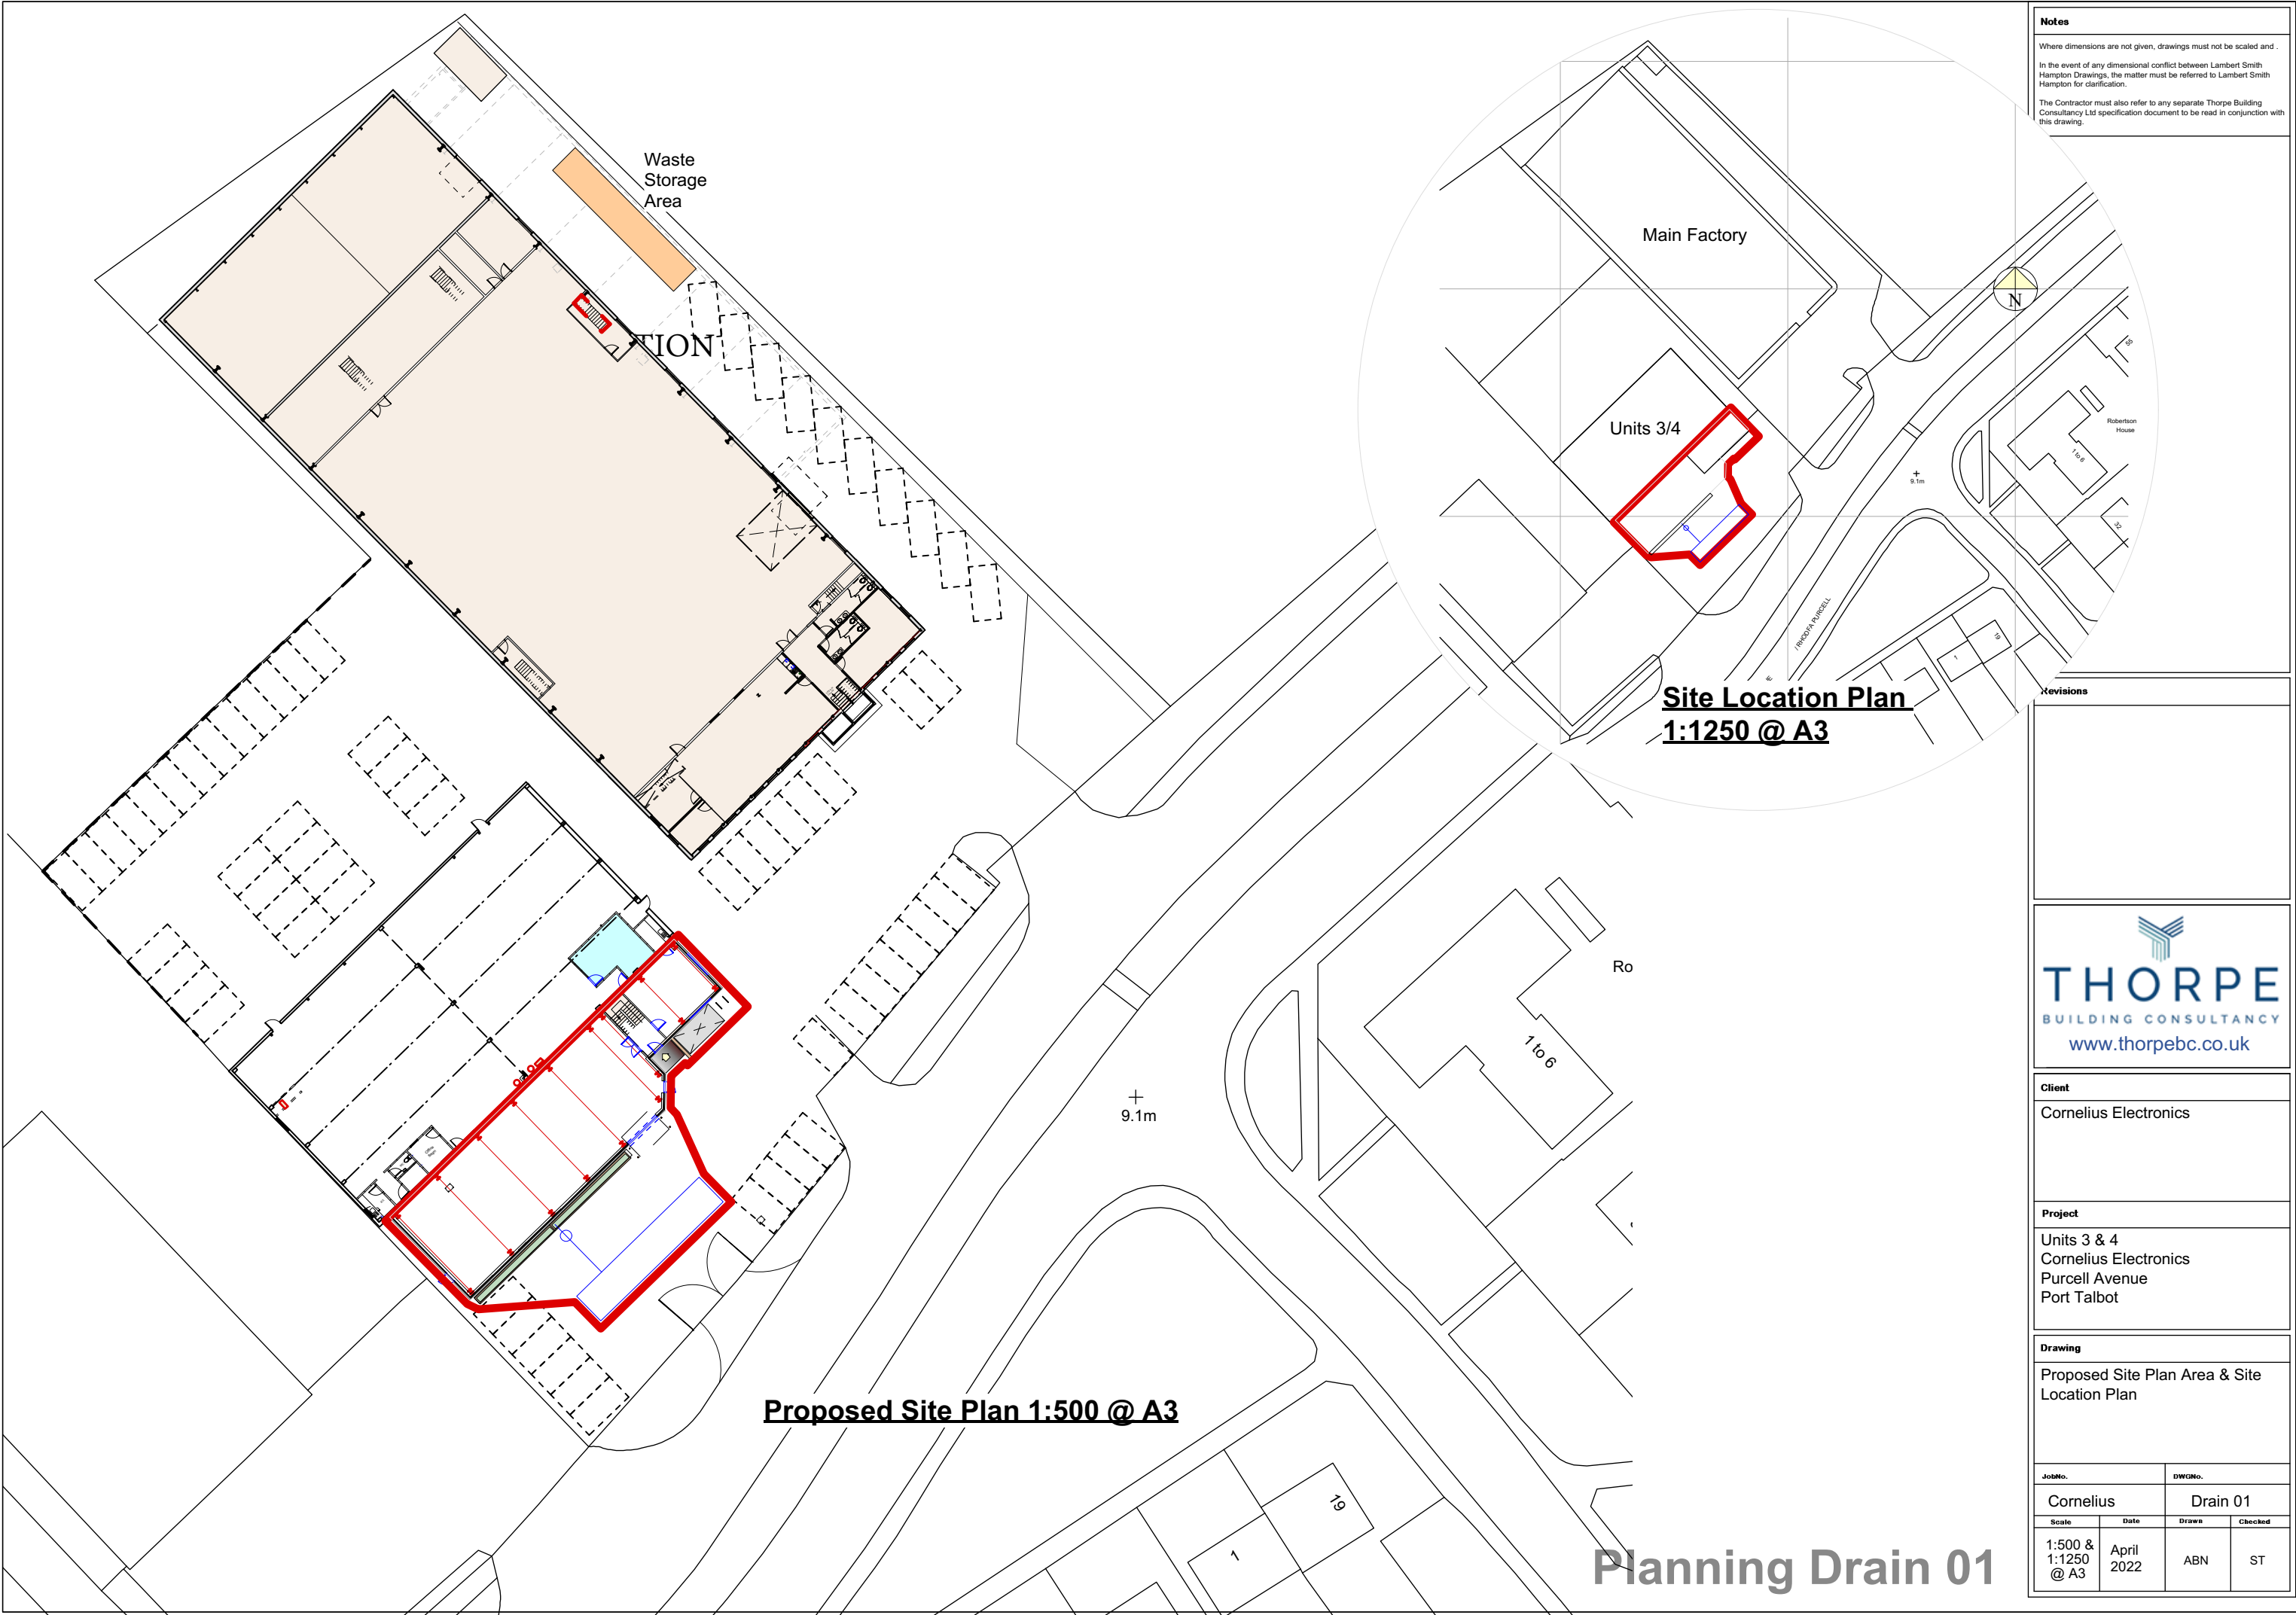


Notes

Where dimensions are not given, drawings must not be scaled and.

In the event of any dimensional conflict between Lambert Smith Hampton Drawings, the matter must be referred to Lambert Smith Hampton for clarification.

The Contractor must also refer to any separate Thorpe Building Consultancy Ltd specification document to be read in conjunction with this drawing.

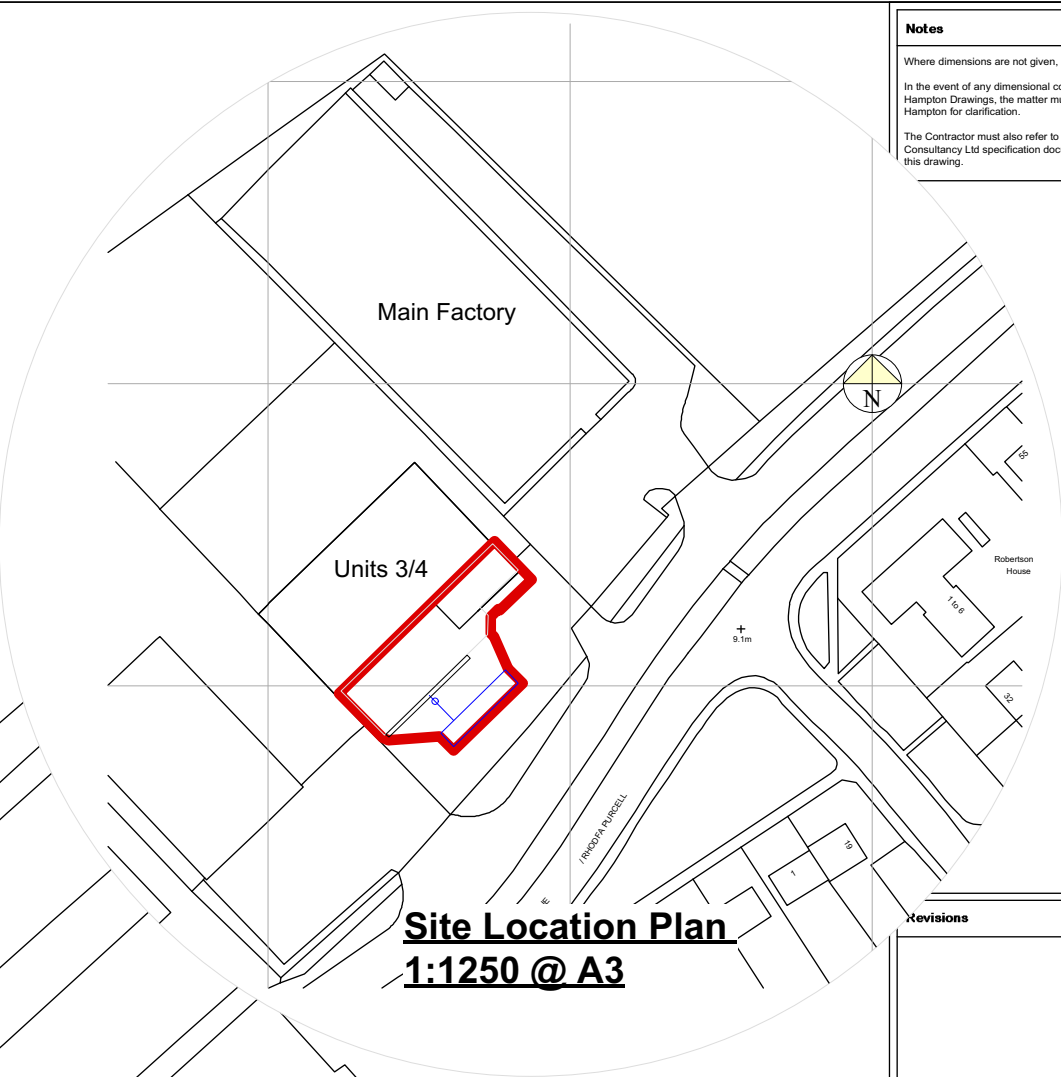

Site Location Plan
1:1250 @ A3

Revisions

--	--	--	--



THORPE
BUILDING CONSULTANCY
www.thorpebc.co.uk

Client

Cornelius Electronics

Project

Units 3 & 4
Cornelius Electronics
Purcell Avenue
Port Talbot

Drawing

Proposed Site Plan Area & Site Location Plan

JobNo.		DWGNo.	
Cornelius		Drain 01	
Scale	Date	Drawn	Checked
1:500 & 1:1250 @ A3	April 2022	ABN	ST

Proposed Site Plan 1:500 @ A3