


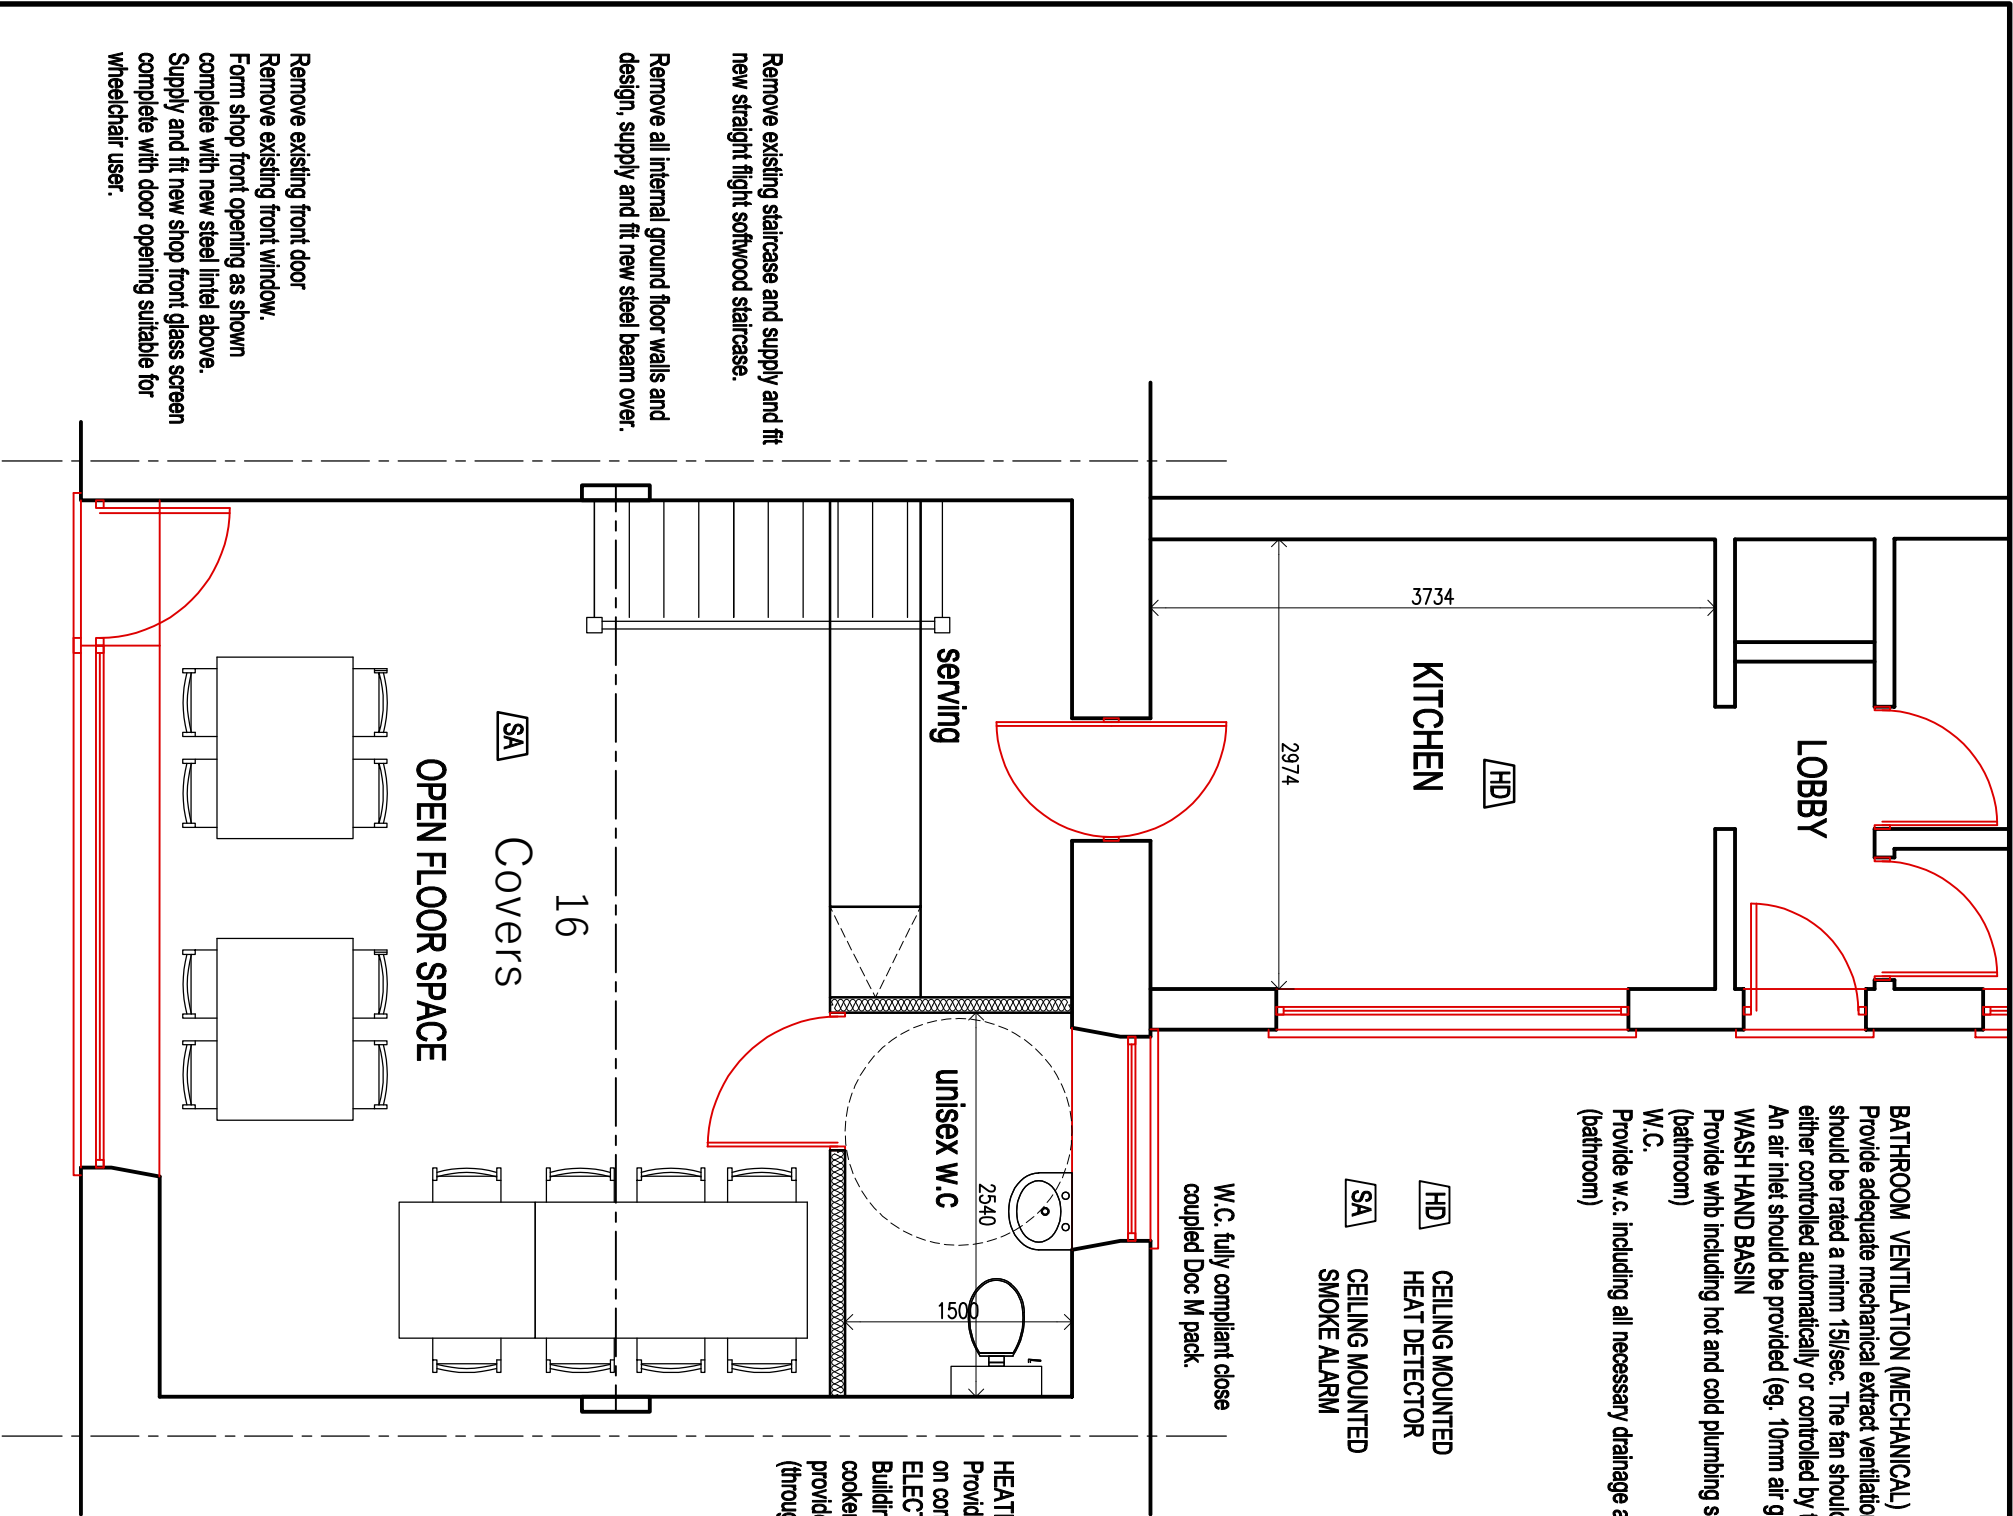

HEATING APPLIANCE (PROVIDE)
Provide suitable heating to main living area (certificate to be provide by approved GAS SAFE contractor on completion. (Provide Gas Combination central heating system.

ELECTRICAL (REWIRING)
Building to be rewired throughout for lighting circuits, power circuits including new distribution board, cooker point, trip switch and all necessary earthing and bonding etc. Electrical safety certificate to be provided on completion by approved electrical N.I.C.E.I.C. contractor. (all cables to be buried in wall) (throughout property)

CLIENT
DAVEM TRAINING SERVICES LTD.

job title
PROPOSED CHANGE OF USE CLASS FROM C3 TO A3
@ 41, COMMERCIAL ROAD, TAIBACH PORT TALBOT
SA13 1LN

drawing title
PROPOSED GROUND FLOOR PLAN.

job No:	drawing No:	scales:
22.42	04	1:50 @A3

PROPOSED GROUND FLOOR PLAN.
(1:50)