

LiAS Design Notes

This preliminary design is produced by the Lighting Application Specialist (LiAS) team of Signify UK&I based on information supplied by the Customer for the purpose of identifying suitable products and costing the proposal. This design cannot be used for Construction, as this design does not purport to eliminate health and safety risks as a CDM Regulation risk assessment has not been undertaken.

Depending on the level of information received, a number of assumptions may have been applied in order to create an indicative lighting proposal and costing model, according to lighting industry guidelines and incorporating industry best practice methods. These assumptions are documented below and will require confirmation by the Principle Designer or PSDP (which are not Signify UK&I) during the detailed design phase.

Project Specific Assumptions

- Assumed Class II Tennis Court levels (300 Lux Average, 0.7 Min/Ave).
- Assumed 8m mounting height.
- Court dimensions and locations taken from Google Earth.

Generic Assumptions (unless specifically informed differently)

- Preliminary Design proposals produced by the Signify LiAS Team are not to be used for installation purposes. It is the responsibility of the Principle Designer and/or Principle Contractor to ensure all Installation and Maintenance can be done in a safe manner, carried out by competent persons, based on their agreed Risk Assessments and Method Statements.
- The Luminaire Maintenance Factors have been based on 6-year cleaning intervals within an E3/E4 Environmental Zone and it is assumed that lamp/luminaire failures will be replaced on a 'spot replacement'.
- Energy consumptions have been based on the luminaire/s having Constant Light Output (CLO) enabled and the quoted wattage/s are the average over 100,000 hours (without dimming).
- The design calculations produced by Signify do not account for the effect obstructions, such as trees, will cause.
- Signify has not been provided with utility plans showing Buried, Above Ground or Overhead utilities. Therefore, all column/luminaire locations are indicative and are subject to review/verification by the Principle Designer.
- Unless stated otherwise, Signify has not visited site. Therefore, all column/luminaire locations are indicative and are subject to an onsite verification arranged/performed by the Principle Designer.
- Signify has not produced any Private Cable Network electrical calculations or reviewed the DNO network to confirm power supplies to the proposed lighting.
- Signify has not performed any asset condition testing and therefore assumes that any existing lighting columns/wall mounted brackets are structurally capable of supporting the weight & windage of the proposed luminaire/s. This must be verified by the Principle Designer before installation works commence.
- Unless stated otherwise, Signify is not supplying the new lighting columns (including brackets etc) and therefore it is the responsibility of the Principle Designers to confirm that all proposed equipment is suitable for the intended locations (e.g. raise & lower, ground condition, foundation type, saline environment, etc).
- Unless stated otherwise, luminaires will be supplied in their standard colour.

Luminaire Schedule

➡ BVP518 1xLED1480/757 OUT T15 50K A55-NB +LO

Philips Lighting Contacts


George Pointing, Key Account Manager - 07933 647 399 - George.Pointing@Signify.com
Mark Davies, Lighting Application Specialist - 07979935894 - Mark.Davies@Signify.com
Quotes & Orders - 01483 446070 - Lighting.Sales.Outdoor@Signify.com



Lighting Proposal Terms and Conditions of Use
These terms apply to the use of this preliminary proposal produced by Signify UK. This “**Proposal**” is understood to mean this document, a CAD drawing, lighting calculations, written documents, verbal conversations or any medium used to demonstrate or communicate the proposed lighting scheme using products from Signify’s brands. A “**Customer**” is the person or organisation for whom the Proposal is intended. The “**CDM Regulations**” means The Construction, Design and Management Regulations 2015, the Safety, Health & Welfare at Work Act 2005, The Construction (Design & Management) Regulations (Northern Ireland) 2015.
This Proposal is for guidance only and cannot be relied upon for purposes of installation or Health and Safety.
The supply and installation of this lighting scheme are subject to a contract being agreed between Customer and Signify.

PROPOSAL
(NOT FOR CONSTRUCTION)

Rev	DSR no.	Comment	Date	LiAS	KAM	Project Number	Project Name
0	D-415791	Initial proposal.	08/07/21	MD	GP	0400634225	Neath Leisure Centre Tennis Courts
						Scale & Sheet Size	Drawing Name
						NTS @ A3	LiAS DESIGN NOTES & LUMINAIRE SCHEDULE
						Sheet No	
						DWG 00	

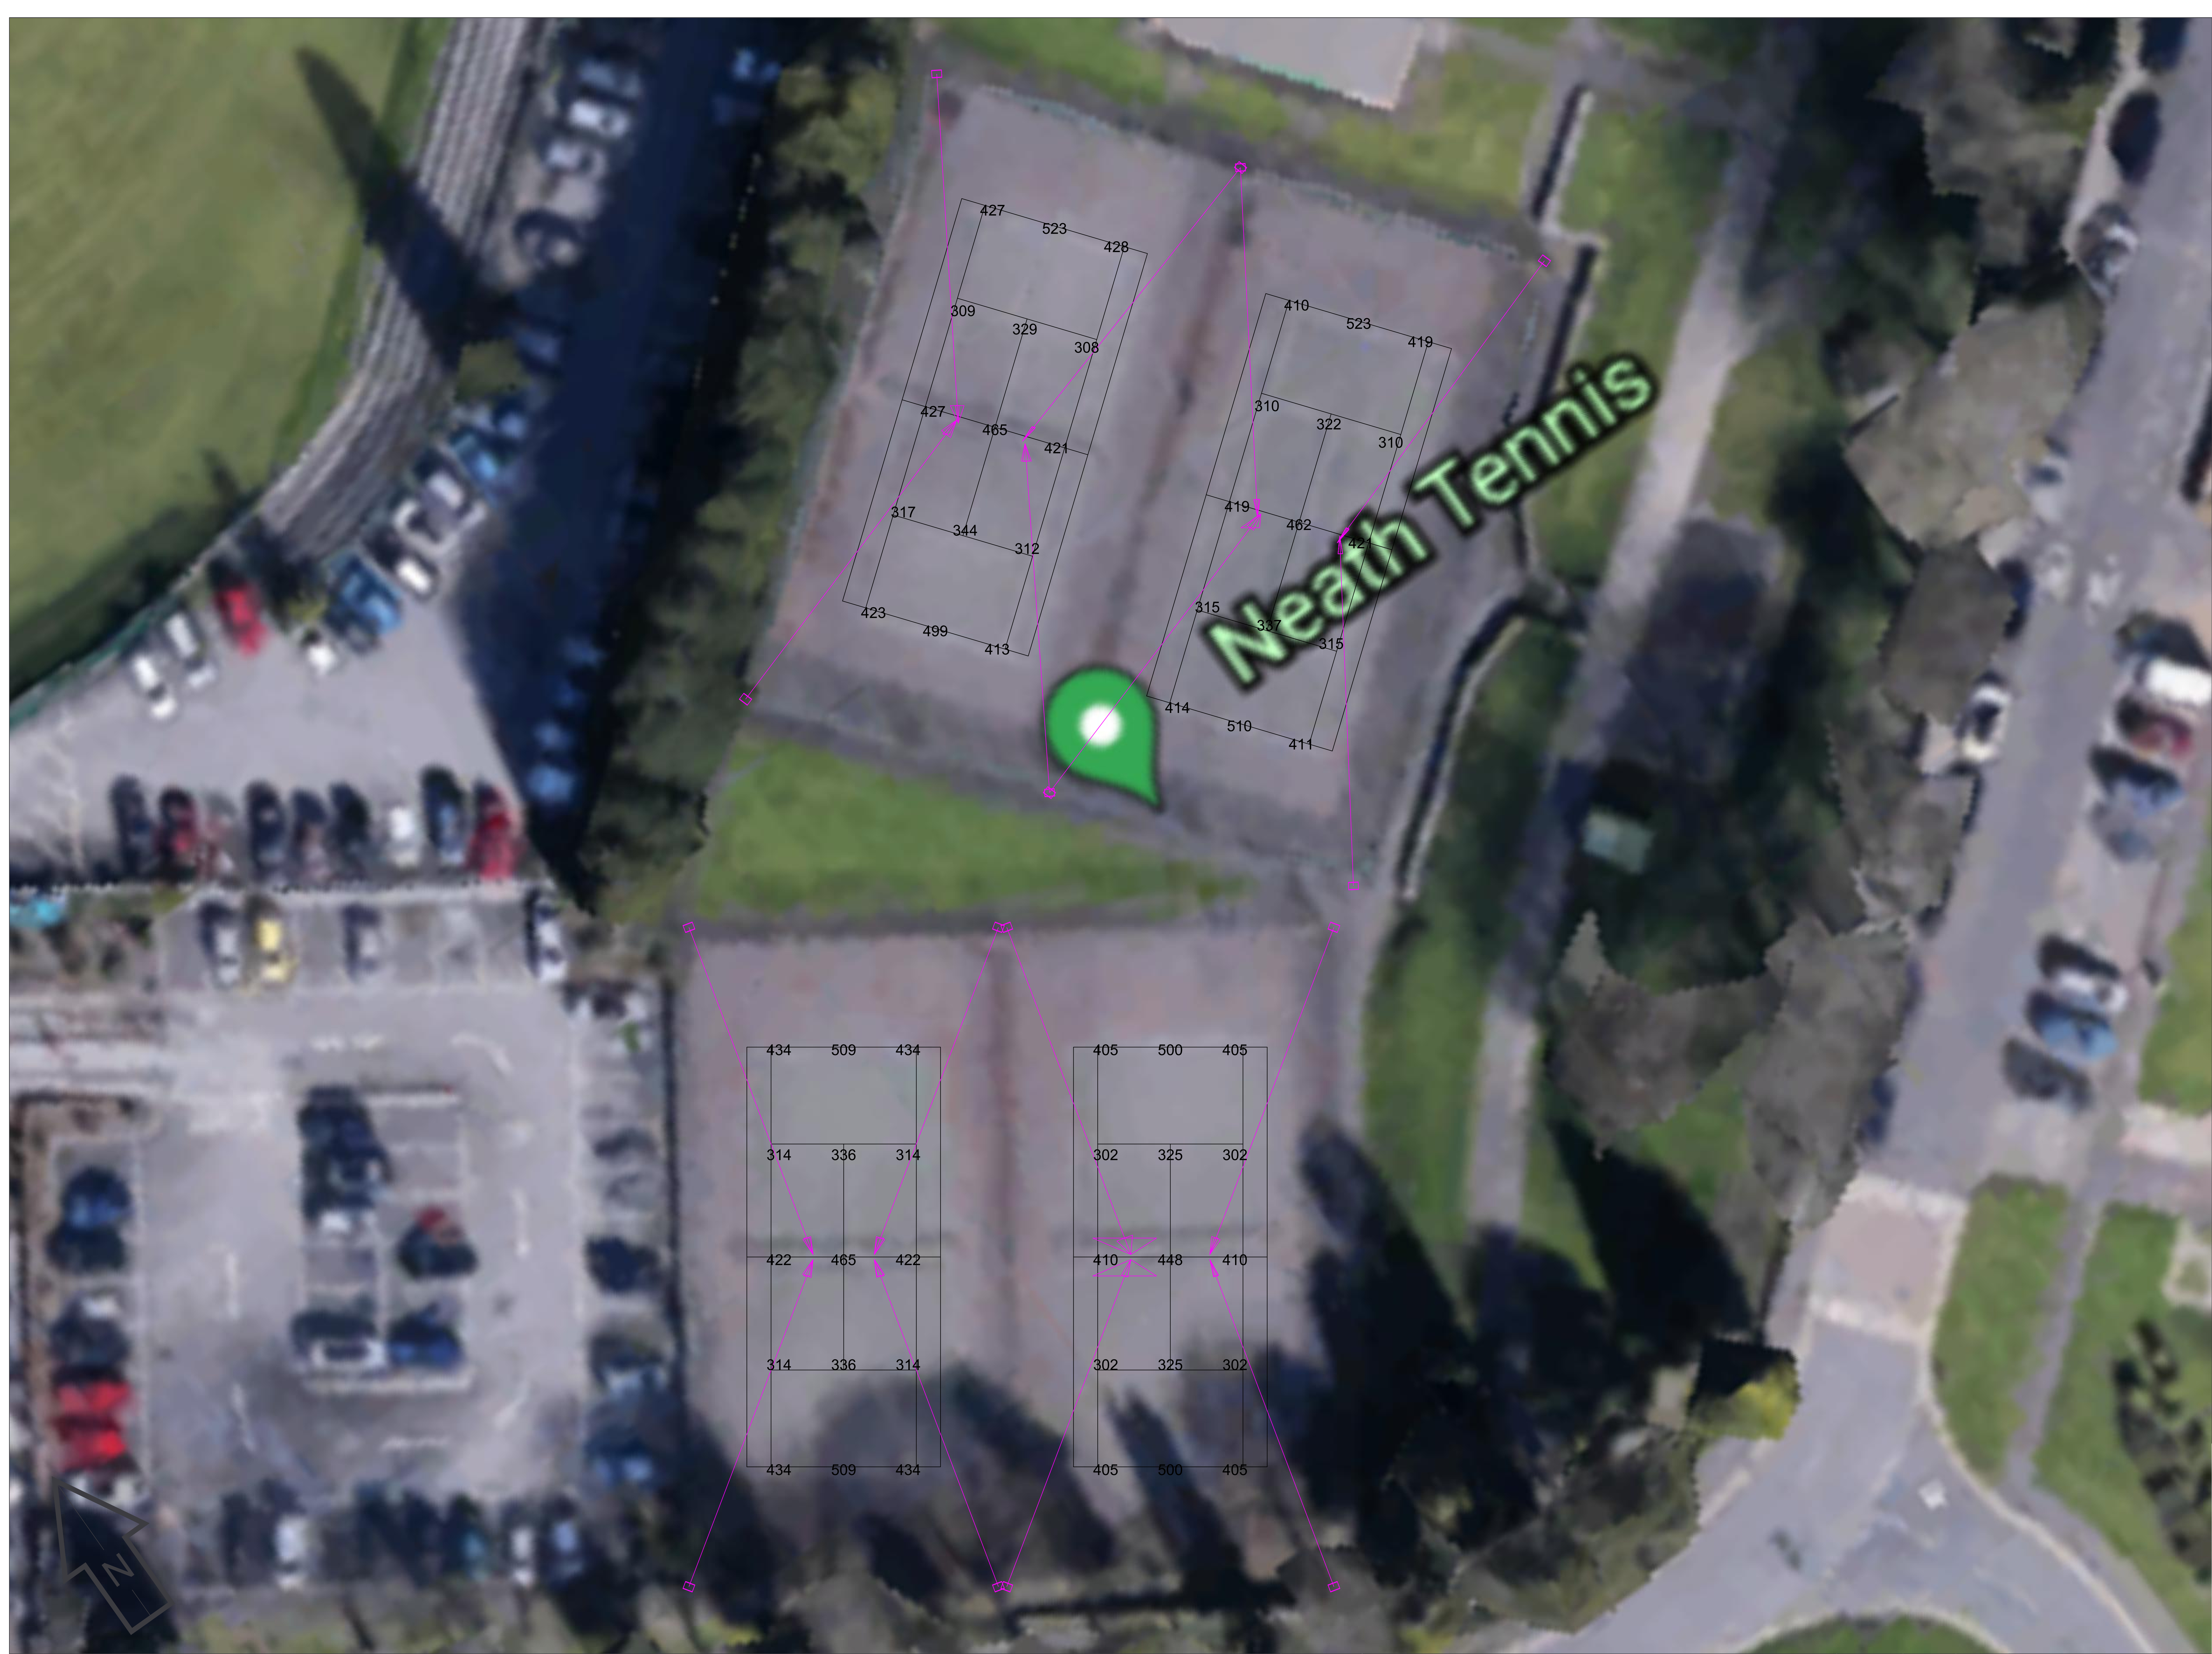

Key:

➔ BVP518 1xLED1480/757 OUT T15 50K A55-NB +LO





- Notes:
- 1) Unless agreed otherwise, the lighting proposal produced by the Lighting Application Specialist (LiAS) team of Philips Lighting UK&I is not intended for construction purposes, as it does not take into account the elimination of health and safety risks at this stage. For further details please refer to sheet number **DWG 00**
 - 2) Do not scale for this drawing


PROPOSAL

(NOT FOR CONSTRUCTION)

Rev	DSR no.	Comment	Date	LiAS	KAM
0	D-415791	Initial proposal.	08/07/21	MD	GP

Project Number	0400634225
Scale & Sheet Size	1:125 @ A0
Sheet No	DWG 01

Project Name	Neath Leisure Centre Tennis Courts
Drawing Name	Primary Playing Area Results

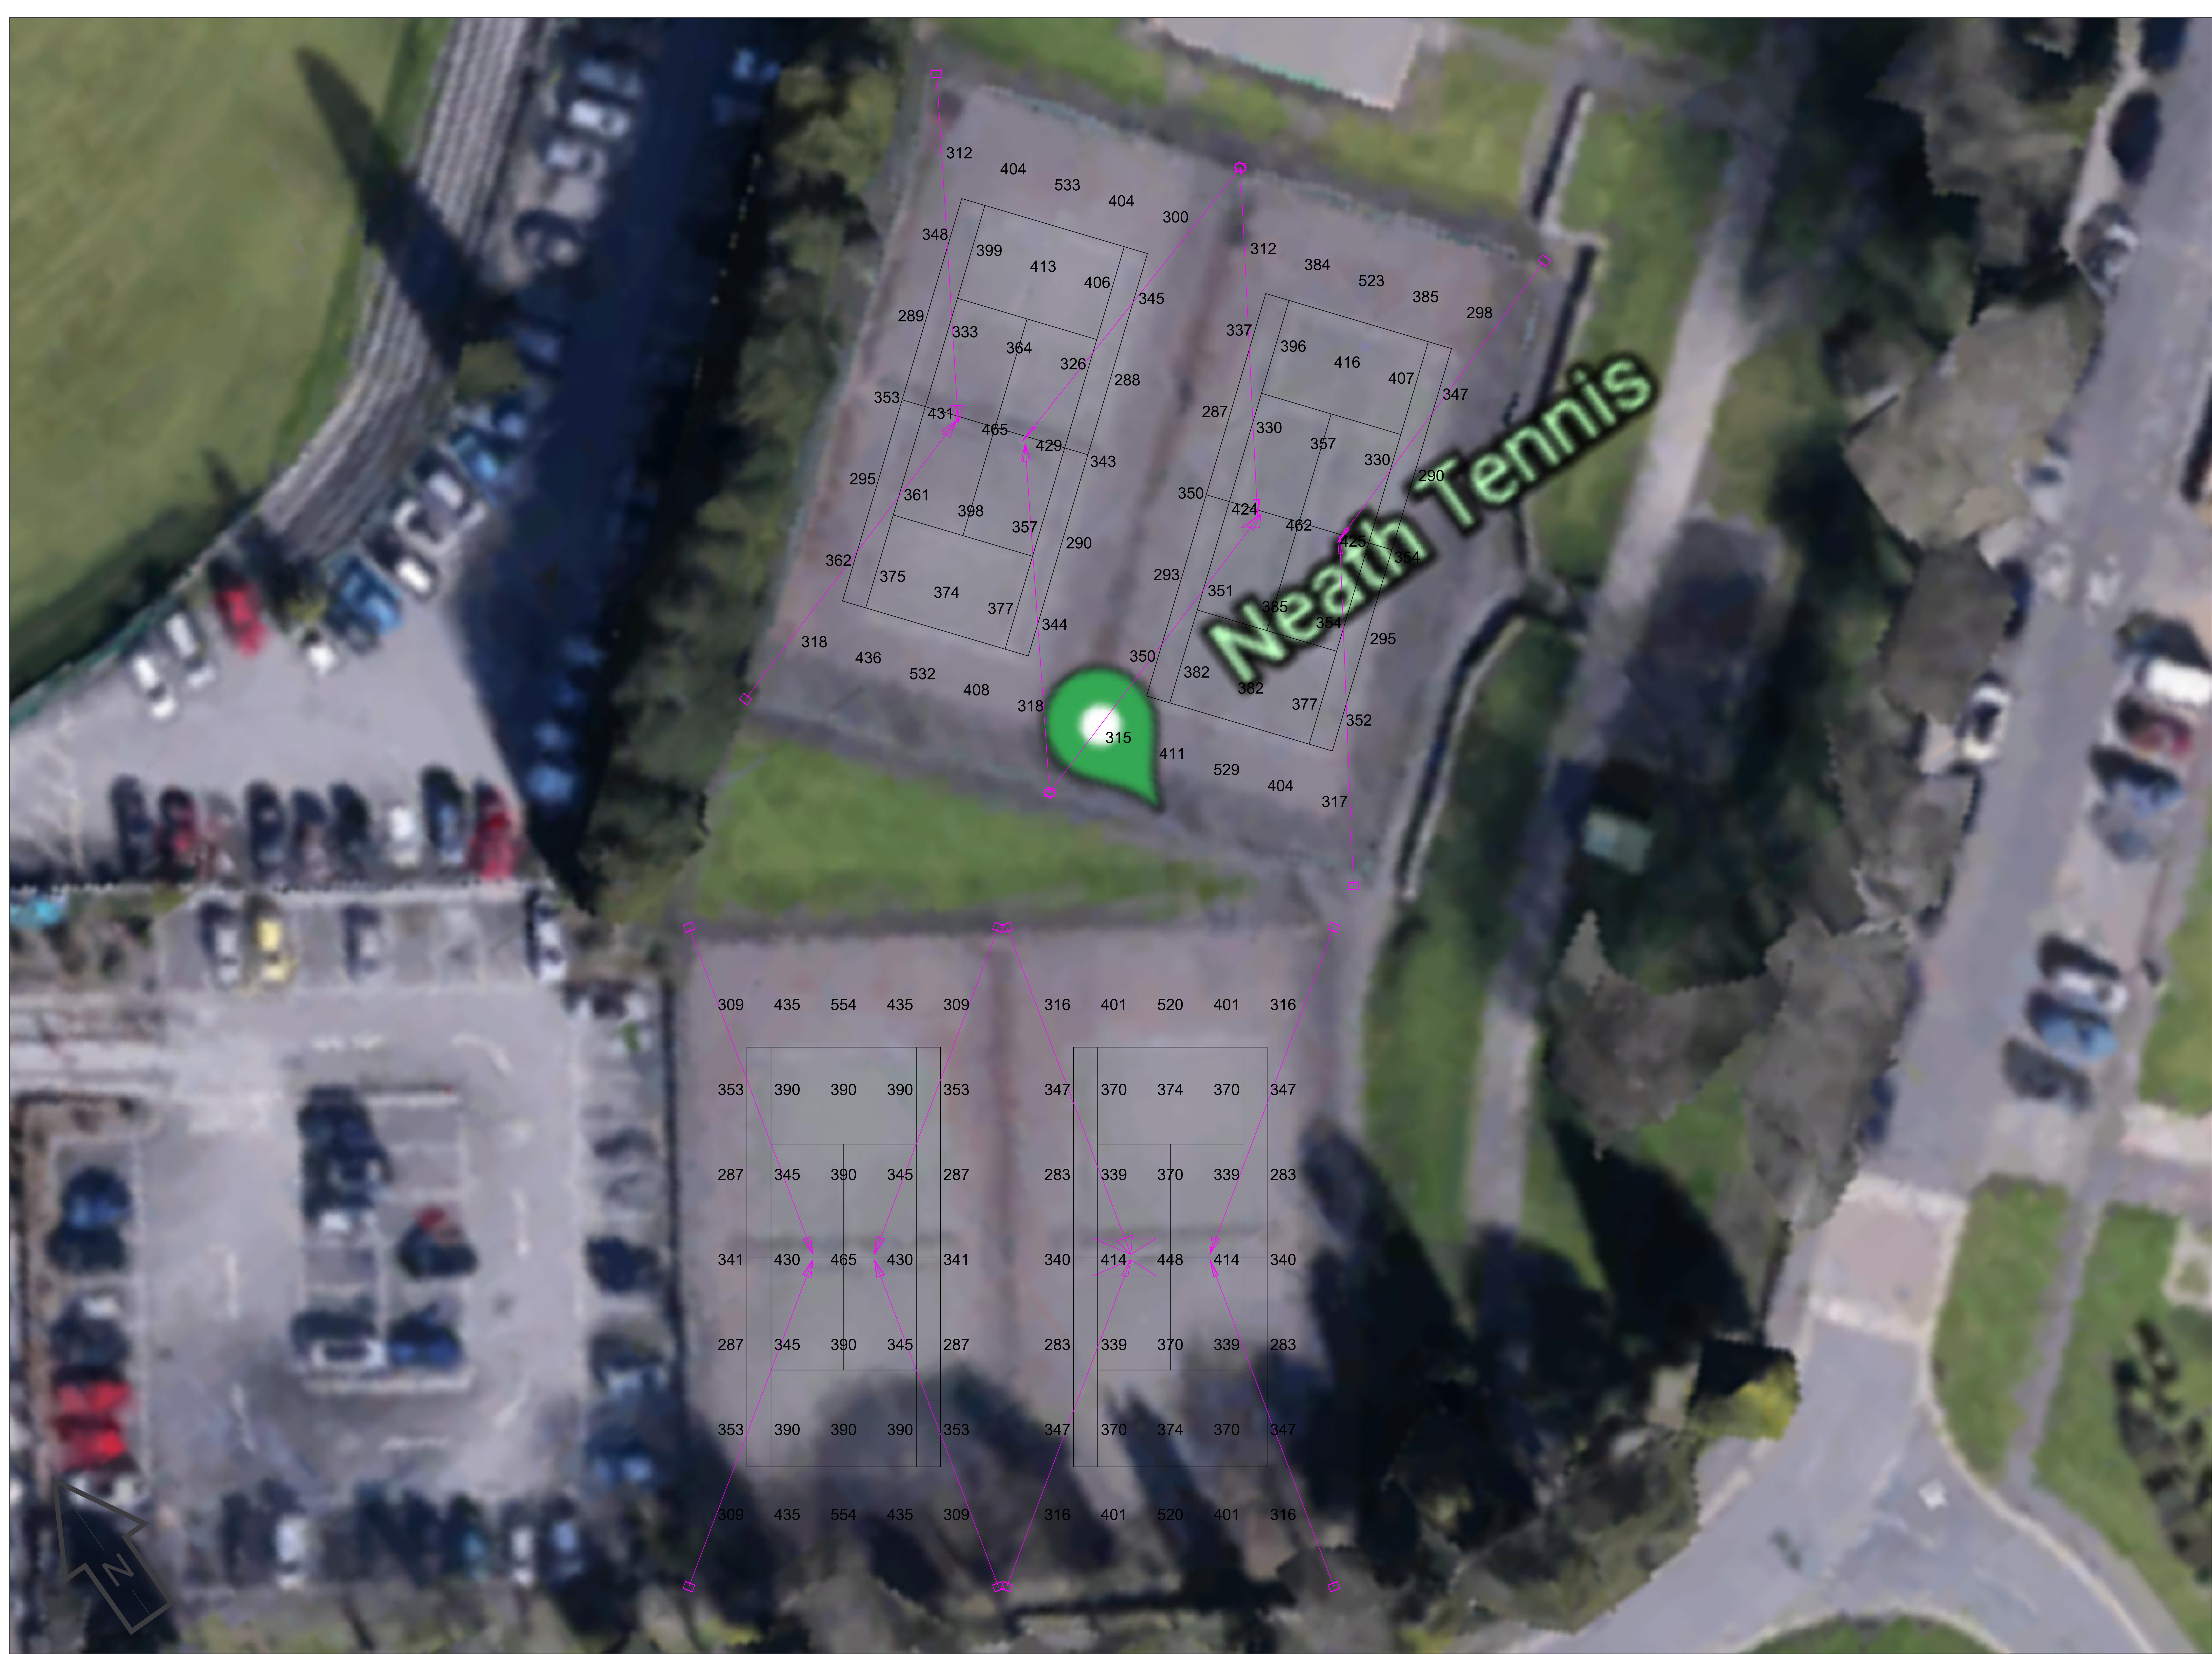

Key:

 BVP518 1xLED1480/757 OUT T15 50K A55-NB +LO







Notes:

- 1) Unless agreed otherwise, the lighting proposal produced by the Lighting Application Specialist (LiAS) team of Philips Lighting UK&I is not intended for construction purposes, as it does not take into account the elimination of health and safety risks at this stage. For further details please refer to sheet number **DWG 00**
- 2) Do not scale for this drawing


PROPOSAL

(NOT FOR CONSTRUCTION)

Rev	DSR no.	Comment	Date	LIAS	KAM
0	D-415791	Initial proposal.	08/07/21	MD	GP

Project Number	0400634225
Scale & Sheet Size	1:125 @ A0
Sheet No	DWG 02

Project Name	Neath Leisure Centre Tennis Courts
Drawing Name	Total Playing Area Results

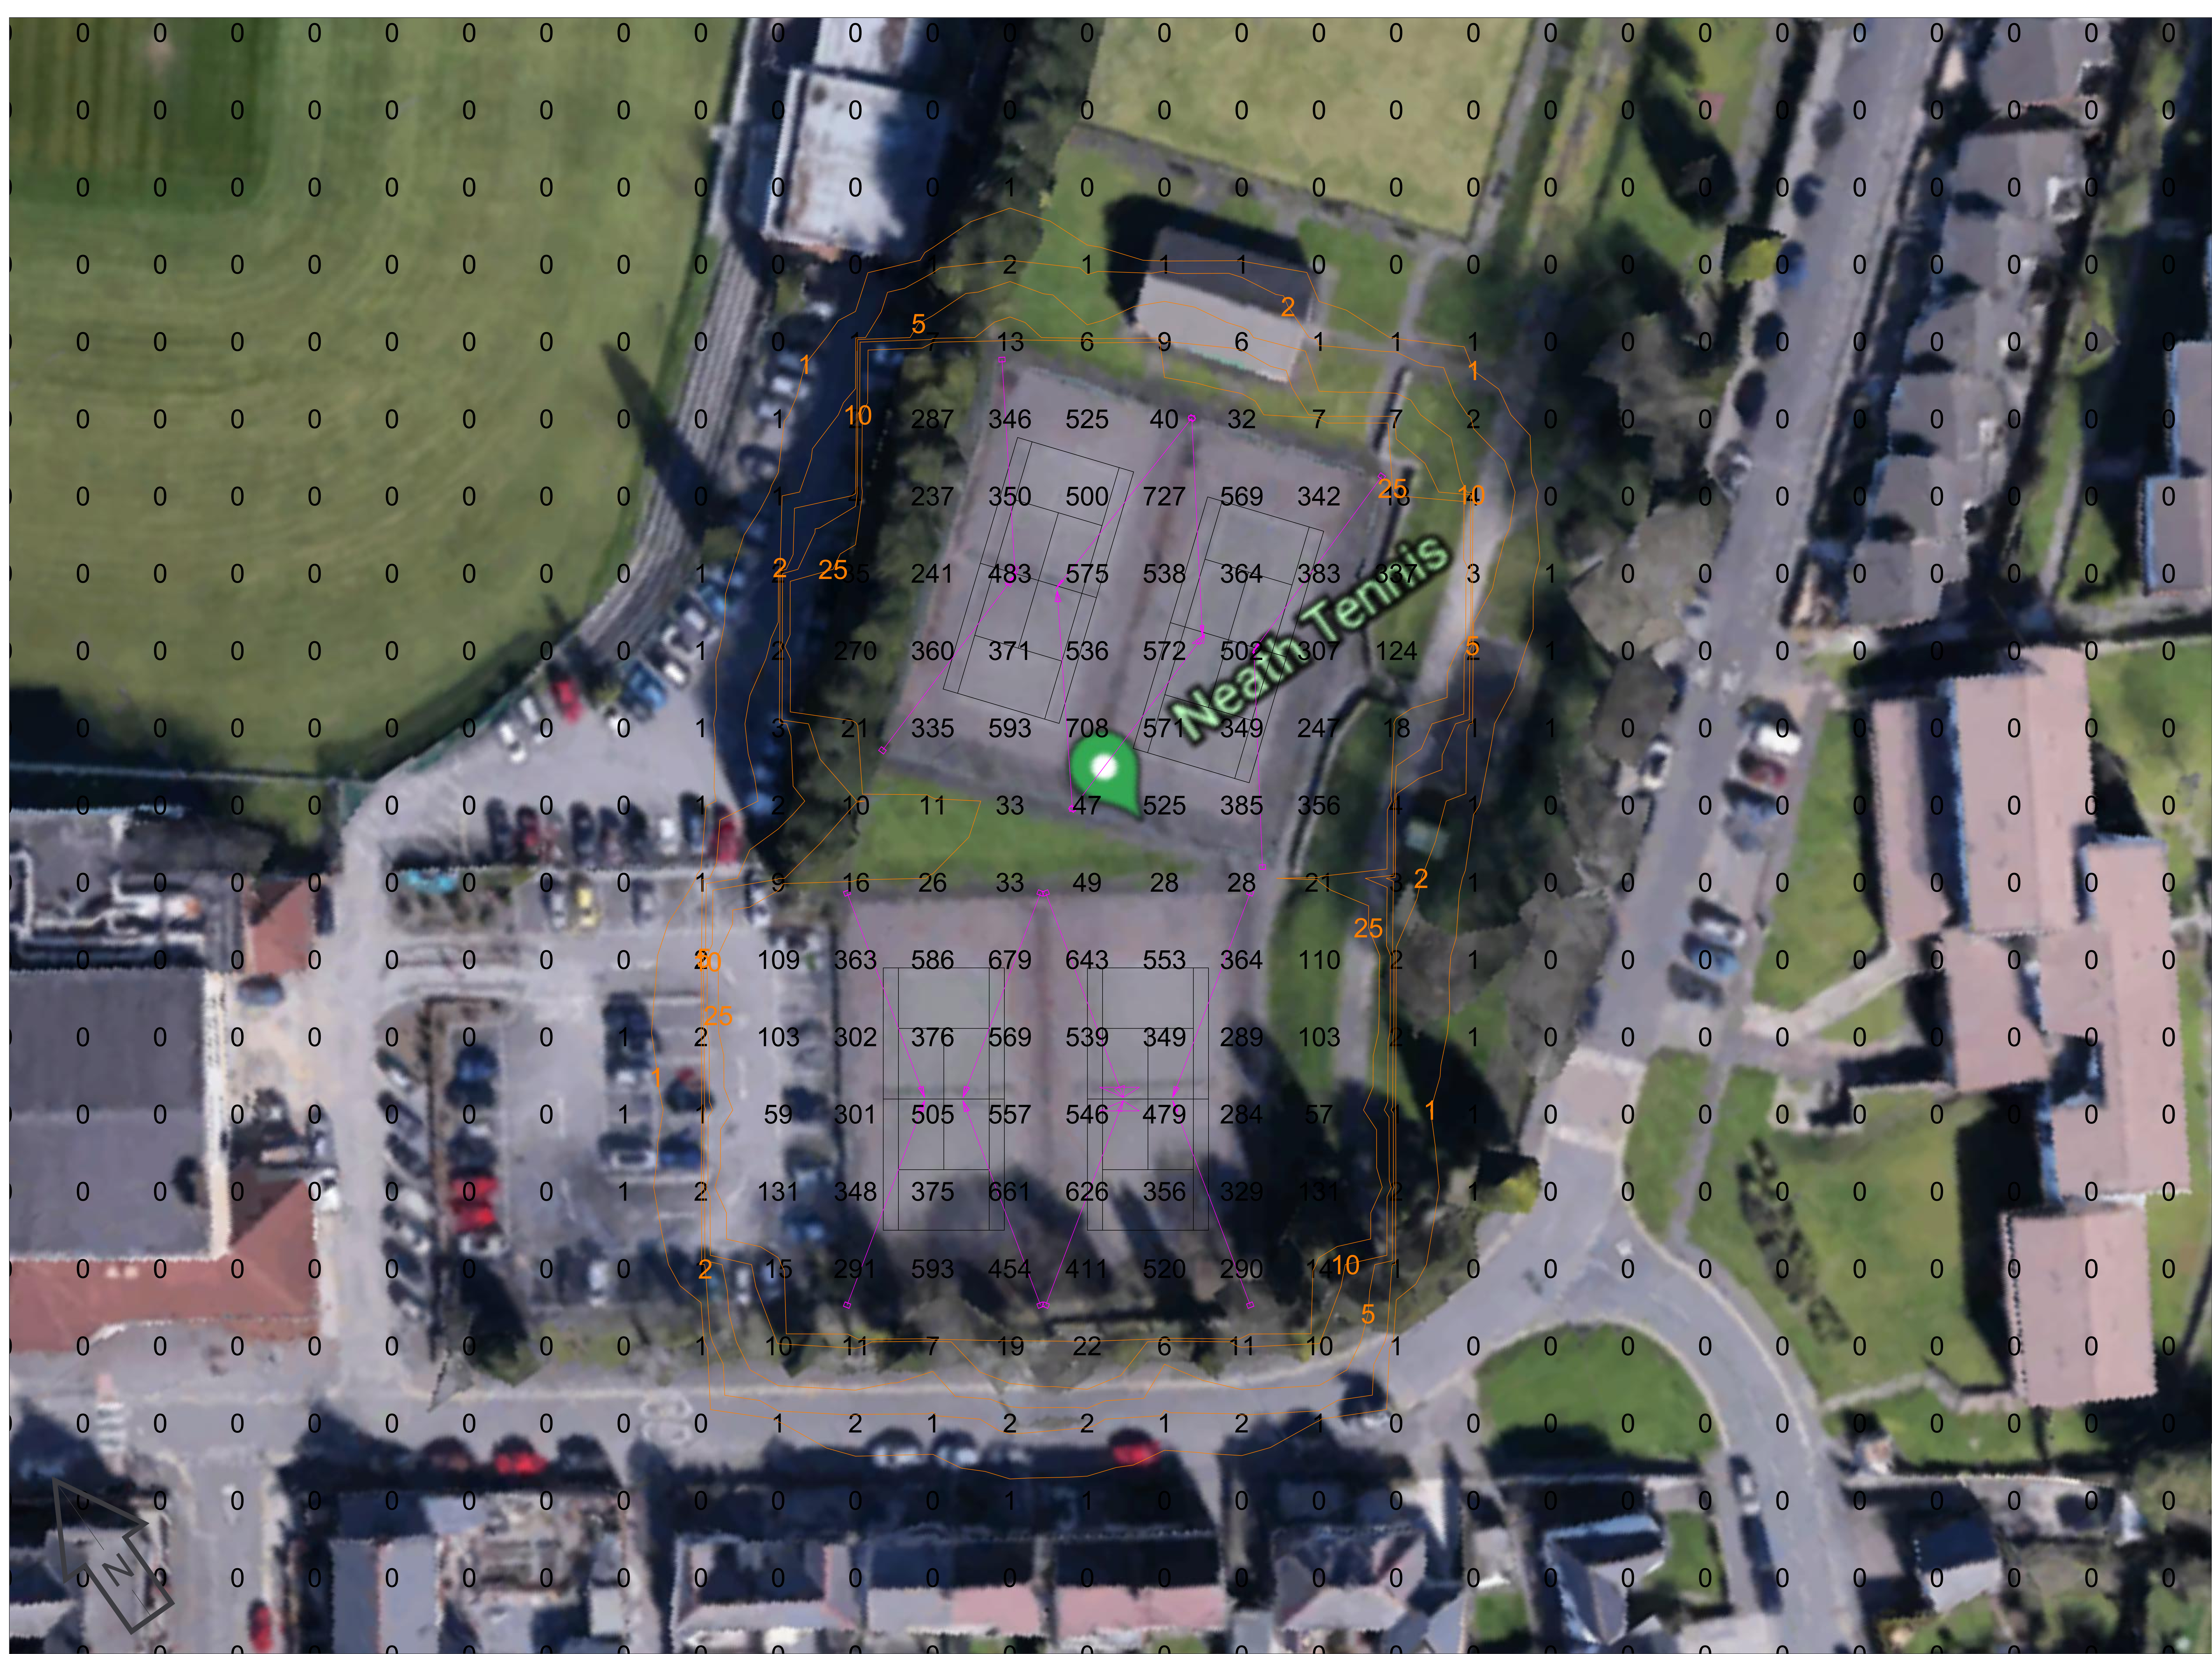

Key:

BVP518 1xLED1480/757 OUT T15 50K A55-NB +LO

Notes:

1) Unless agreed otherwise, the lighting proposal produced by the Lighting Application Specialist (LiAS) team of Philips Lighting UK&I is not intended for construction purposes, as it does not take into account the elimination of health and safety risks at this stage. For further details please refer to sheet number **DWG 00**

2) Do not scale for this drawing

PROPOSAL

(NOT FOR CONSTRUCTION)

Rev	DSR no.	Comment	Date	LIAS	KAM
0	D-415791	Initial proposal.	08/07/21	MD	GP

Project Number	0400634225
Scale & Sheet Size	1:200 @ A0
Sheet No	DWG 02

Project Name	Neath Leisure Centre Tennis Courts
Drawing Name	Spill Light @ 0m