


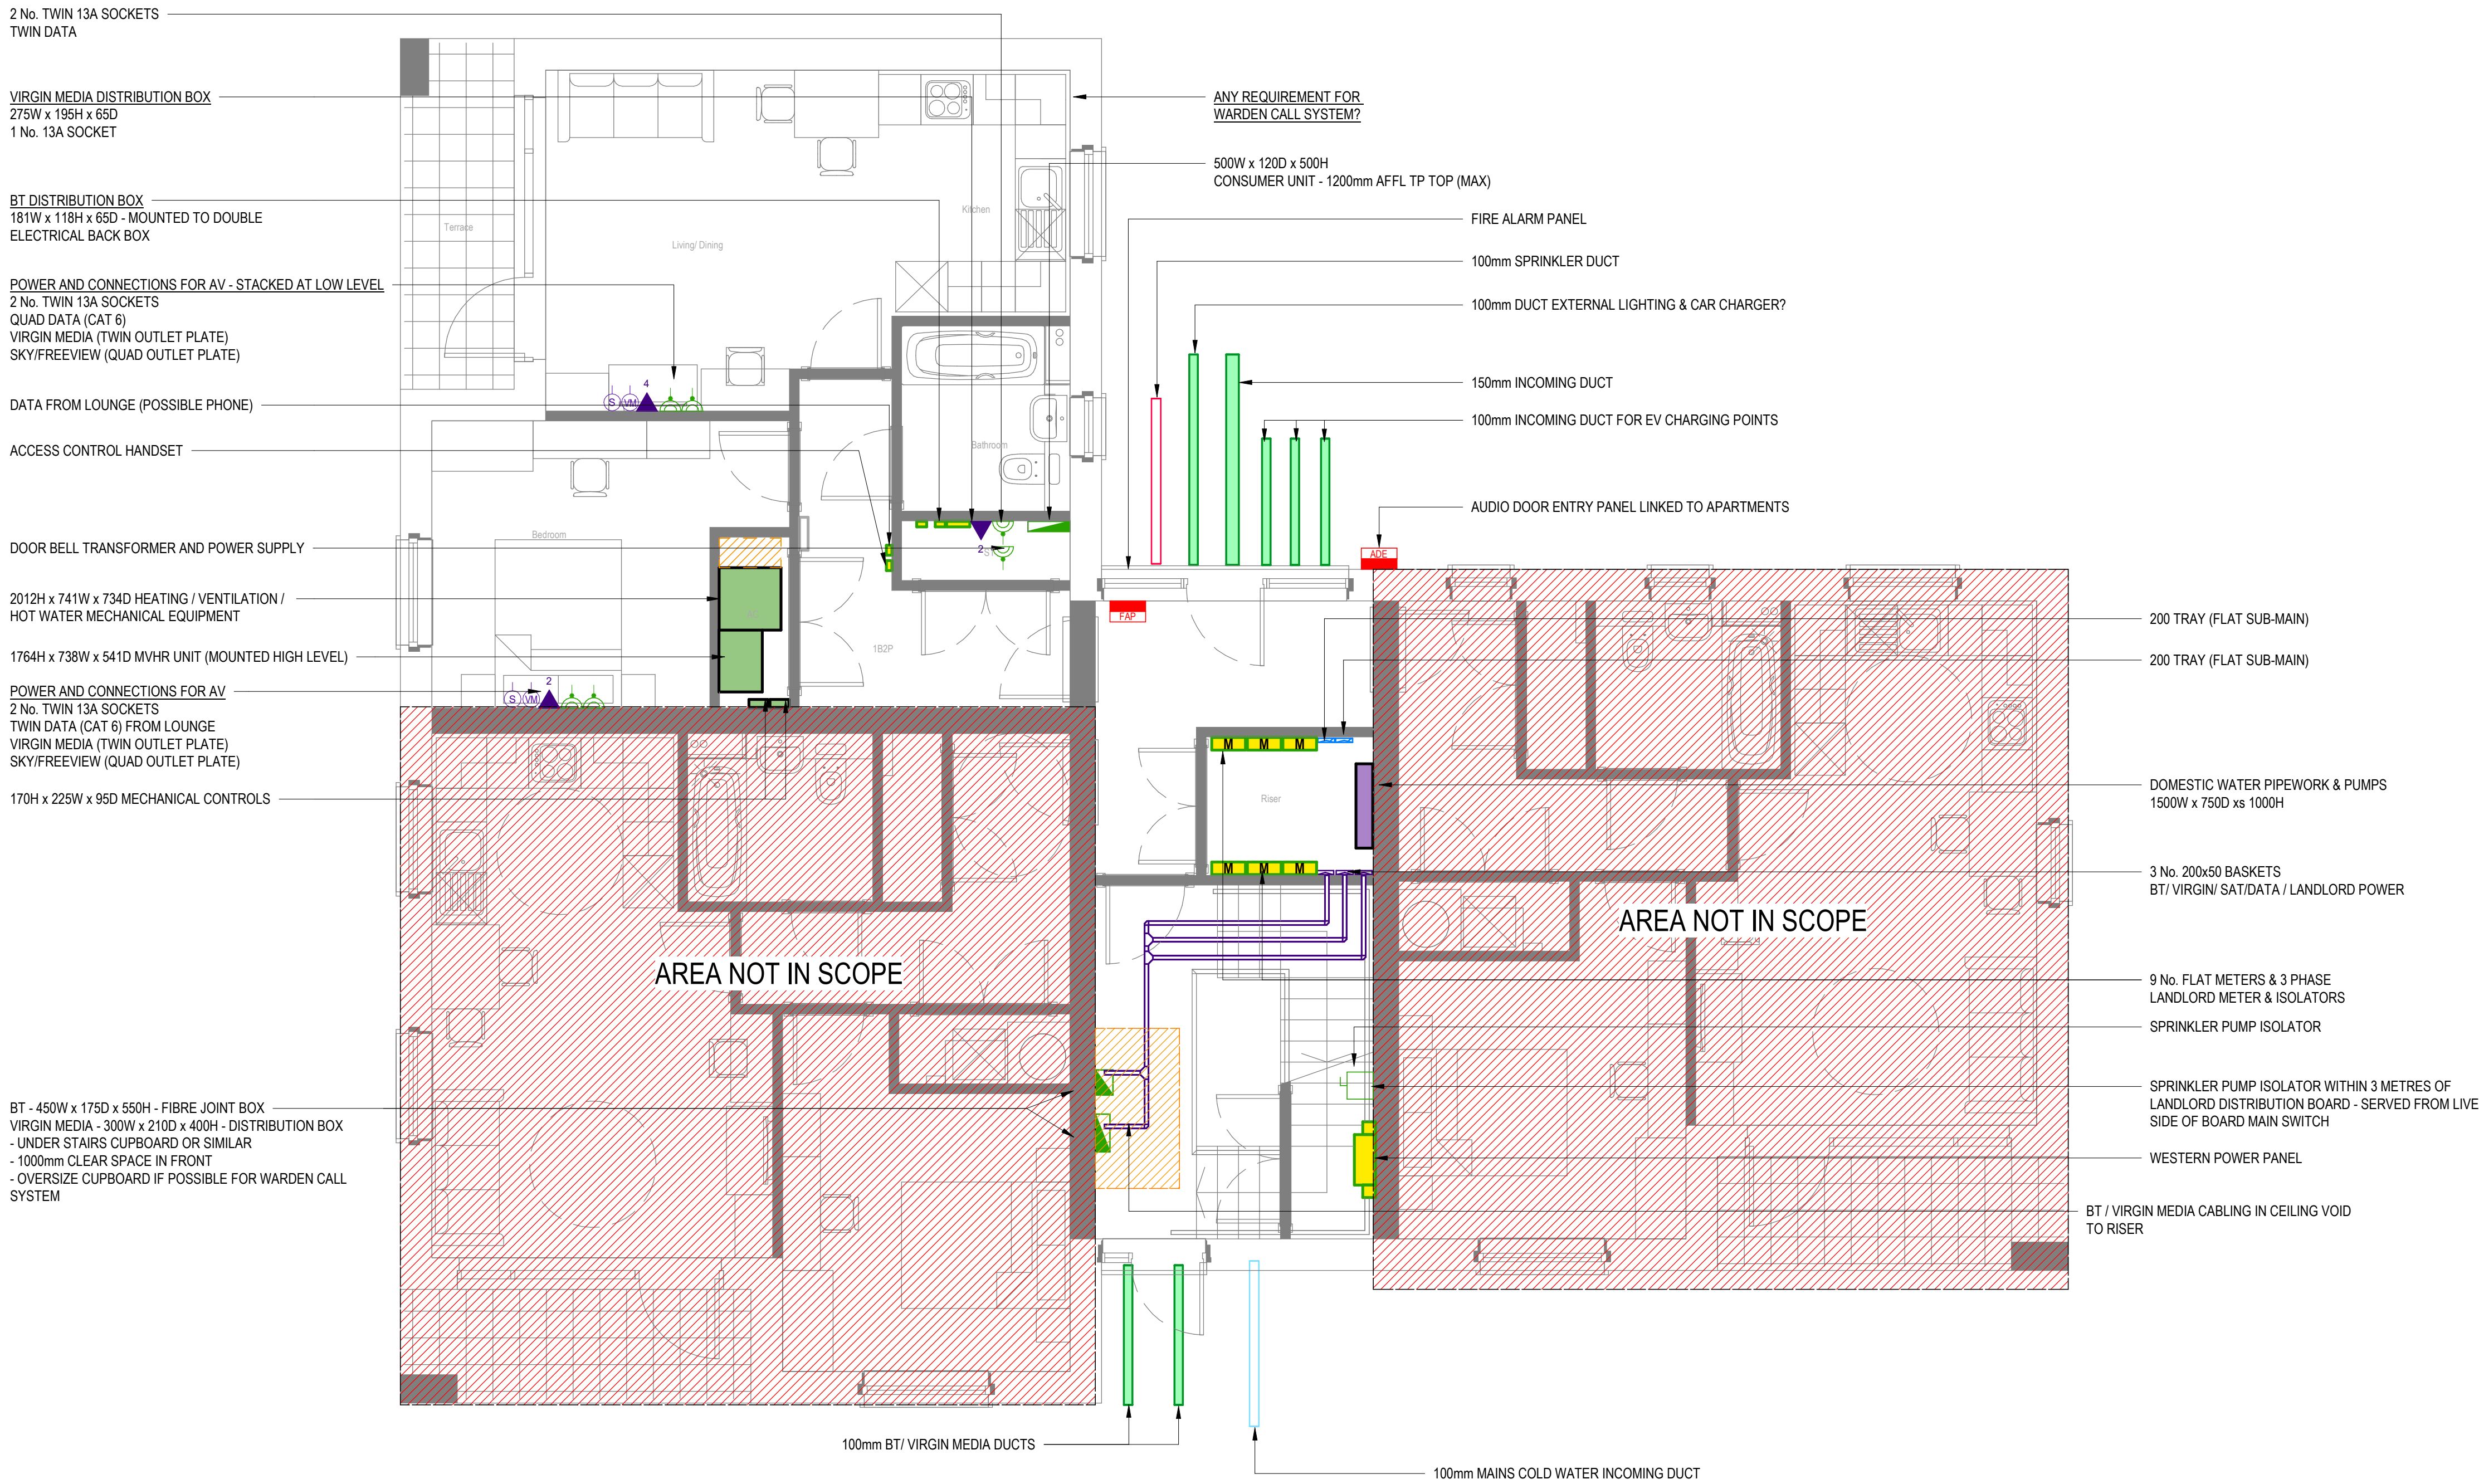

GROUND FLOOR PLAN

This Drawing is protected by Copyright. It may not be reproduced in any form or by any means for any purpose without the written consent of Services Design Solution Limited. Do not scale. All Dimensions to be checked on Site and verified prior to commencing Works / Manufacture. Any discrepancies to be reported to Services Design Solution Limited. These Drawings reflect the layouts for the purposes of design only. The Contractor shall be responsible for producing their own Working and Coordination drawings prior to commencing their installations. If these drawings are used for Construction purposes it is done so at the Contractor's Risk.



Legend

- Distribution Board
- 13 Amp 230V Twin Switched Socket Outlet (Recessed Mounted)
- Isolator
- 2 RJ45 Data Outlet
2 = Twin Outlet
4 = Quad Outlet
5 = Quint Outlet
- Virgin Media Outlet (Twin Plate)
- Sky/ Freeview Outlet (Quad Plate)
- Area Not In SDS's Scope Of Works
- Mechanical Services
- Domestic Water Pipework & Pumps
- Mechanical Heating Services

P03	Preliminary Issue	RH / LYM / PM	28/06/22
P02	Preliminary Issue - WIP	RR / LYM / PM	09/06/22
P01	Preliminary Issue	RH / LYM / PM	03/05/22
Rev	Details	By / Chkd / App:	Date:



SERVICES DESIGN SOLUTION LIMITED
Units 5 & 6, Westfield Park
Creswell Bristol, BS21 6UA
Tel: +44 (0) 1275 872963 | www.sdsolution.co.uk



PROJECT TITLE
LCHA Devonshire Place
1B2P Apartments

DRAWING TITLE
Combined Services
Ground Floor

SCALE AT A1
1 : 50

DISCIPLINE
Combined

DRAWING NUMBER
06485B-SDS-XX-00-SK-N-9020-01

Project - Originator - Zone - Level - Type - Role - NBS Class - Sequential Number
SUITABILITY
S3

ISSUE
P03