
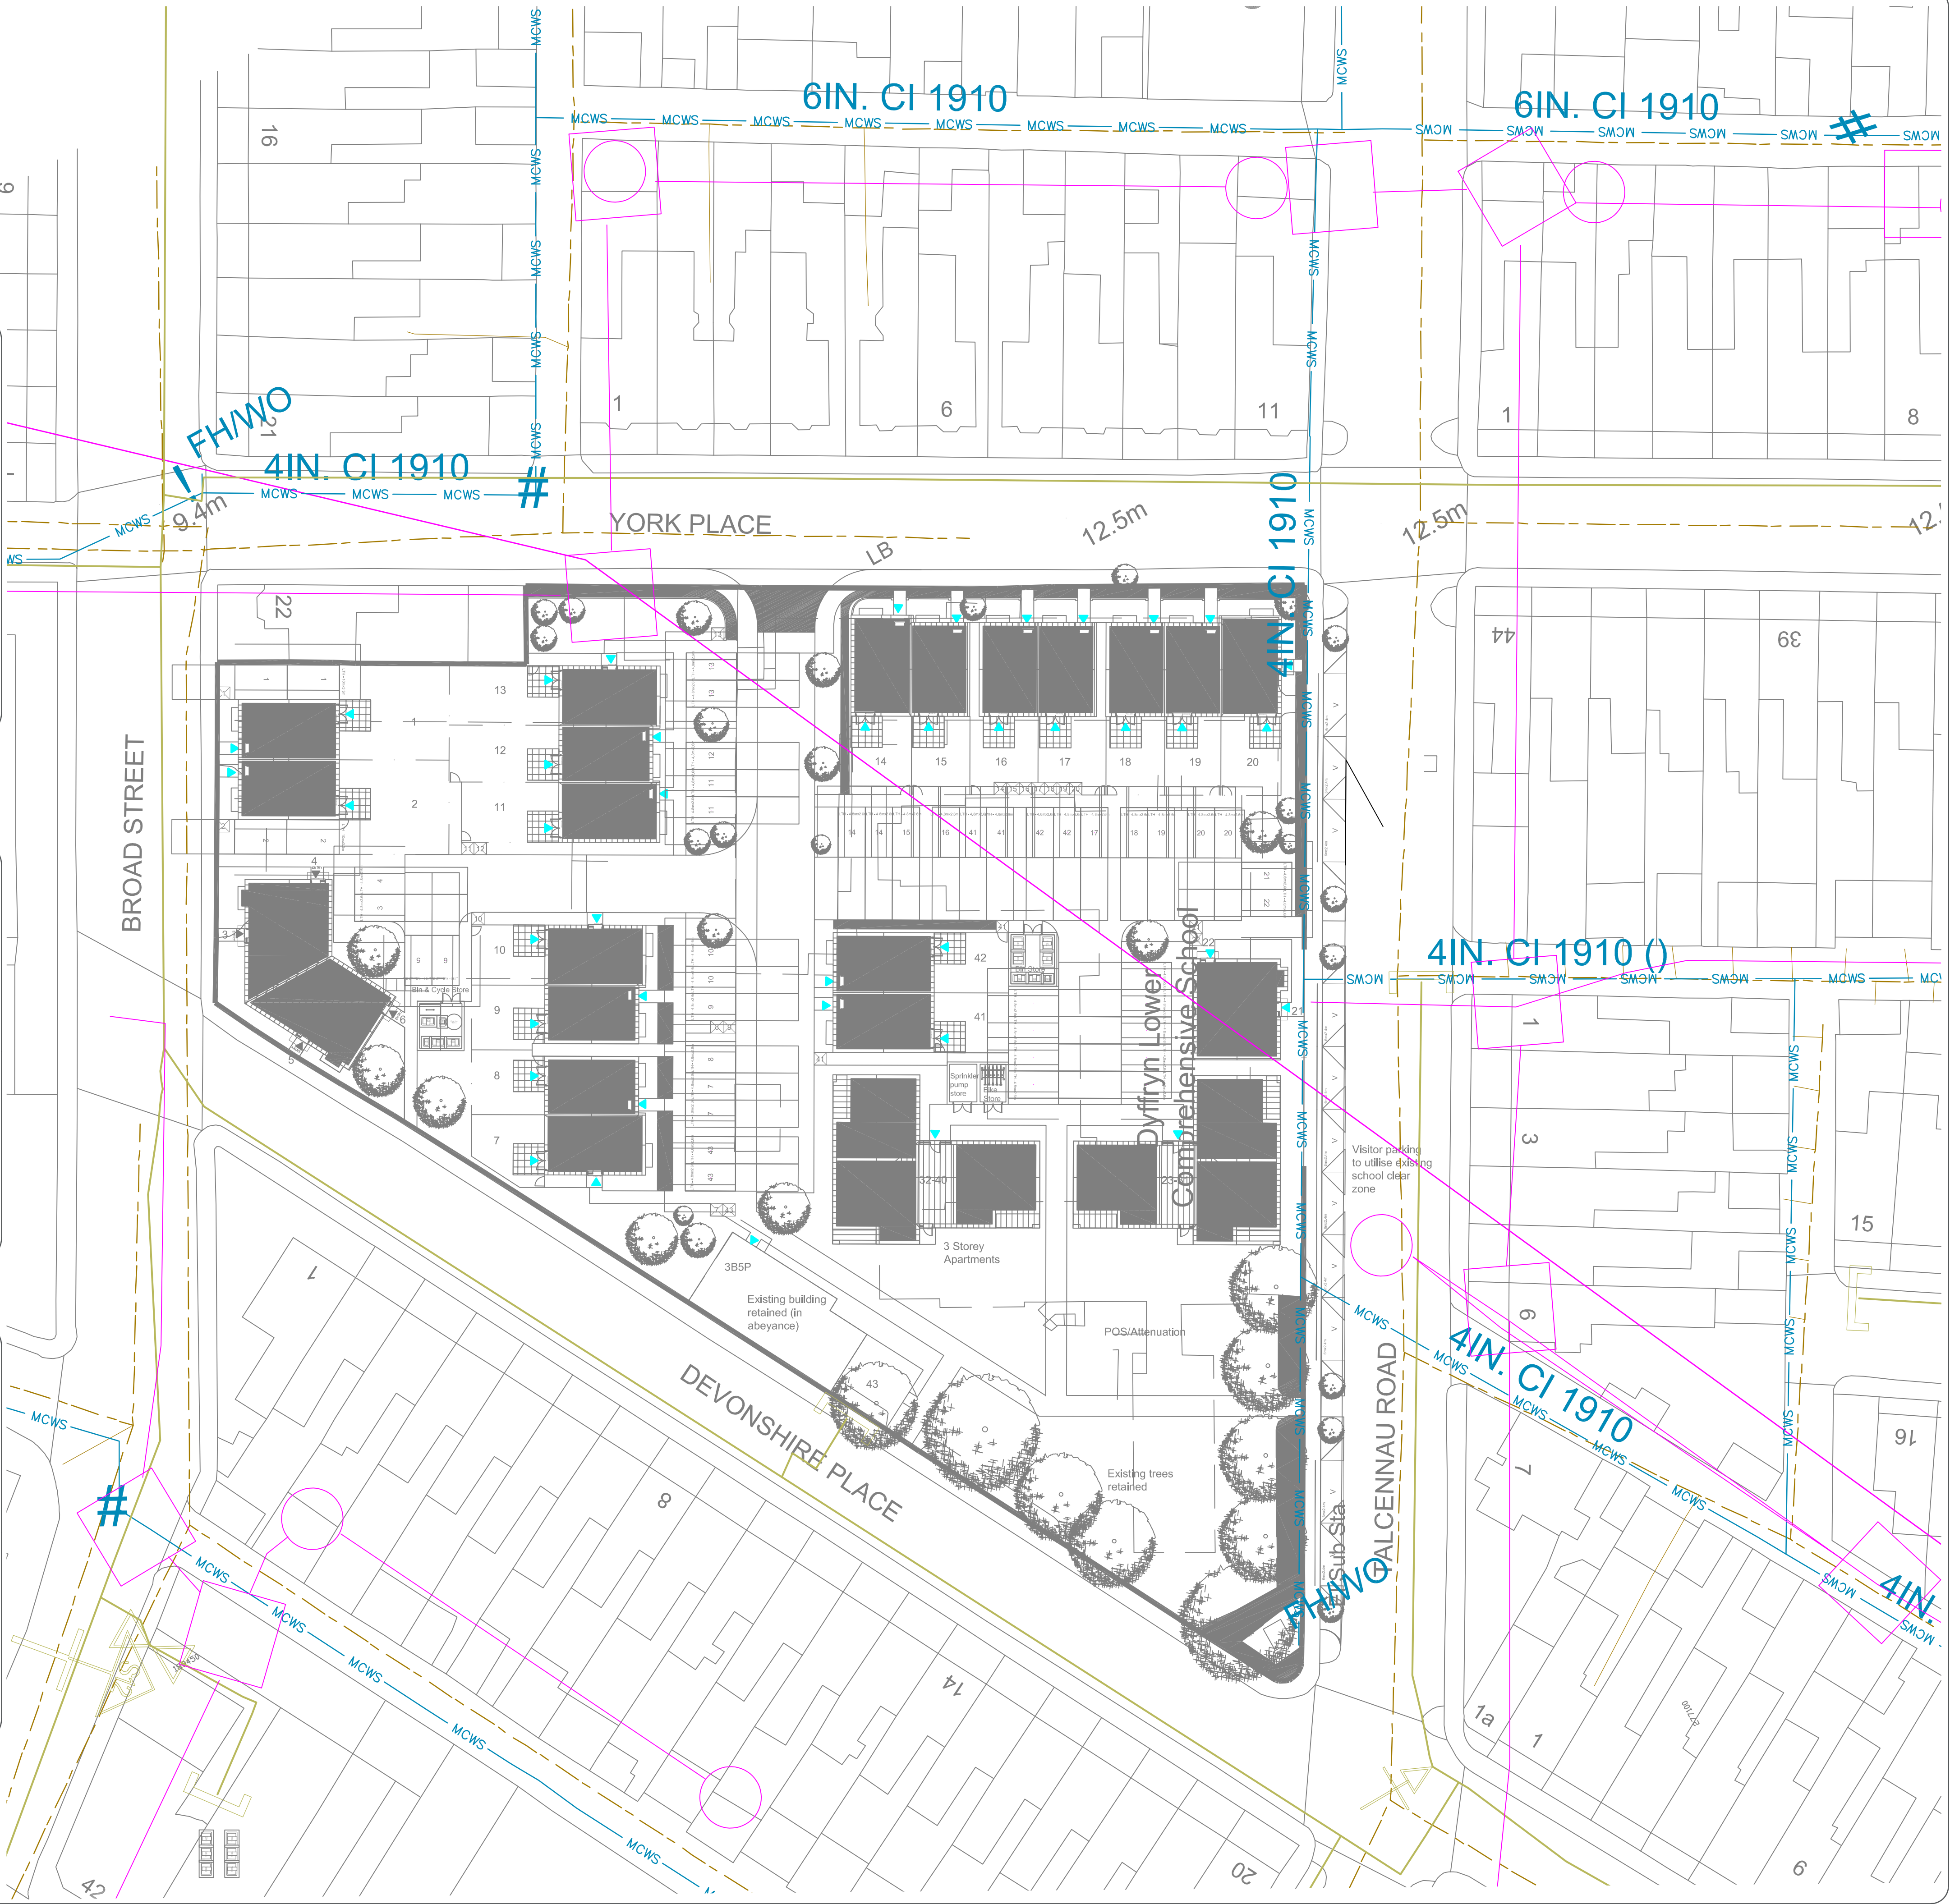
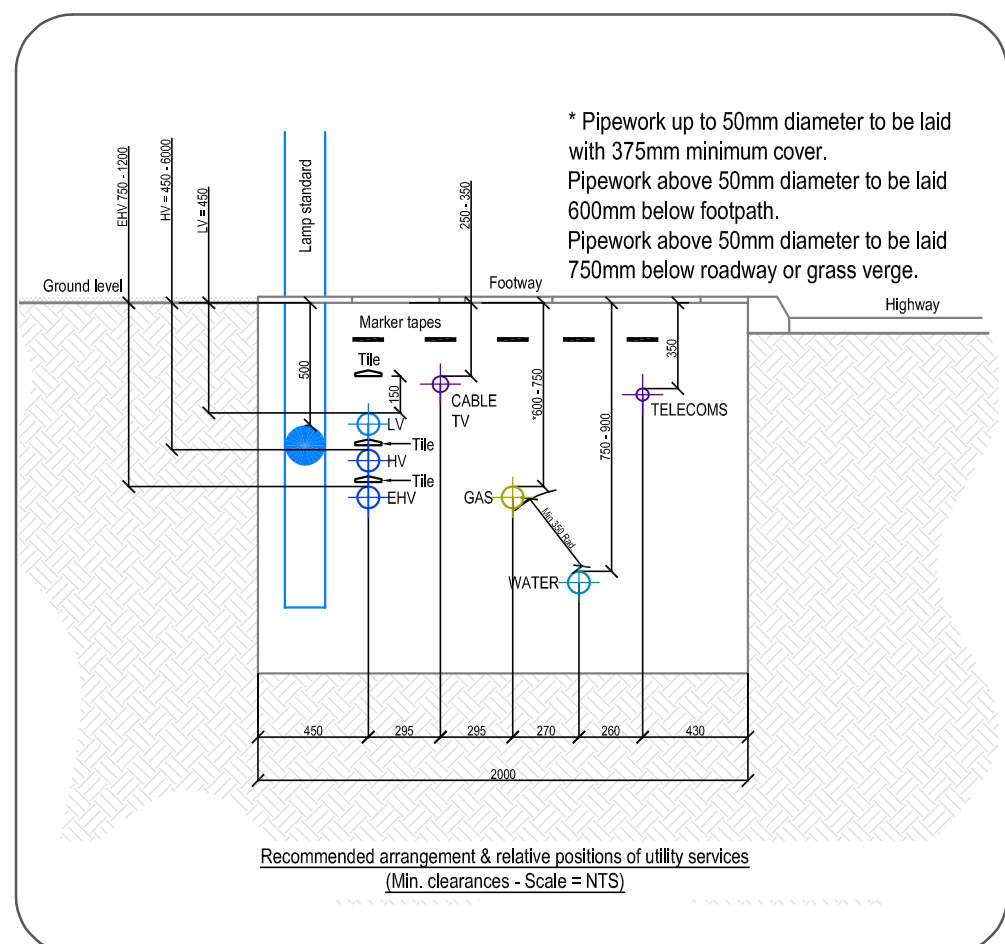
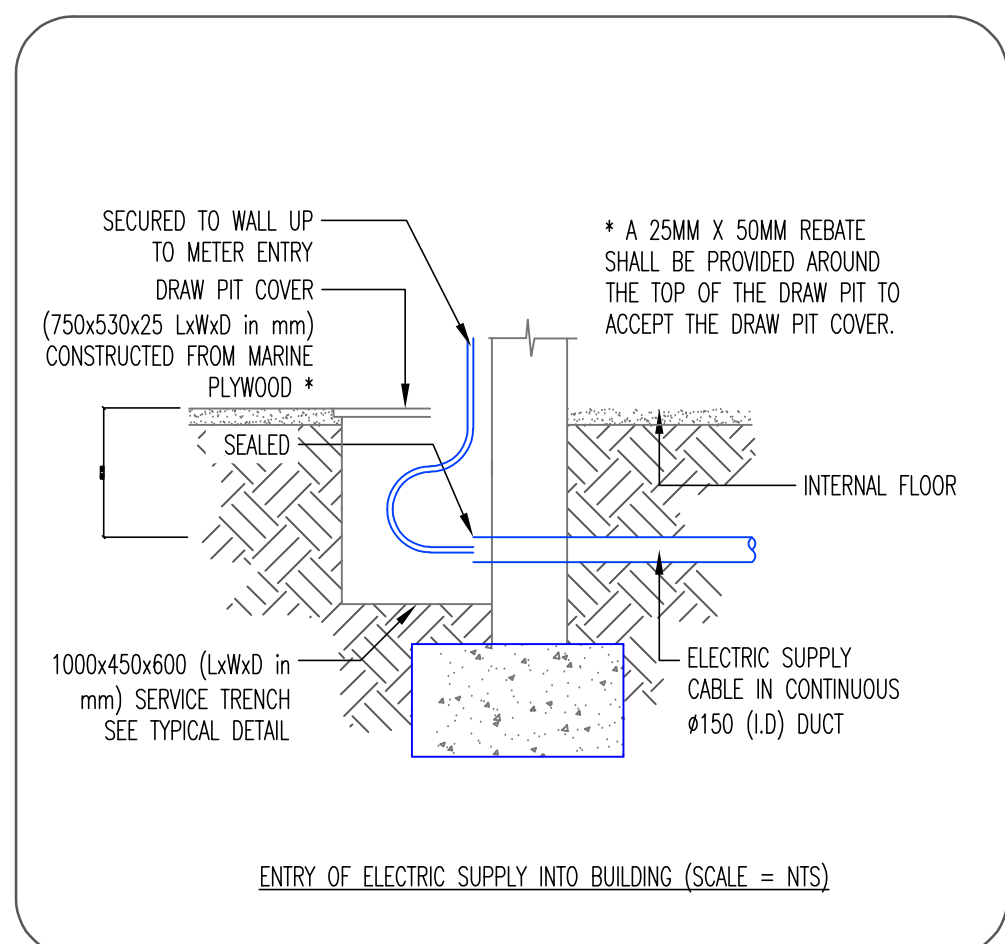


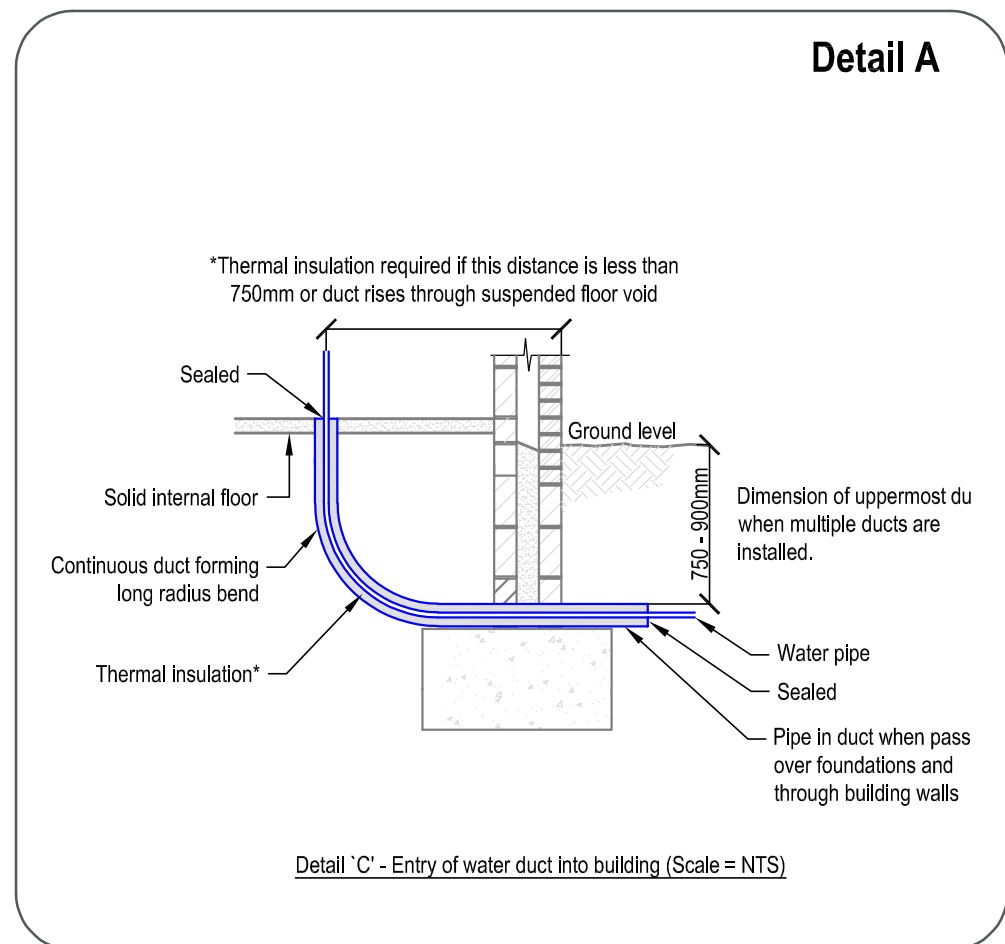


This Drawing is protected by Copyright. It may not be reproduced in any form or by any means for any purpose without the written consent of Services Design Solution Limited. Do not scale. All Dimensions to be checked on site and verified prior to commencing Works / Manufacture. Any discrepancies to be reported to Services Design Solution Limited. These Drawings reflect the layouts for the purposes of design only. The Contractor shall be responsible for producing their own Working and Co-ordination drawings prior to commencing their installations. If these drawings are used for Construction purposes it is done so at the Contractor's Risk.

- Notes.
- Do not scale from this drawing.
 - All measurements are in millimetres unless stated otherwise.
 - This drawing shall be read in conjunction with all relevant Architectural, Structural, Mechanical and Electrical services information.
 - This drawing shall be read in conjunction with RIBA Stage 2 Mechanical and Electrical Report and drawings.

gend

- | | |
|--|----------------------------------|
| LV | EXISTING LV SUPPLY BY CONTRACTOR |
|  HV | EXISTING UKPN HV CABLE - ASSUMED |
|  DATA | EXISTING DATA ROUTE |
| ELV | EXISTING ELV / FIRE ALARM ROUTE |
|  MCWS | EXISTING MCWS |

1	Preliminary Issue	RH/LYM	28/06/22
2	Details:	By / Chkd / App	Date

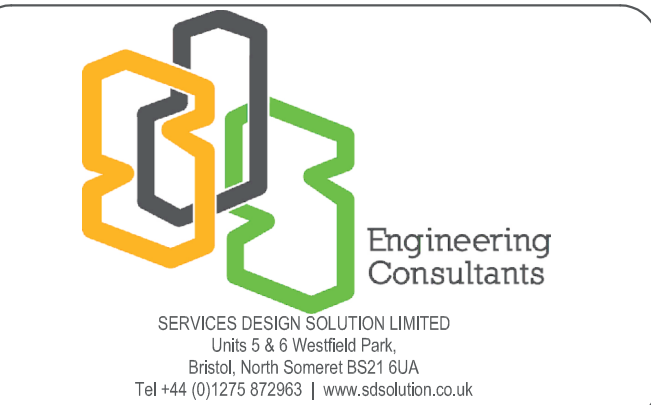

CLIENT

Linc

PROJECT TITLE

LCHA Devonshire Place

DRAWING TITLE
External Services
Site Plan

SCALE AT A1		
1:250		
DISCIPLINE		
DOMESTIC WATER & SPRINKLER LAYOUT		
DRAWING NUMBER		
06485B-SDS-EX-XX-DR-N-3716-01		
Project - Originator - Zone - Level - Type - Role - NBS class - Sequential Number		
STATUS	SUITABILITY	ISSUE
Preliminary	S3	P01