
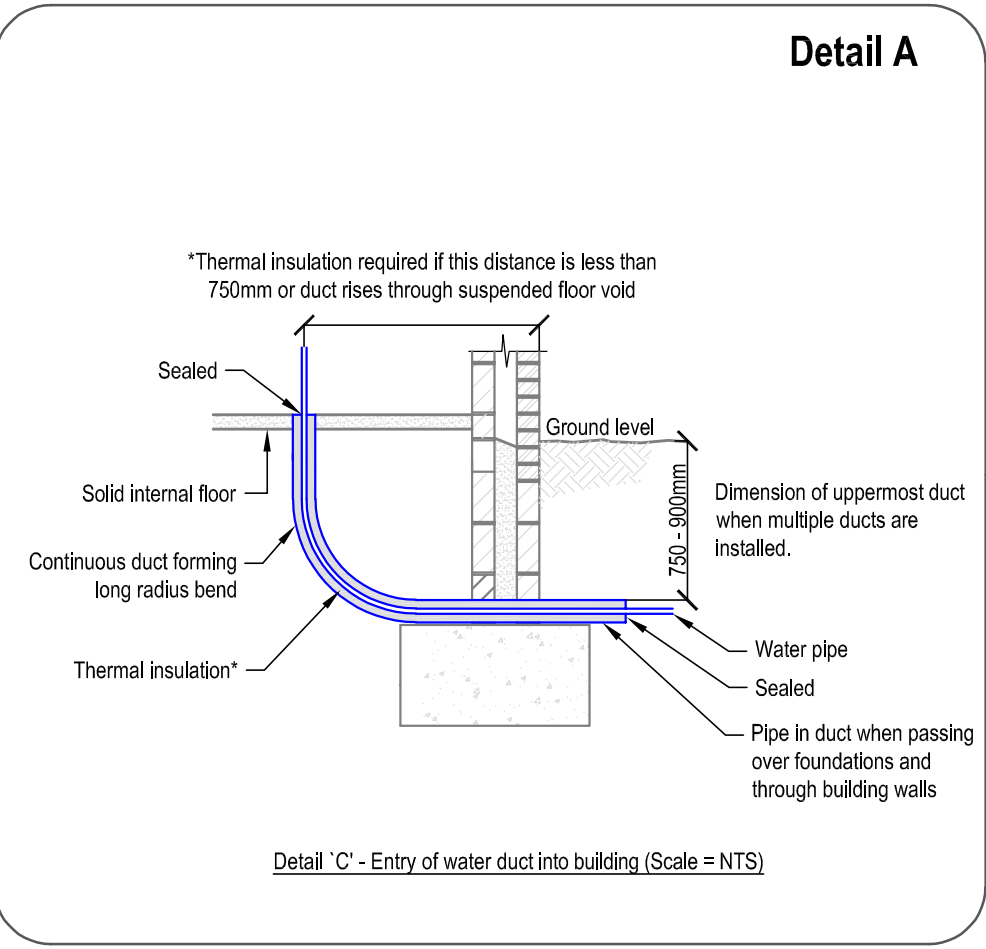


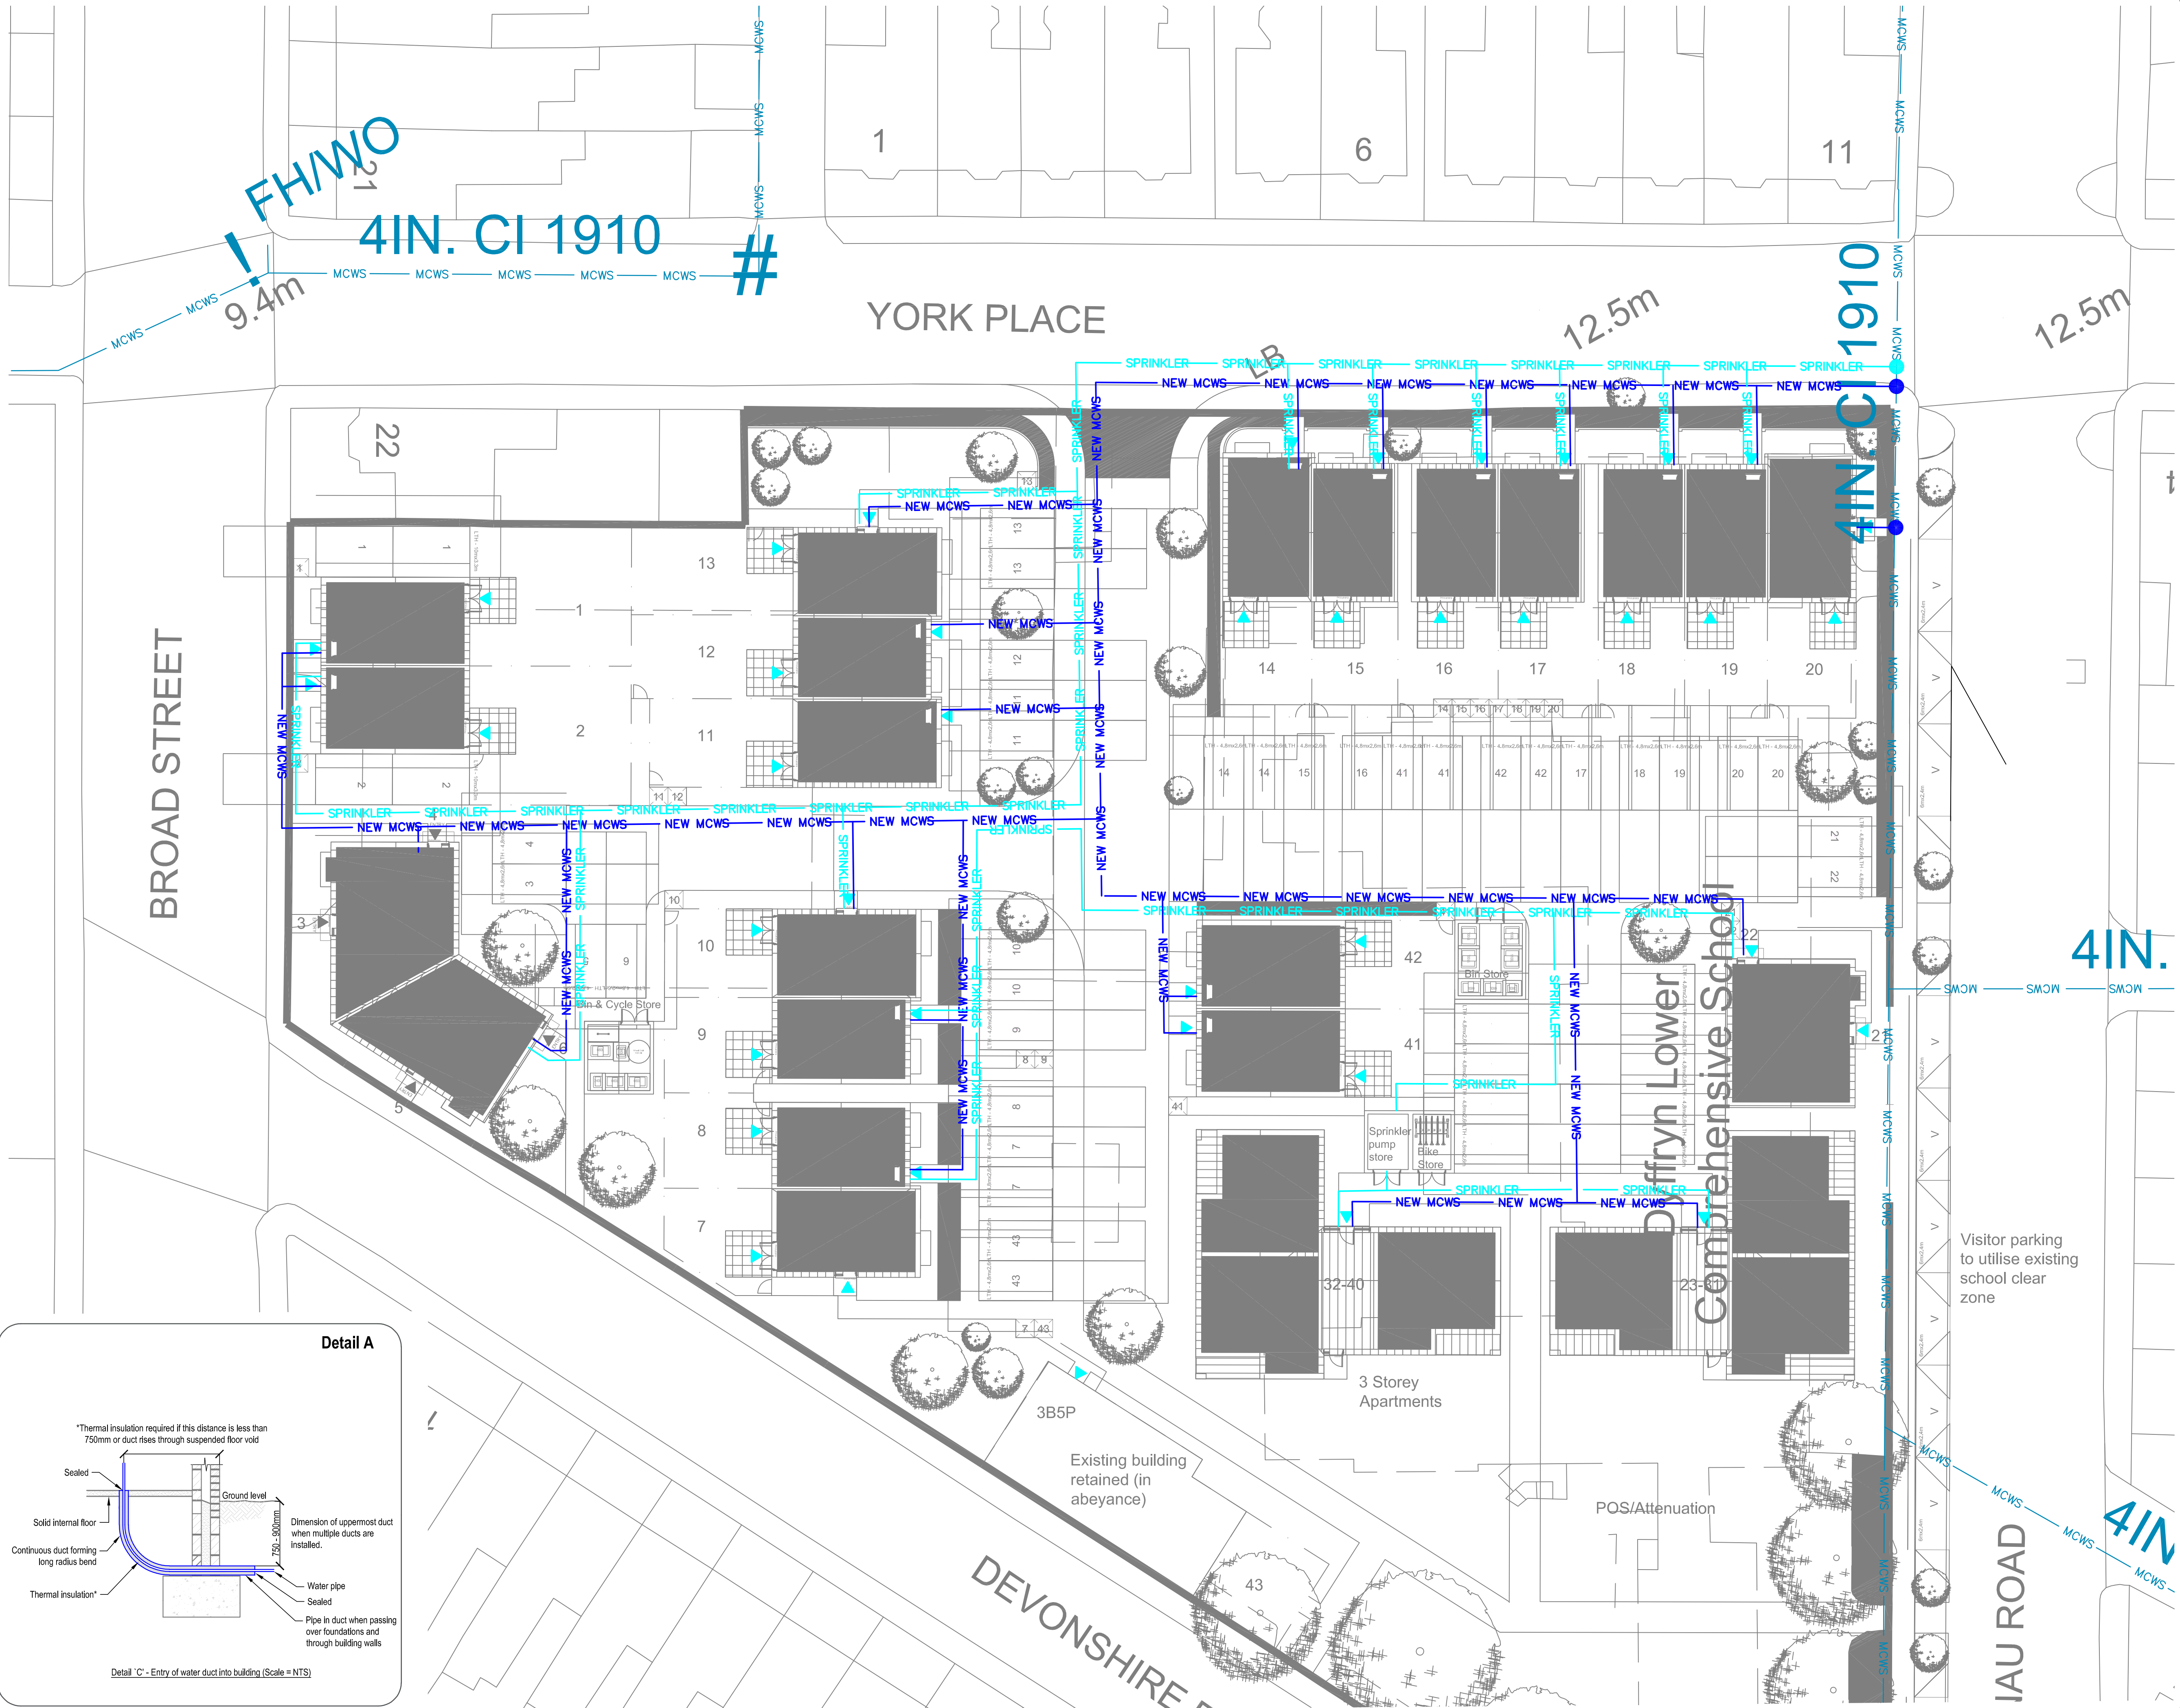

This Drawing is protected by Copyright. It may not be reproduced in any form or by any means for any purpose without the written consent of Services Design Solution Limited. Do not scale. All Dimensions to be checked on Site and verified prior to commencing Works / Manufacture. Any discrepancies to be reported to Services Design Solution Limited. These Drawings reflect the layout for the purpose of design only. The Contractor shall be responsible for producing their own Working and Co-ordination drawings prior to commencing their installations. If these drawings are used for Construction purposes it is done so at the Contractor's Risk.

ISO 14001
REGISTERED FIRM

ISO 9001
REGISTERED FIRM

Notes.

1. Do not scale from this drawing.
2. All measurements are in millimetres unless stated otherwise.
3. This drawing shall be read in conjunction with all relevant Architectural, Structural, Mechanical and Electrical services information.
4. This drawing shall be read in conjunction with RIBA Stage 2 Mechanical and Electrical Report and drawings.

Legend

- LV NEW LV SUPPLY BY CONTRACTOR
- HV NEW UKPN HV CABLE - ASSUMED
- DATA NEW DATA ROUTE
- ELV NEW ELV / FIRE ALARM ROUTE
- MCWS EXISTING MCWS
- SPRINKLER SPRINKLER
- NEW MCWS NEW WATER CONNECTION

P01	Preliminary Issue	RHLYM	28/06/22
Rev	Details:	By / Ck'd / App	Date

**Engineering Consultants**

SERVICES DESIGN SOLUTION LIMITED
Units 5 & 6 Westfield Park,
Bristol, North Somerset BS21 6UA
Tel +44 (0)1275 872963 | www.sdsolution.co.uk

CLIENT

**Linc**

PROJECT TITLE
LCHA Devonshire Place

DRAWING TITLE
External Services
Site Plan

SCALE AT A1
1:250

DISCIPLINE
DOMESTIC WATER & SPRINKLER LAYOUT

DRAWING NUMBER
06485B-SDS-EX-XX-DR-N-3716-02

Project - Originator - Zone - Level - Type - Role - NBS class - Sequential Number

STATUS
Preliminary

SUITABILITY
S3

ISSUE
P01