
 


SITE LOCATION

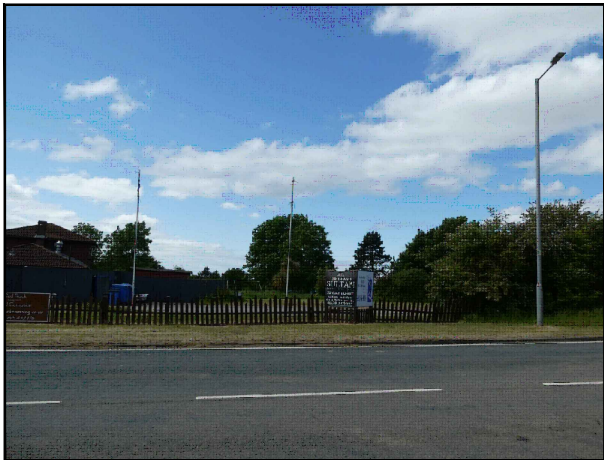


Reproduced by permission of Ordnance Survey on behalf of the Controller of Her Majesty's Stationary Office
All rights reserved. © Crown Copyright licence no. 100062043

SITE AREA PLAN




SITE PHOTOGRAPH

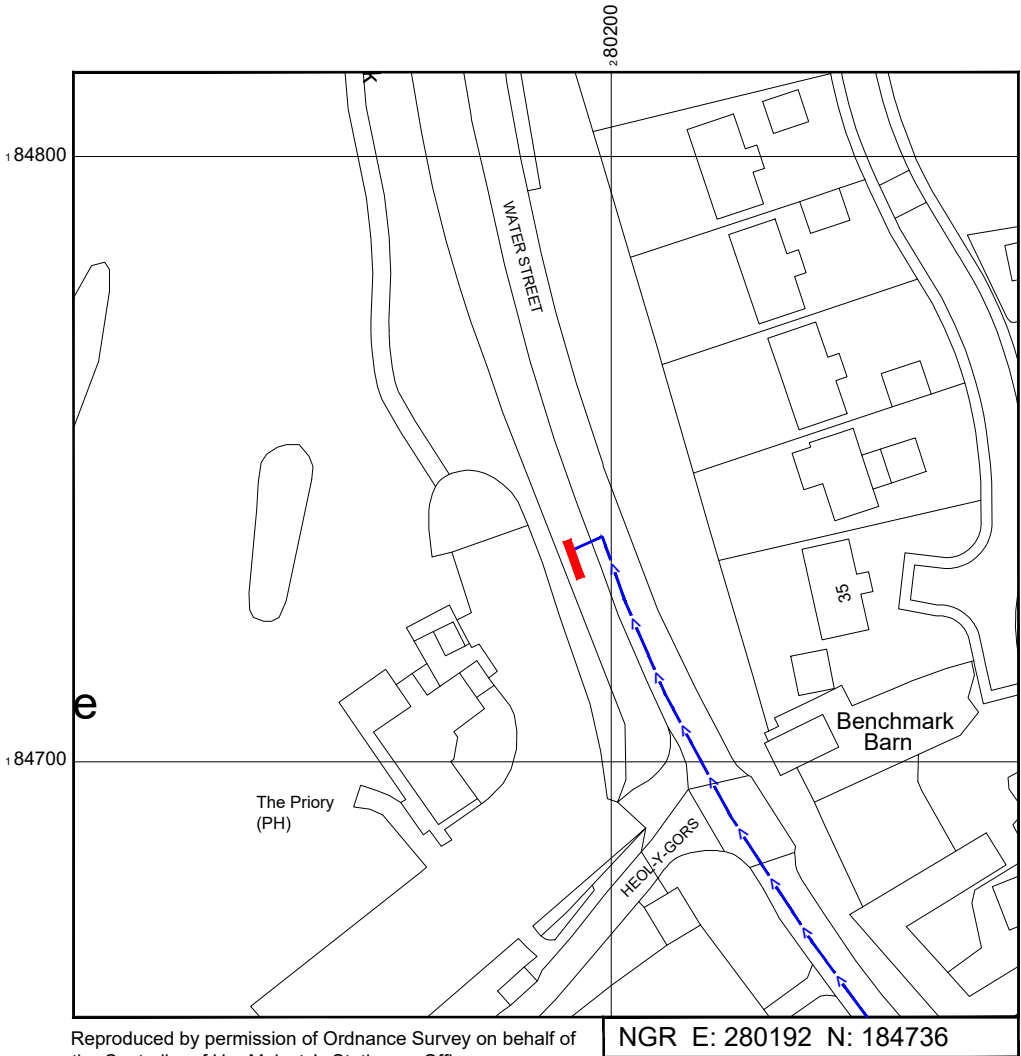

Reproduced by permission of Ordnance Survey on behalf of the Controller of Her Majesty's Stationary Office
All rights reserved. © Crown Copyright licence no. 100062043

 SITE LOCATION PLAN



GOOGLE MAPS QR CODE

GOOGLE MAPS - <https://goo.gl/maps/Rz9JJRYsQdGNQLpW8>

GOOGLE STREETVIEW - <https://goo.gl/maps/Azzg7KwSN6WxndxJ7>

NOTES:

1. ALL DIMENSIONS IN MM UNLESS OTHERWISE NOTED.

DIRECTIONS TO SITE:

Head west on M4. At junction 37, take the A4229 exit to Porthcawl/Pyle/Pil. At Pyle Interchange, take the 1st exit onto A4229. At the roundabout, take the 3rd exit onto Porthcawl Rd/B4283. Follow Water Street and site location is on the left hand side.

Site Provider's
Property Boundary:



Access Route To Site:



Access Route:



Master:	MBNL / EE:	Project:	Purpose of Issue:	Issue:
M002	MBNL	3UK DNSW	Planning	B
Date:	05/06/2023	Revision / Upgrade Description:		
Drawn:	CDN	Pole location amended		
Checked:	DH			
Approved:	SD			
Master:	MBNL / EE:	Project:	Purpose of Issue:	Issue:
M001	MBNL	3UK DNSW	Planning	A
Date:	07/06/2021	Revision / Upgrade Description:		
Drawn:	CDN	First Issue - Site nomination dated: TBC		
Checked:	DH			
Approved:	SD			

CK Hutchison
Networks (UK)
Limited

Green Park
450 Longwater Avenue
Reading
RG30 3UR

Design Consultant & Principal Contractor:



WHP Telecoms

Unit 1 Maple Park,
Low Fields Avenue, Leeds
LS12 6HH

Tel: 01133023550
e-mail: info@whptelecoms.com

Site Name:
WATER STREET STREETWORKS

Site ID:
NPT16183

Address:
WATER STREET, MARGAM,
NEATH PORT TALBOT, WALES,
SA13 2PA


Title:
002 SITE LOCATION PLAN

Project:
3UK DNSW

Purpose of Issue:
PLANNING

EE Cell ID: 81617	MBNL Cell ID: NPT071	Cell ID: SA0548
----------------------	-------------------------	--------------------

Master Drawing No: NPT16183_M002	Issue: B
-------------------------------------	-------------

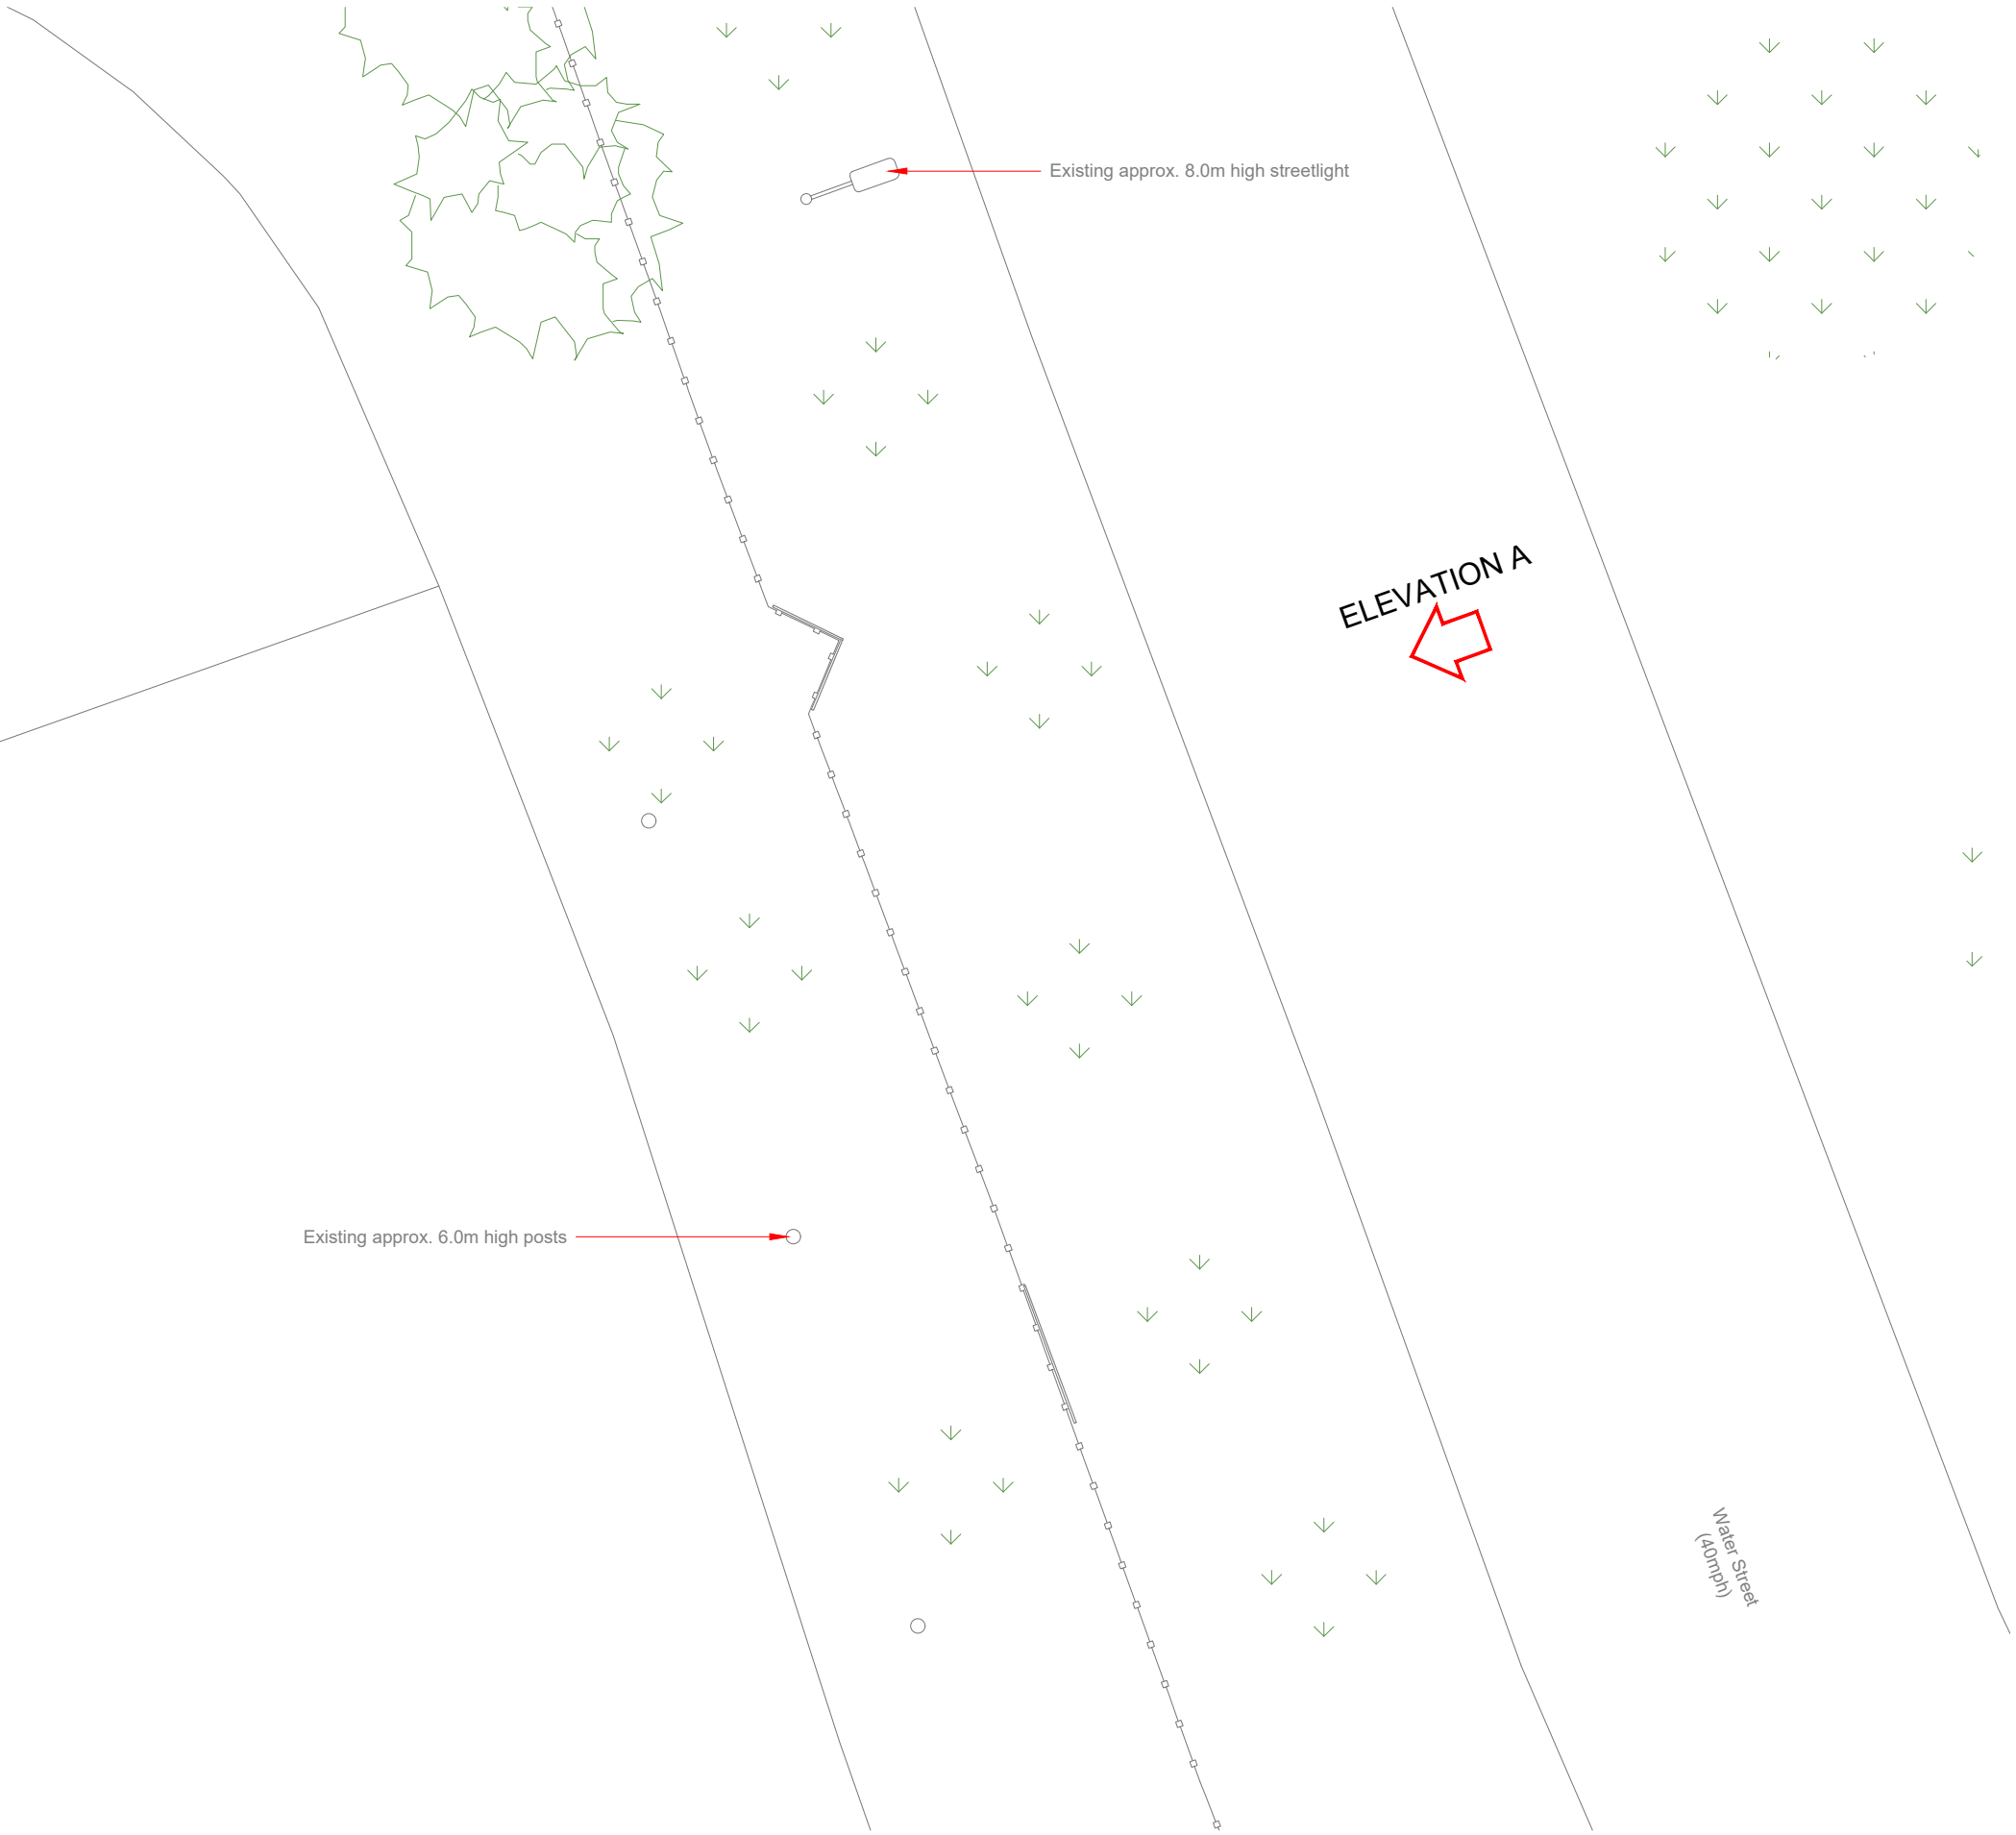


100mm

150mm

10mm

 EXISTING SITE PLAN



- NOTES:
- ALL DIMENSIONS IN MM UNLESS OTHERWISE NOTED.

Master:	MBNL / EE:	Project:	Purpose of Issue:	Issue:
M002	MBNL	3UK DNSW	Planning	B
Date:	05/06/2023	Revision / Upgrade Description:		
Drawn:	CDN	Pole location amended		
Checked:	DH			
Approved:	SD			
Master:	MBNL / EE:	Project:	Purpose of Issue:	Issue:
M001	MBNL	3UK DNSW	Planning	A
Date:	07/06/2021	Revision / Upgrade Description:		
Drawn:	CDN	First Issue - Site nomination dated: TBC		
Checked:	DH			
Approved:	SD			

CK Hutchison
Networks (UK)
Limited

Green Park
450 Longwater Avenue
Reading
RG30 3UR

Design Consultant & Principal Contractor:



WHP Telecoms
Unit 1 Maple Park,
Low Fields Avenue, Leeds
LS12 6HH

Tel: 01133023550
e-mail: info@whptelecoms.com

Site Name:
WATER STREET STREETWORKS

Site ID:
NPT16183

Address:
WATER STREET, MARGAM,
NEATH PORT TALBOT, WALES,
SA13 2PA

Title:
100 EXISTING SITE PLAN

Project:
3UK DNSW

Purpose of Issue:
PLANNING


EE Cell ID: 81617	MBNL Cell ID: NPT071	Cell ID: SA0548
----------------------	-------------------------	--------------------

Master Drawing No: NPT16183_M002	Issue: B
-------------------------------------	-------------


100mm

50mm

10mm

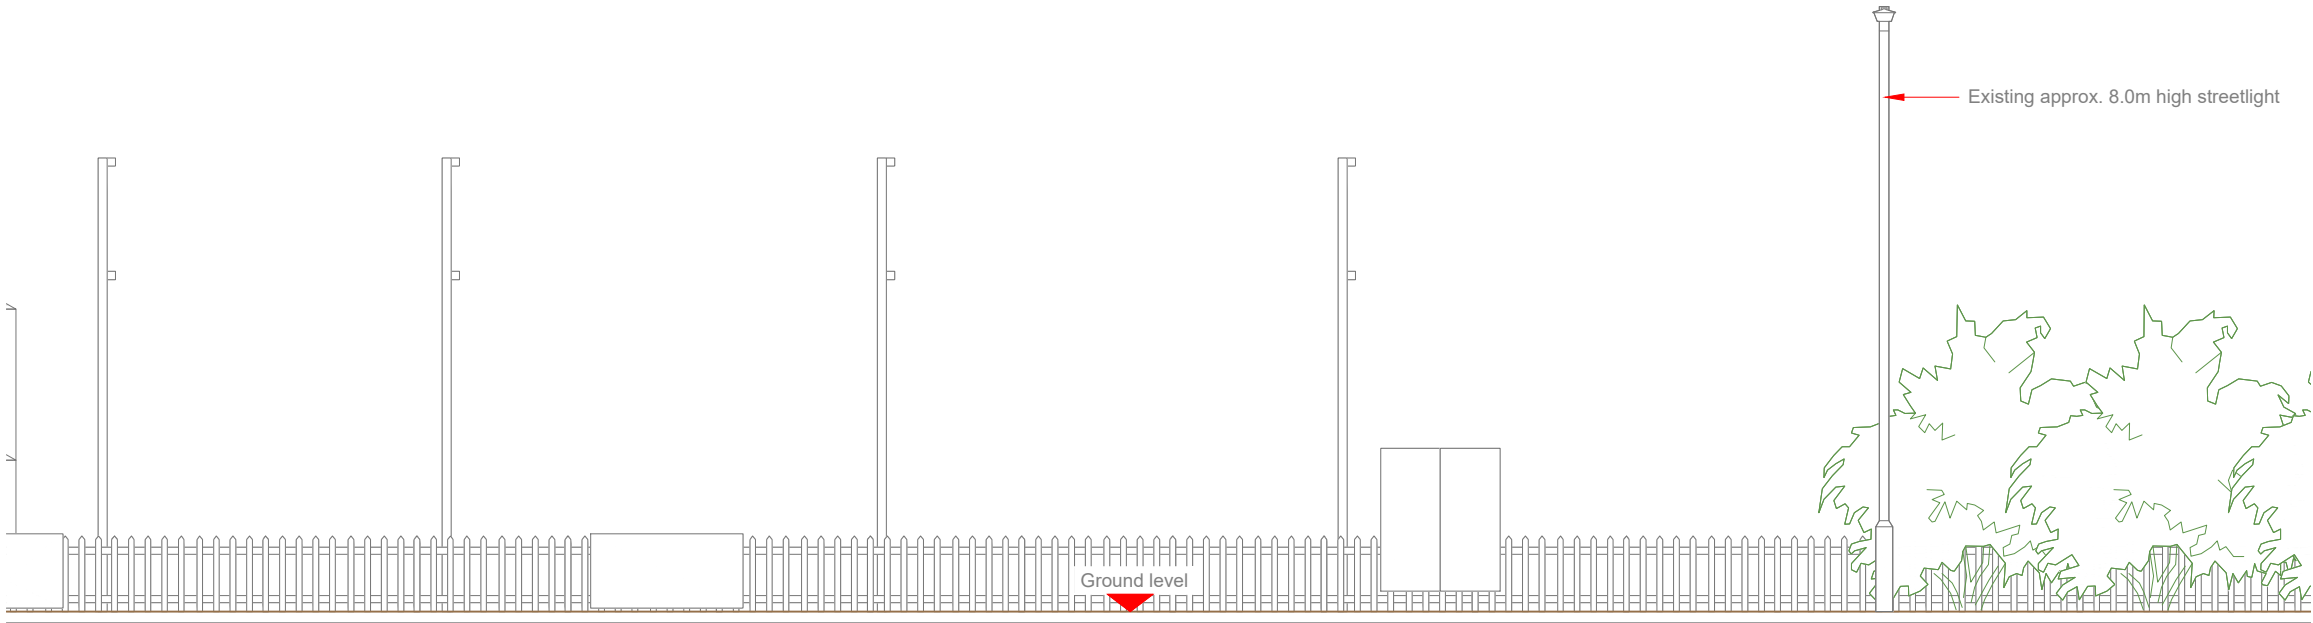

EXISTING ELEVATION A

 

- NOTES:
- ALL DIMENSIONS IN MM UNLESS OTHERWISE NOTED.

Master:	MBNL / EE:	Project:	Purpose of Issue:	Issue:
M002	MBNL	3UK DNSW	Planning	B
Date:	05/06/2023	Revision / Upgrade Description:		
Drawn:	CDN	Pole location amended		
Checked:	DH			
Approved:	SD			
Master:	MBNL / EE:	Project:	Purpose of Issue:	Issue:
M001	MBNL	3UK DNSW	Planning	A
Date:	07/06/2021	Revision / Upgrade Description:		
Drawn:	CDN	First Issue - Site nomination dated: TBC		
Checked:	DH			
Approved:	SD			

CK Hutchison
Networks (UK)
Limited

Green Park
450 Longwater Avenue
Reading
RG30 3UR

Design Consultant & Principal Contractor:



WHP Telecoms
Unit 1 Maple Park,
Low Fields Avenue, Leeds
LS12 6HH

Tel: 01133023550
e-mail: info@whptelecoms.com

Site Name:
WATER STREET STREETWORKS

Site ID:
NPT16183

Address:

WATER STREET, MARGAM,
NEATH PORT TALBOT, WALES,
SA13 2PA

Title:
150 EXISTING ELEVATION A

Project:
3UK DNSW

Purpose of Issue:
PLANNING

EE Cell ID: 81617	MBNL Cell ID: NPT071	Cell ID: SA0548
----------------------	-------------------------	--------------------

Master Drawing No: NPT16183_M002	Issue: B
-------------------------------------	-------------



100mm

150mm

10mm

Existing approx. 6.0m high posts

Existing approx. 8.0m high streetlight

ELEVATION A

Proposed armco barrier

 
Proposed Phase 8 monopole

Proposed 10No. paving slabs

Proposed 2No. cabinets

Proposed G-100876 cabinet

PROPOSED SITE PLAN



Antenna Aperture ID	Proposed 4G/5G Bearing
A1	340°
A2	340°
B1	100°
B2	100°
C1	220°
C2	220°

NOTES:

1. ALL DIMENSIONS IN MM UNLESS OTHERWISE NOTED.

Master:	MBNL / EE:	Project:	Purpose of Issue:	Issue:
M002	MBNL	3UK DNSW	Planning	B
Date:	05/06/2023	Revision / Upgrade Description:		
Drawn:	CDN	Pole location amended		
Checked:	DH			
Approved:	SD			
Master:	MBNL / EE:	Project:	Purpose of Issue:	Issue:
M001	MBNL	3UK DNSW	Planning	A
Date:	07/06/2021	Revision / Upgrade Description:		
Drawn:	CDN	First Issue - Site nomination dated: TBC		
Checked:	DH			
Approved:	SD			

CK Hutchison
Networks (UK)
Limited

Green Park
450 Longwater Avenue
Reading
RG30 3UR

Design Consultant & Principal Contractor:



WHP Telecoms

Unit 1 Maple Park,
Low Fields Avenue, Leeds
LS12 6HH

Tel: 01133023550
e-mail: info@whptelecoms.com

Site Name:
WATER STREET STREETWORKS

Site ID:
NPT16183

Address:
WATER STREET, MARGAM,
NEATH PORT TALBOT, WALES,
SA13 2PA

Title:
210 PROPOSED SITE PLAN

Project:
3UK DNSW

Purpose of Issue:
PLANNING


EE Cell ID: 81617	MBNL Cell ID: NPT071	Cell ID: SA0548
----------------------	-------------------------	--------------------

Master Drawing No: NPT16183_M002	Issue: B
-------------------------------------	-------------


Antenna Aperture ID	Proposed 4G/5G Bearing
A1	340°
A2	340°
B1	100°
B2	100°
C1	220°
C2	220°

NOTES:

1. ALL DIMENSIONS IN MM UNLESS OTHERWISE NOTED.

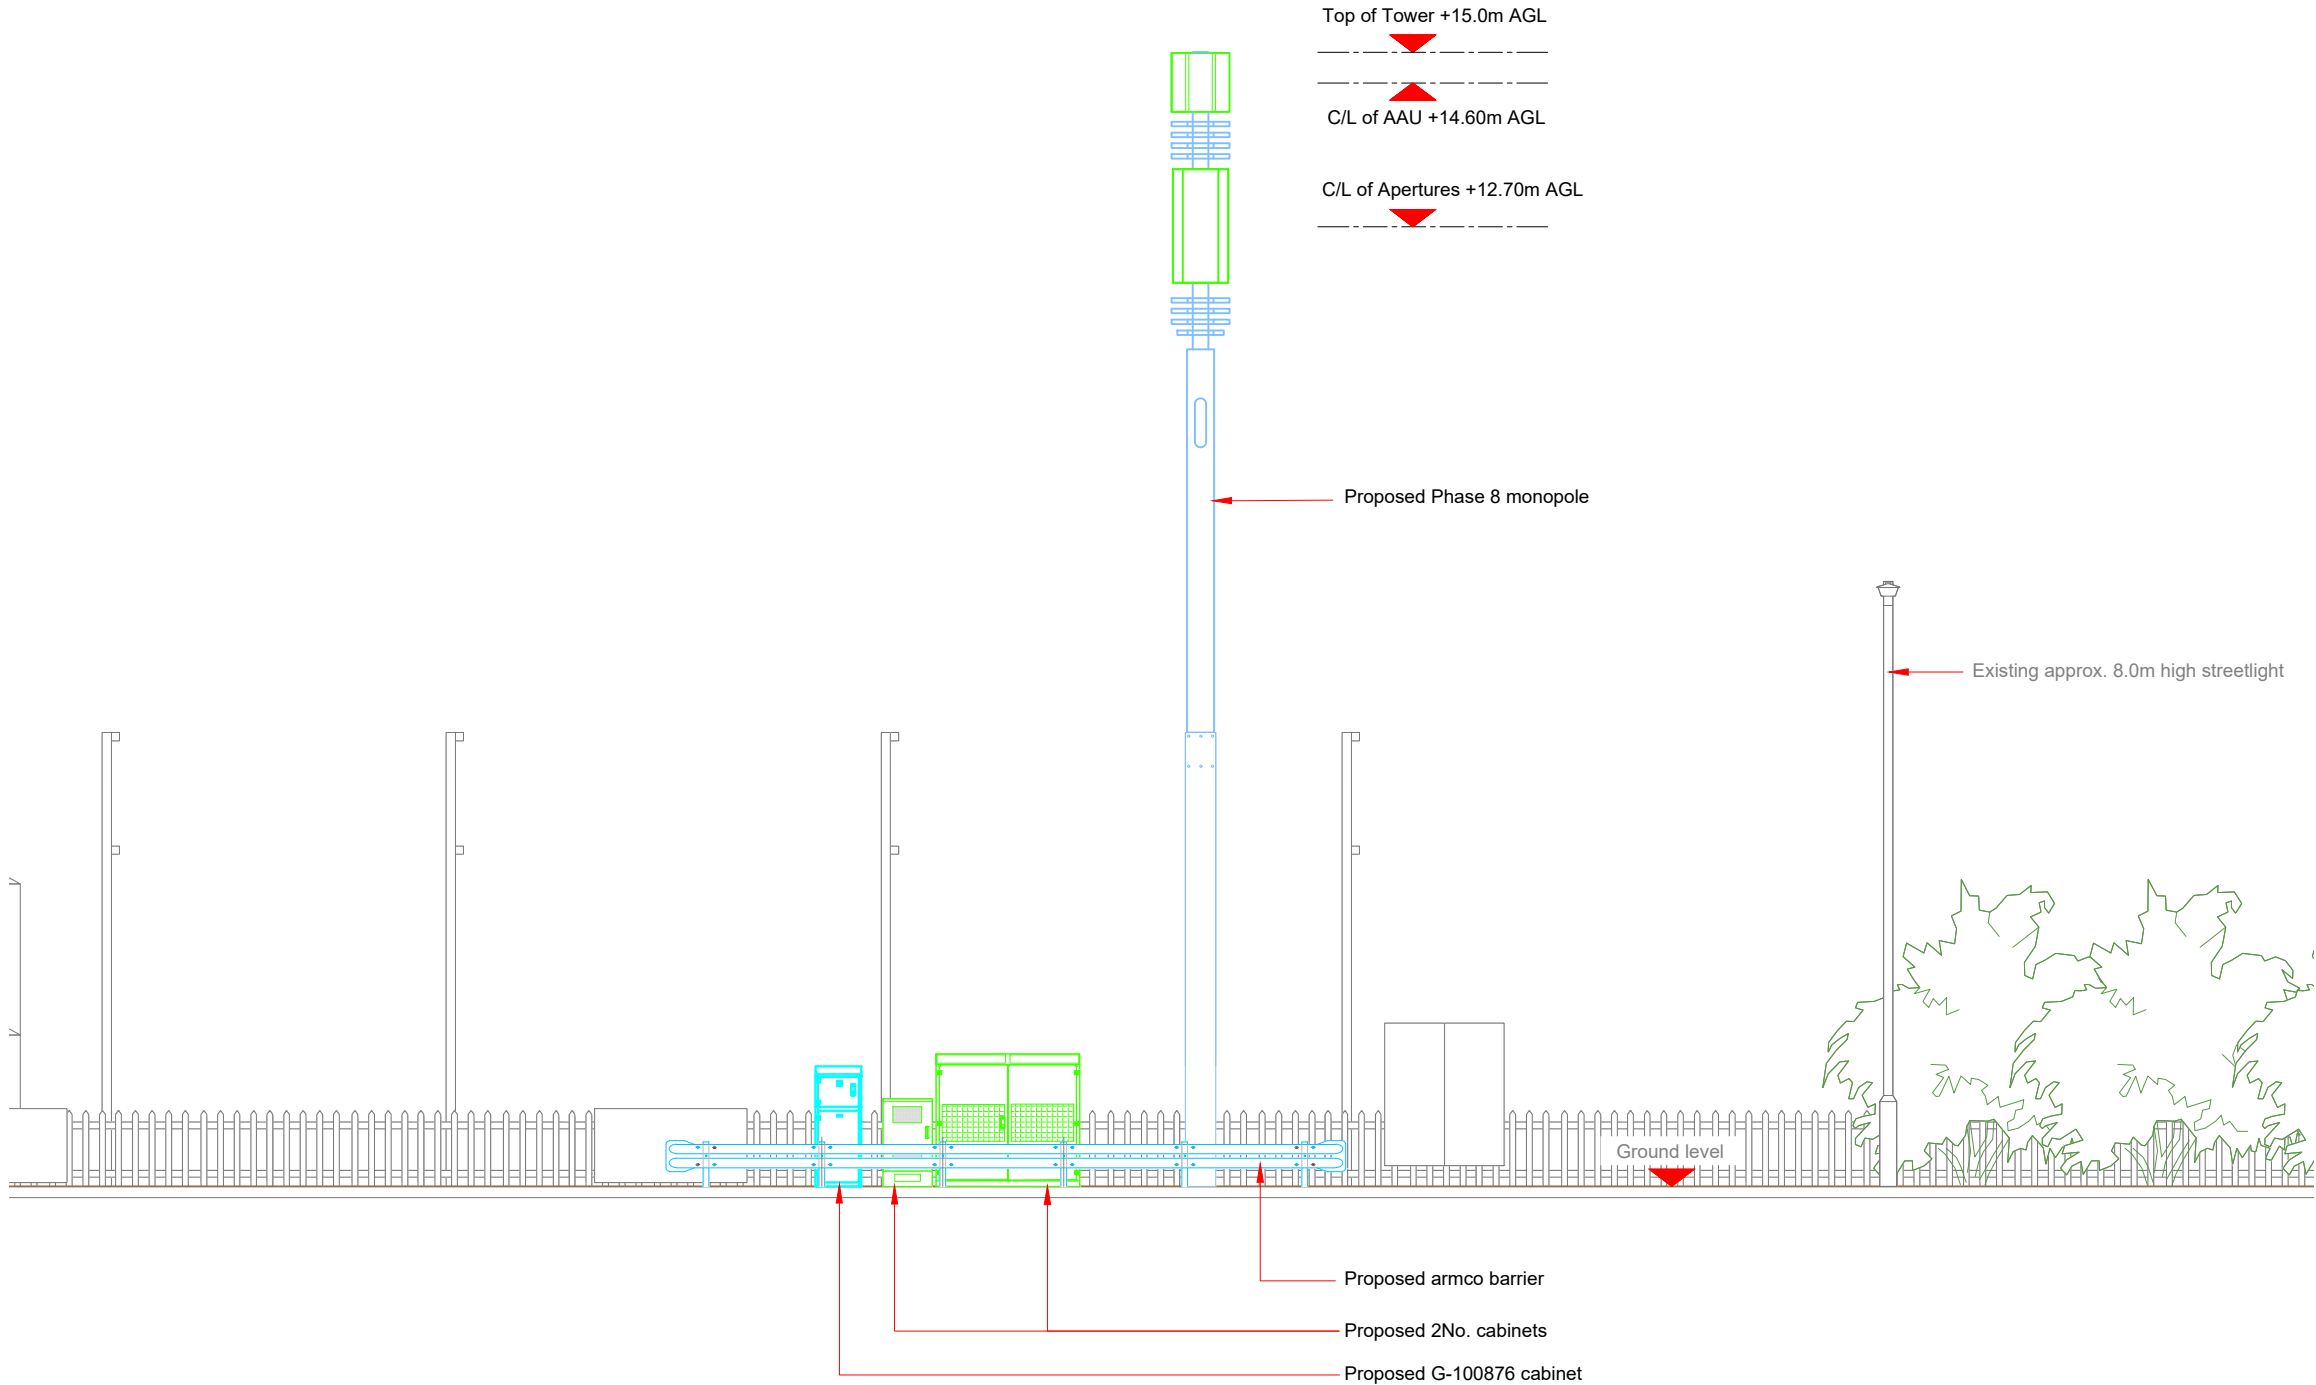

PROPOSED ELEVATION

 

Master:	MBNL / EE:	Project:	Purpose of Issue:	Issue:
M002	MBNL	3UK DNSW	Planning	B
Date:	05/06/2023	Revision / Upgrade Description:		
Drawn:	CDN	Pole location amended		
Checked:	DH			
Approved:	SD			
Master:	MBNL / EE:	Project:	Purpose of Issue:	Issue:
M001	MBNL	3UK DNSW	Planning	A
Date:	07/06/2021	Revision / Upgrade Description:		
Drawn:	CDN	First Issue - Site nomination dated: TBC		
Checked:	DH			
Approved:	SD			

**CK Hutchison
Networks (UK)
Limited**

Green Park
450 Longwater Avenue
Reading
RG30 3UR

Design Consultant & Principal Contractor:



WHP Telecoms

Unit 1 Maple Park,
Low Fields Avenue, Leeds
LS12 6HH

Tel: 01133023550
e-mail: info@whptelecoms.com

Site Name:
WATER STREET STREETWORKS

Site ID:
NPT16183

Address:
**WATER STREET, MARGAM,
NEATH PORT TALBOT, WALES,
SA13 2PA**

Title:
260 PROPOSED ELEVATION

Project:
3UK DNSW

Purpose of Issue:
PLANNING

EE Cell ID: 81617	MBNL Cell ID: NPT071	Cell ID: SA0548
-----------------------------	--------------------------------	---------------------------

Master Drawing No: NPT16183_M002	Issue: B
--	--------------------