


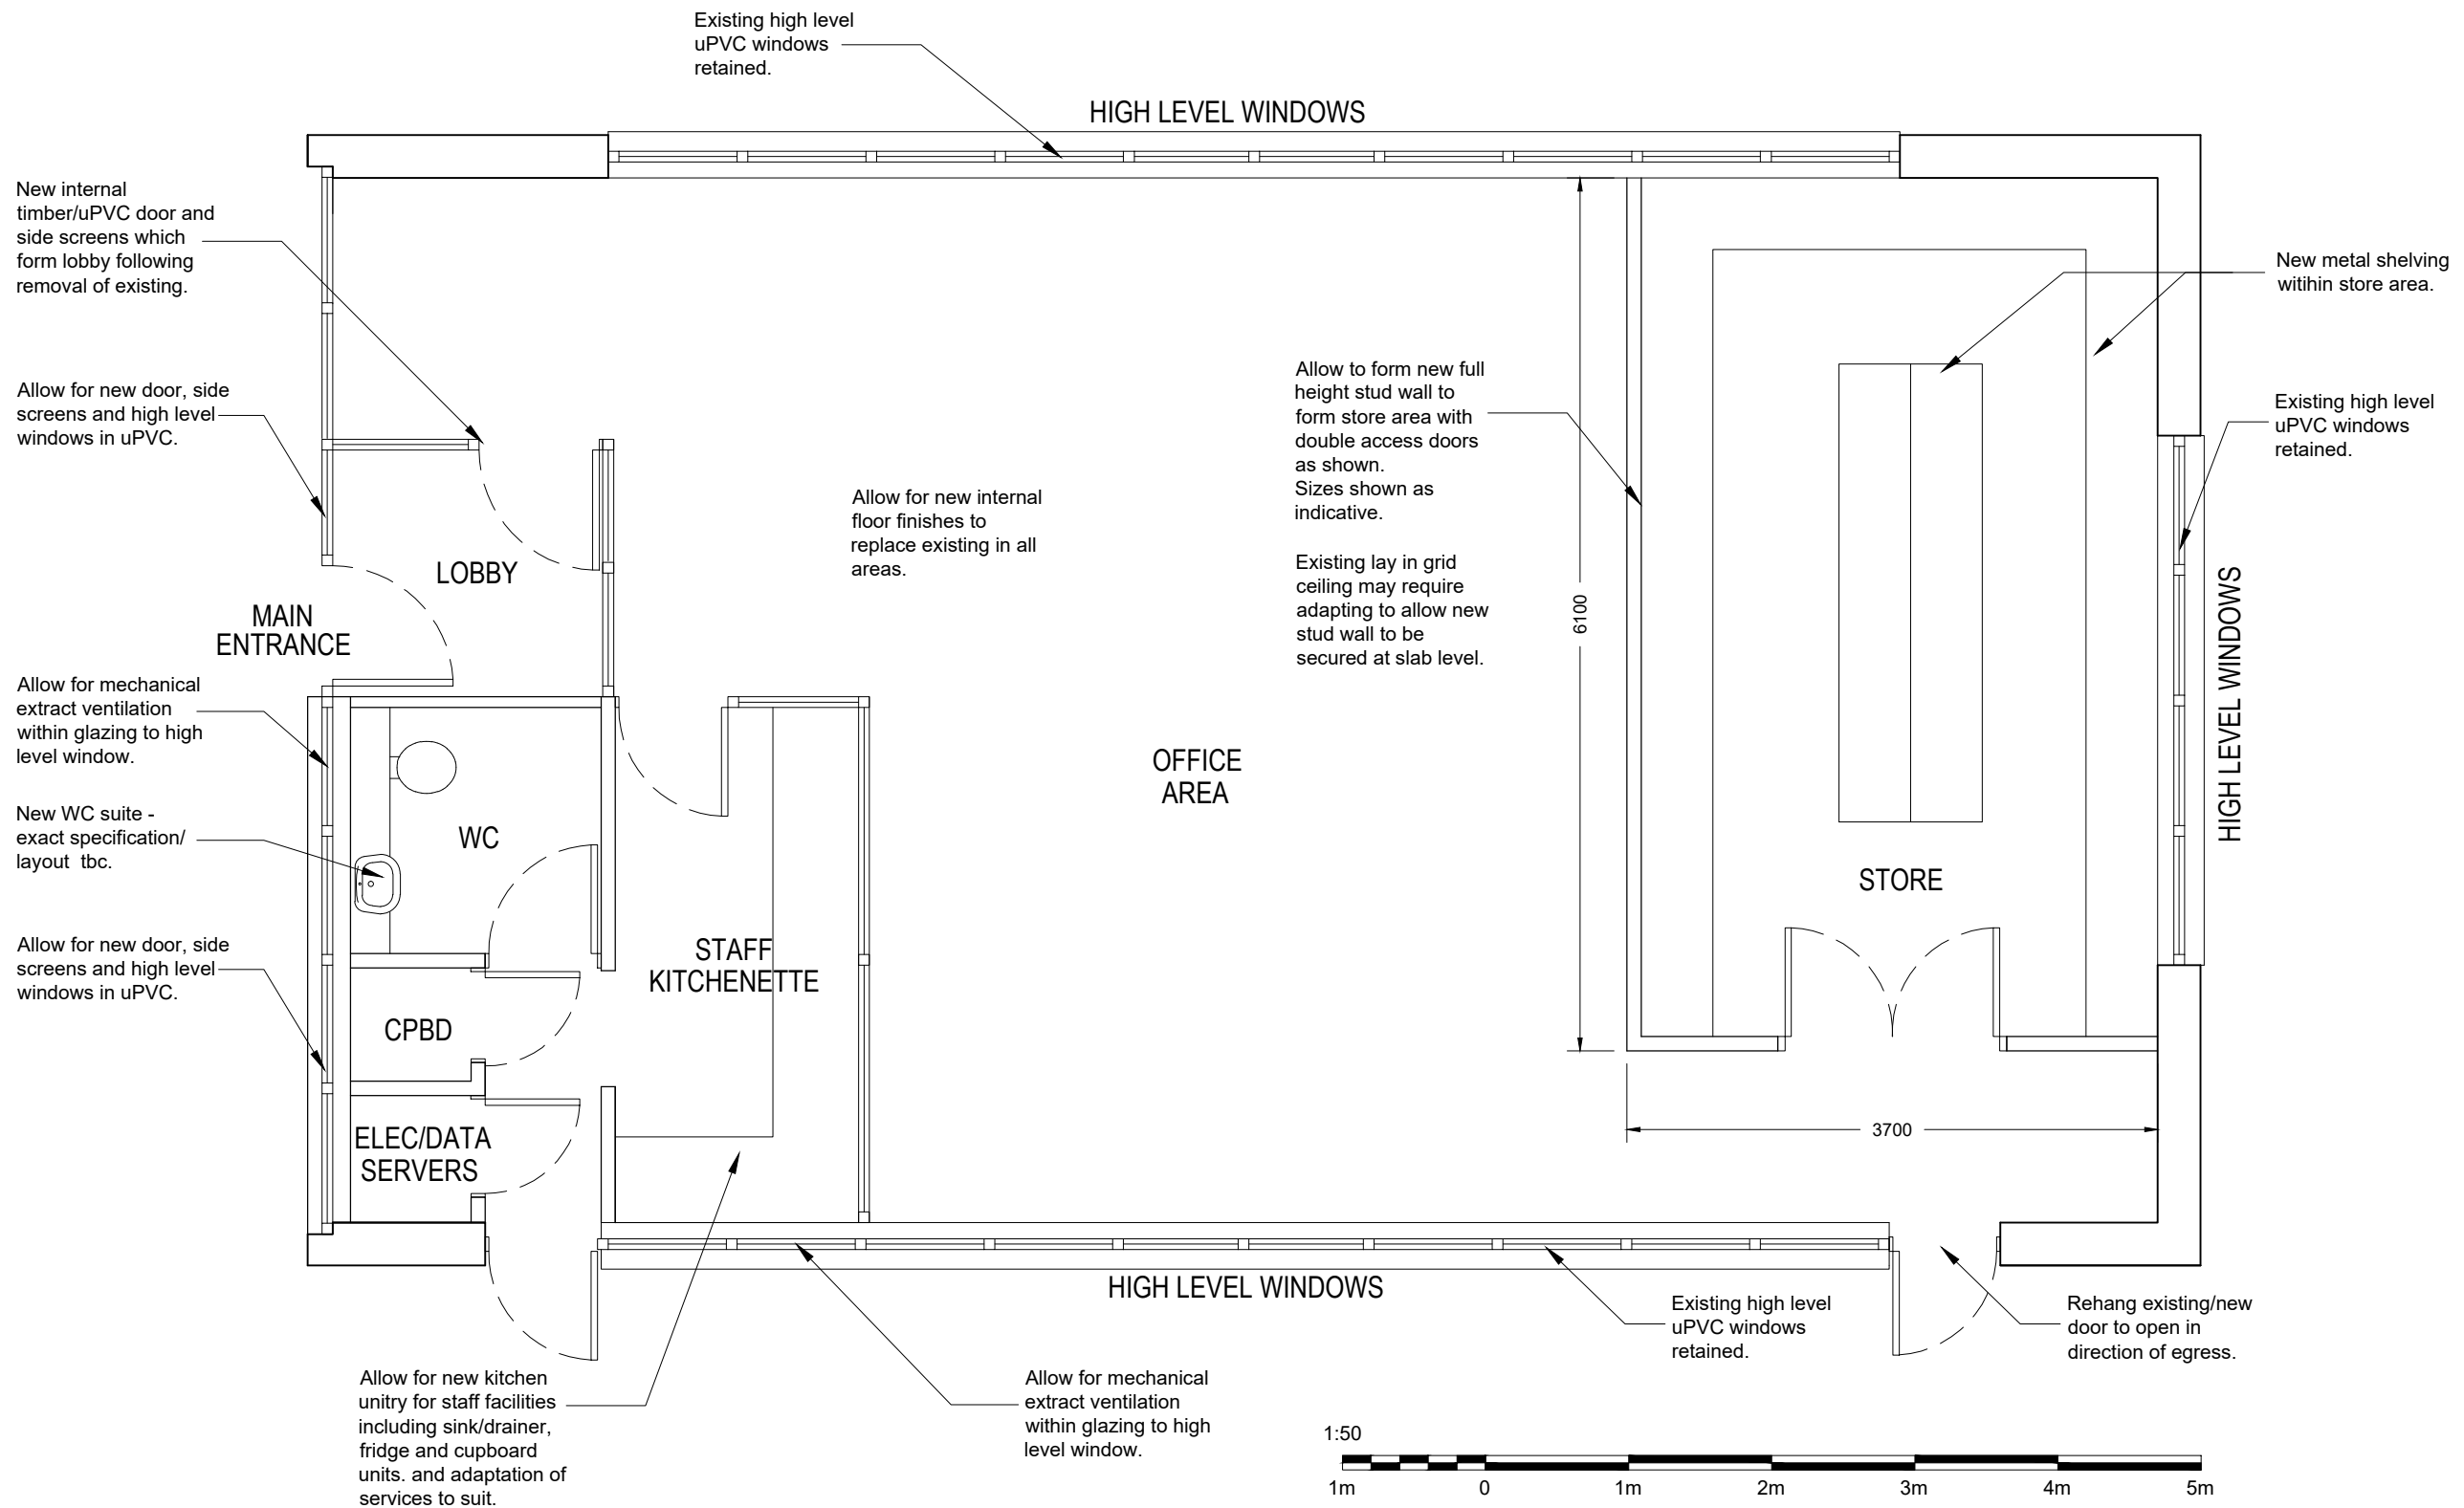

PROPOSED GROUND FLOOR PLAN

scale 1:50 @ A3

JOB: James Brothers office		CLIENT: Carly James James Brothers Plumbing	
ADDRESS: 225 New Rd, Skewen, Neath SA10 6UU			
TITLE: PROPOSED GROUND FLOOR PLAN			
SYSTEM No: H-M/1533-23/James Bros/CAD	DATE: 13.09.23	DRW-No.	Rev
JOB No: 1533-23	Checked by:	P05	/
SCALES: A3 @ 1:50	DRAWN BY: Matt Bailey		
REVISIONS DESCRIPTION:			



Thomas Parry Design
The Old Sketty Coach House,
21 Gower Road, Sketty
Swansea, SA2 9BX
t: 01792 290755
e: design@thomasparry.co.uk
w: www.thomasparry.co.uk

© COPYRIGHT THOMAS PARRY DESIGN LIMITED