


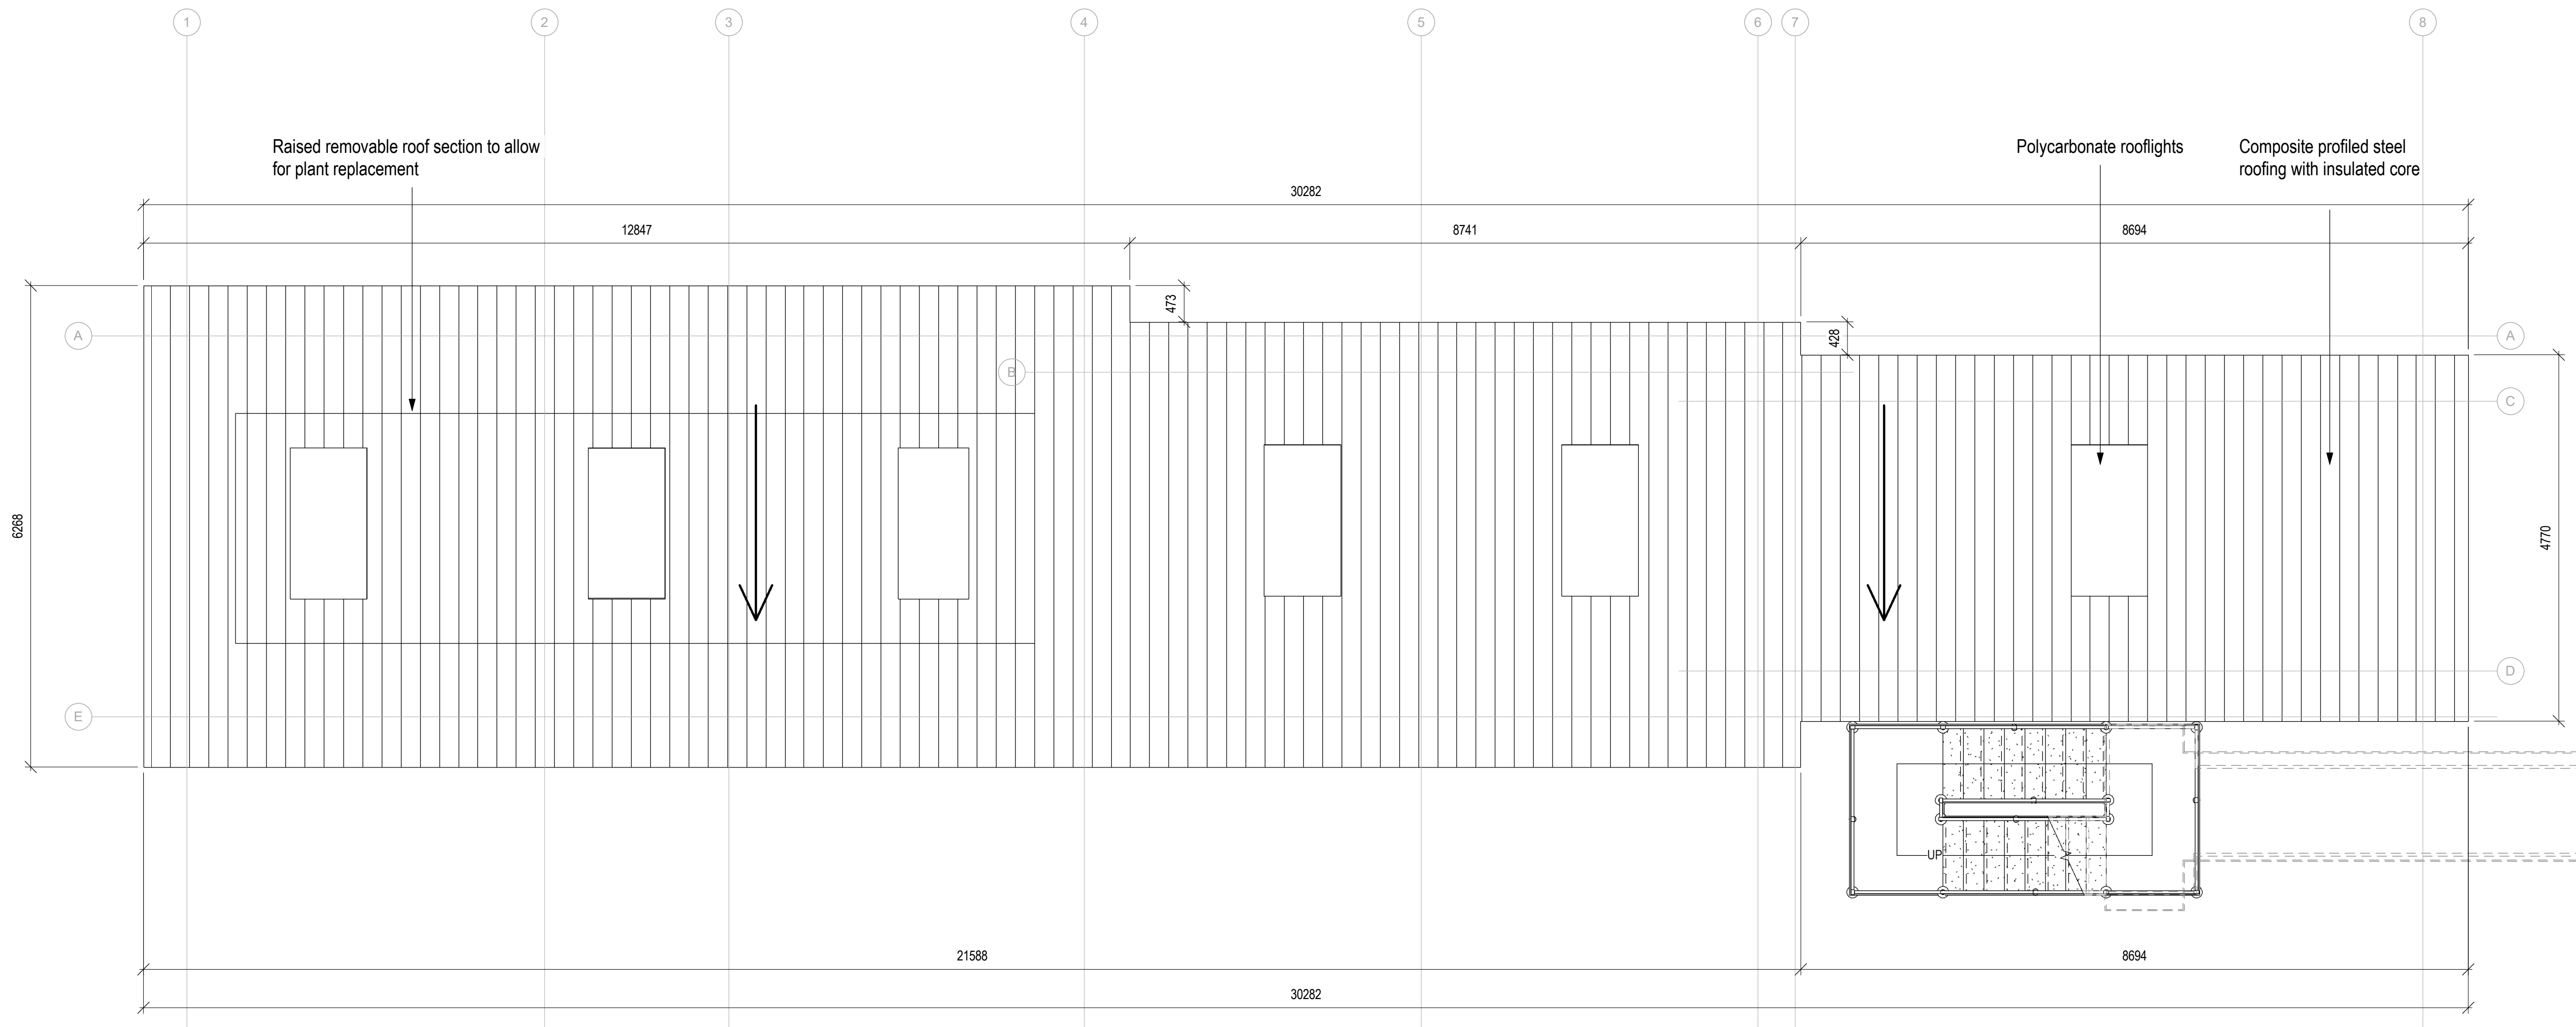


A-PLA-GA_Roof
1 : 50

NOTES

presented to The Coal Authority in respect of Ynysarwed Mine Water Treatment Scheme and may not be used or relied on by any other person or by the client in relation to any other matters not covered specifically by the scope of this Kier Business Services Limited is obliged to exercise reasonable skill, care and diligence in the performance of the services required by The Coal Authority

Scale:

1:5	mm	50	100	150	200
1:10	mm	100	200	300	400
1:20	mm	200	400	600	800
1:50	mm	500	1000	1500	2000

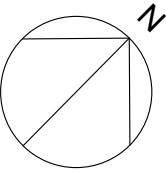

P01	Issued for Planning	EK	PM	JM
Version	Amendment	Drawn & Date	Checked & Date	Approved & Date



Issuing Office Liverpool	Telephone 0151 600 5500
E-mail Phil.Martin@Kier.co.uk	
Internal Project Number 034970	
Client The Coal Authority	
Project Name Ynysarwed Mine Water Treatment Scheme	
Drawing Title Proposed Roof Plan Treatment Building	
Scale 1 : 50	Original Size A1
Date 24/08/2023	Drawn EK
Checked PM	Approved JM
Drawing Number YNYS-DBS-01-RF-D-A-0102	Status S2
Project Code	Origin
Volume	Level
Type	Risk
Number	Revision P01