
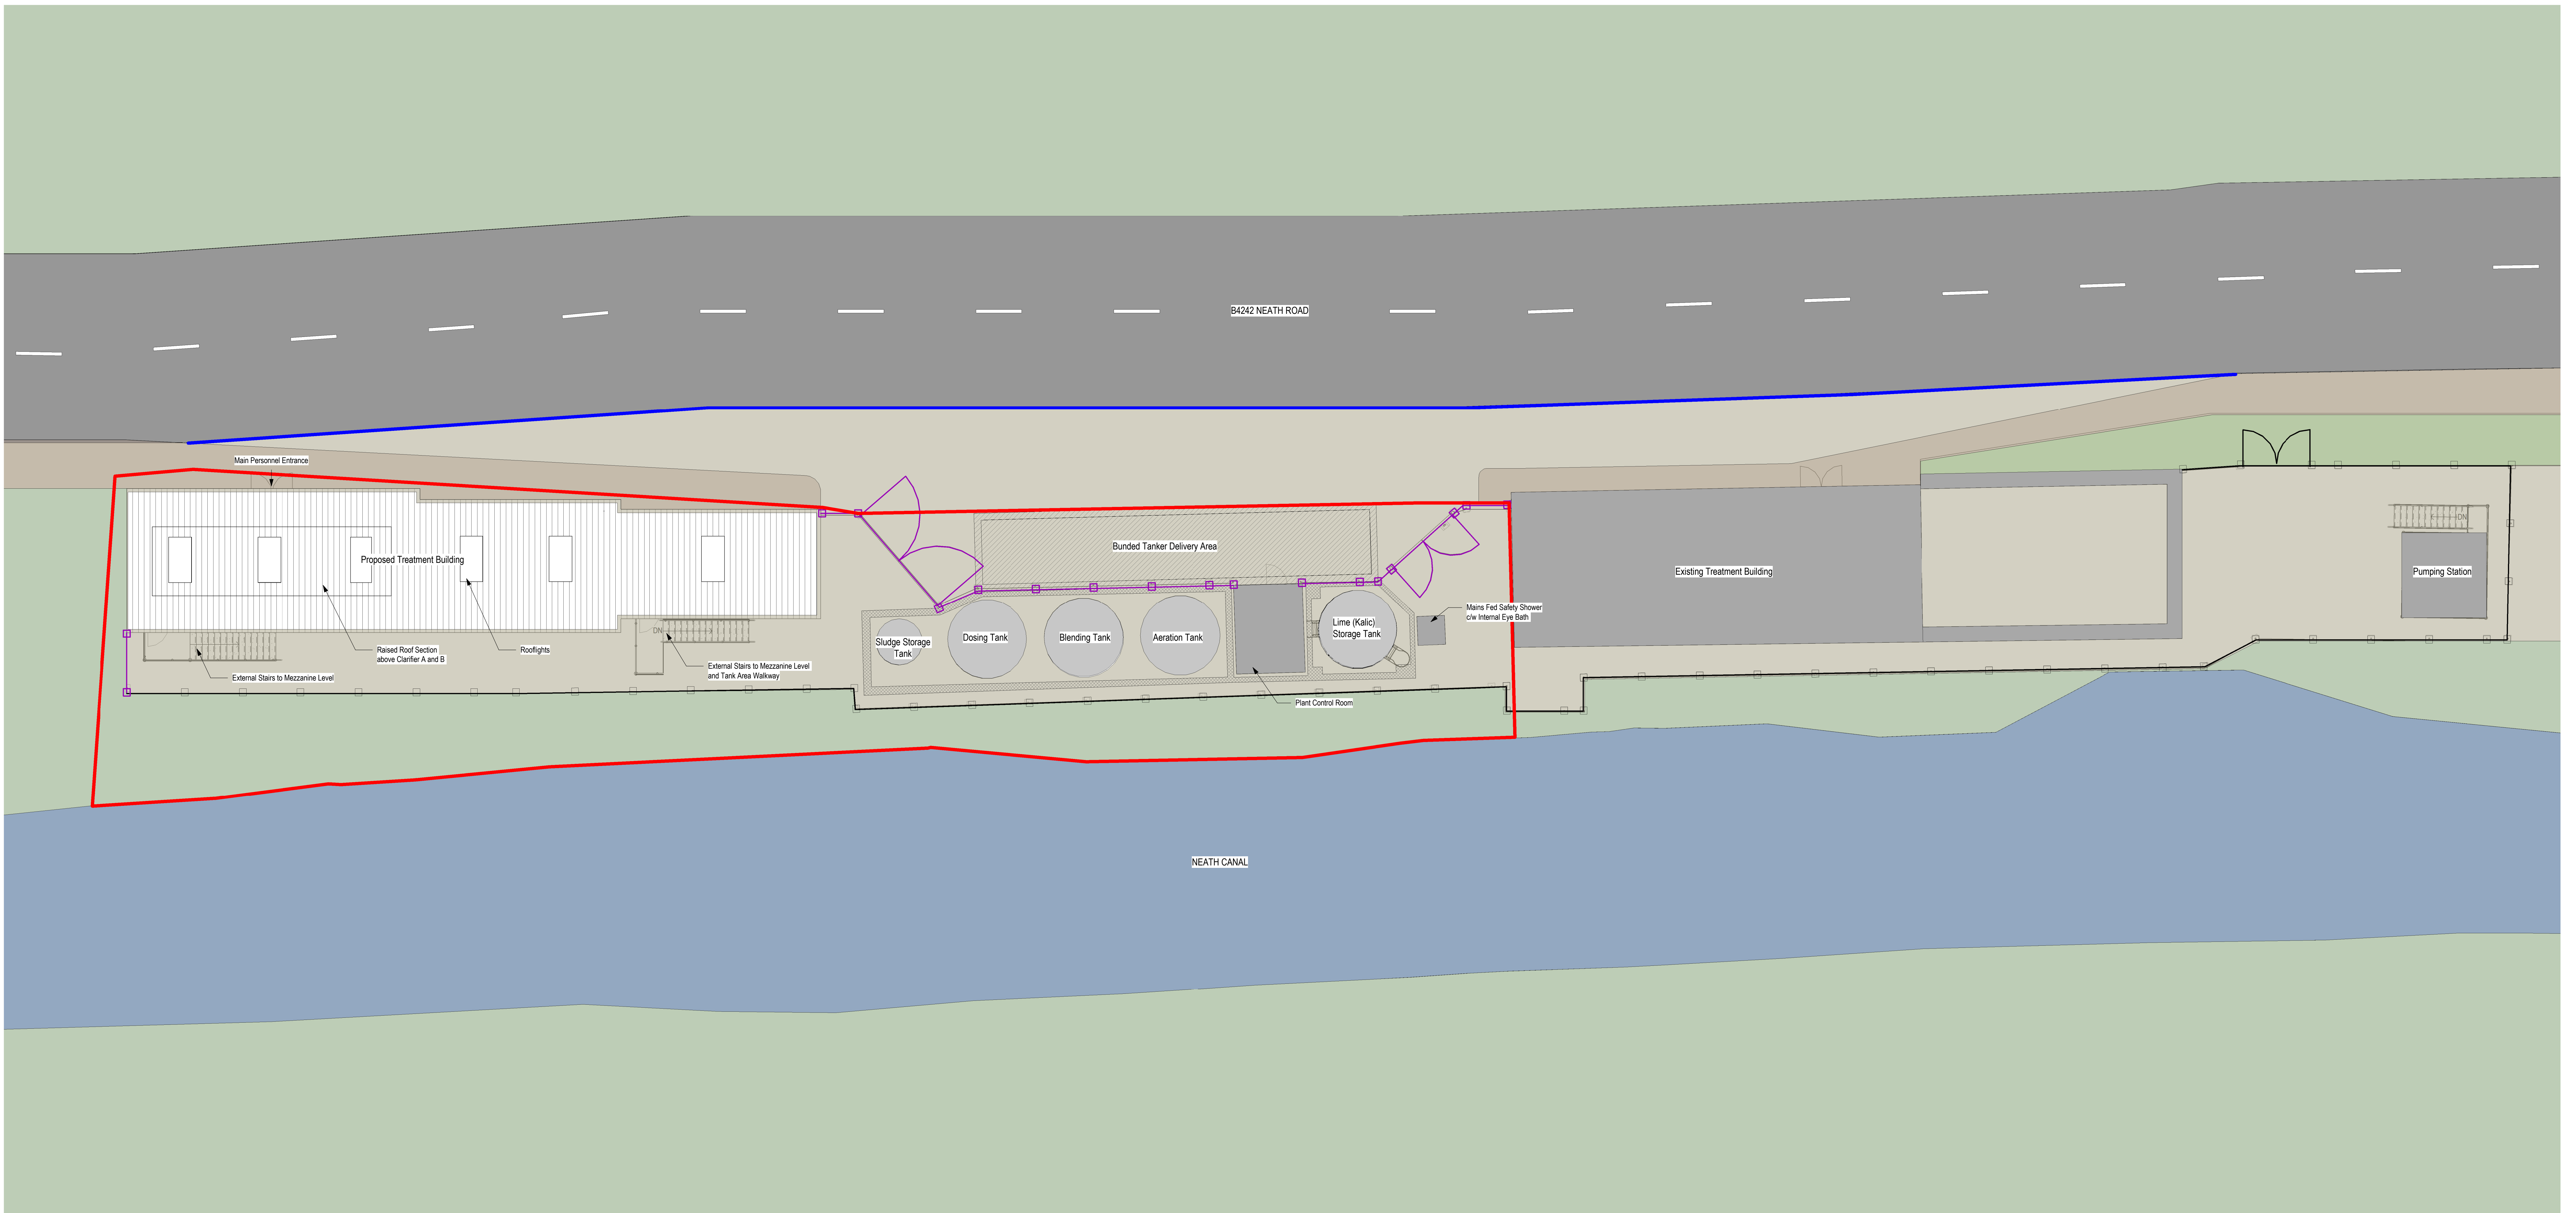
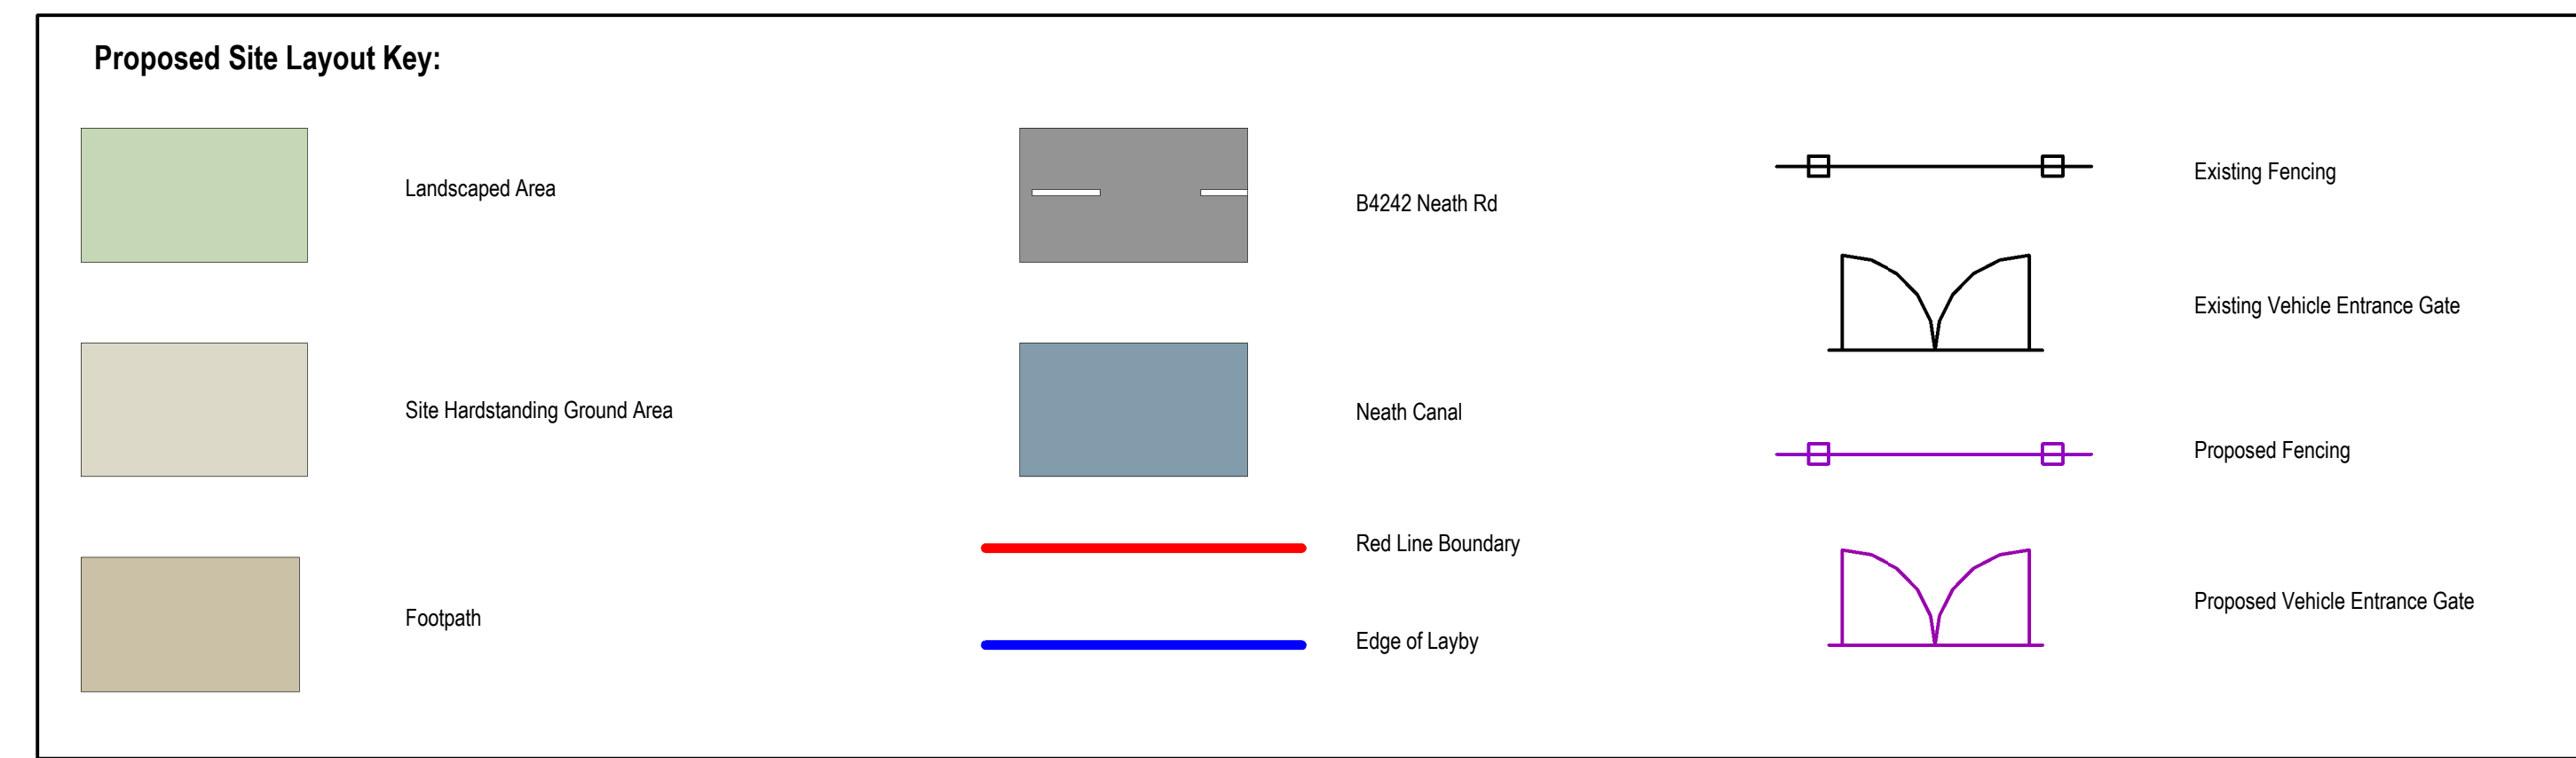


Business Services Limited is obliged to exercise reasonable skill, care and
once in the performance of the services required by The Coal Authority

0	mm		1000		3000		5000
10	mm		1000		3000		5000
10	M		10		15		25
20	M		10		30		50

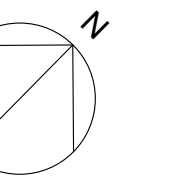

Planning Issue raised following TCA comments	2K 03/08/23	3K 03/08/23	3M 07/08/23
Issued for Planning	2K 24/08/23	3M 24/08/23	3M 25/08/23
Amendment	Drawn & Date	Checked & Date	Approved & Date

[illegible]

[Home](#)
[About Us](#)
[Services](#)
[Testimonials](#)
[Contact Us](#)

ing Office	Telephone
------------	-----------

Liverpool	0151 600 5500
-----------	---------------

Phil.Martin@Kier.co.uk

Final Project Number034970The Coal Authority

Project Name _____

Zongyanwu Mine Water Treatment Scheme

Physarum Mine Water Treatment Scheme

Working Title

Proposed Site Plan

	Original Size	RBA 2013 Stage
--	---------------	----------------

1 : 100	A0	Stage 03
---------	----	----------

24/08/2023	Drawn EK	Checked RM	Approved IM
------------	-------------	---------------	----------------

2400000000	ER	FM	JM
2400000000	ER	FM	JM

YNYS-DBS-00-XX-D-A-0003

Project Code	Origin	Volume	Level	Type	Rule	Number
						P02

© 2006 The Authors
Journal compilation © 2006 Blackwell Publishing Ltd

© Kier Business Services Limited