


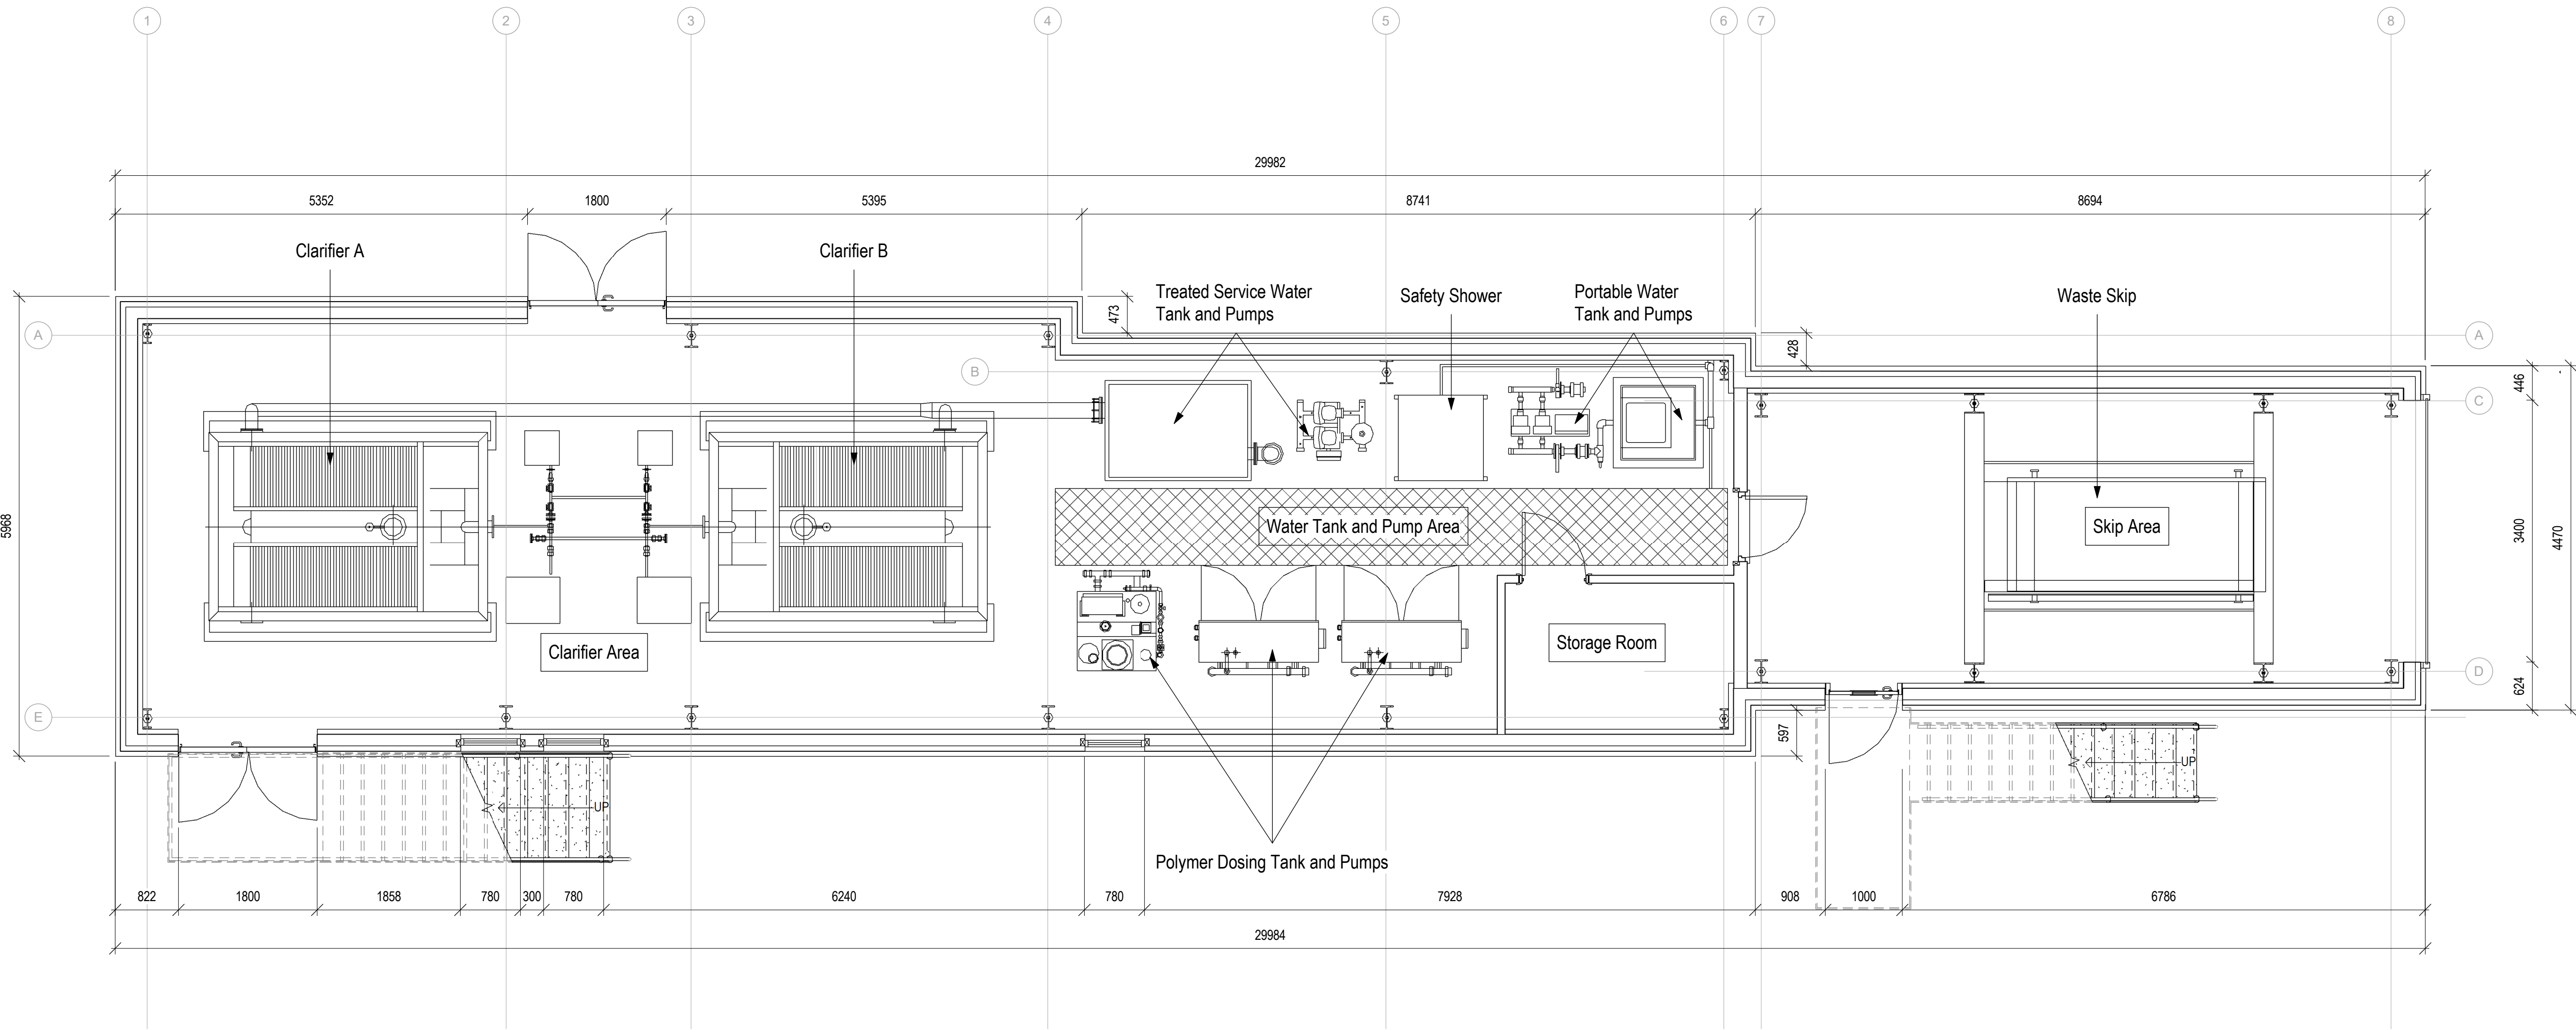


Proposed Ground Floor Plan Treatment Building
1 : 50

NOTES
presented to The Coal Authority in respect of Ynysarwed Mine Water Treatment Scheme and may not be used or relied on by any other person or by the client in relation to any other matters not covered specifically by the scope of this Kier Business Services Limited is obliged to exercise reasonable skill, care and diligence in the performance of the services required by The Coal Authority

Scale:

1:5	mm	50	100	200
1:10	mm	100	200	400
1:20	mm	200	400	800
1:50	mm	500	1000	2000

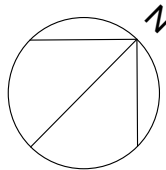

P01	Issued for Planning	EK	PM	JM
Version	Amendment	Drawn & Date	Checked & Date	Approved & Date



Issuing Office Liverpool	Telephone 0151 600 5500
E-mail Phil.Martin@Kier.co.uk	
Internal Project Number 034970	
Client The Coal Authority	
Project Name Ynysarwed Mine Water Treatment Scheme	
Drawing Title Proposed Ground Floor Plan Treatment Building	
Scale 1 : 50	Original Size A1
Date 2/08/2023	Drawn EK
Drawing Number YNYS-DBS-01-00-D-A-0100	Checked PM
	Approved JM
	Status S2
	Revision P01