



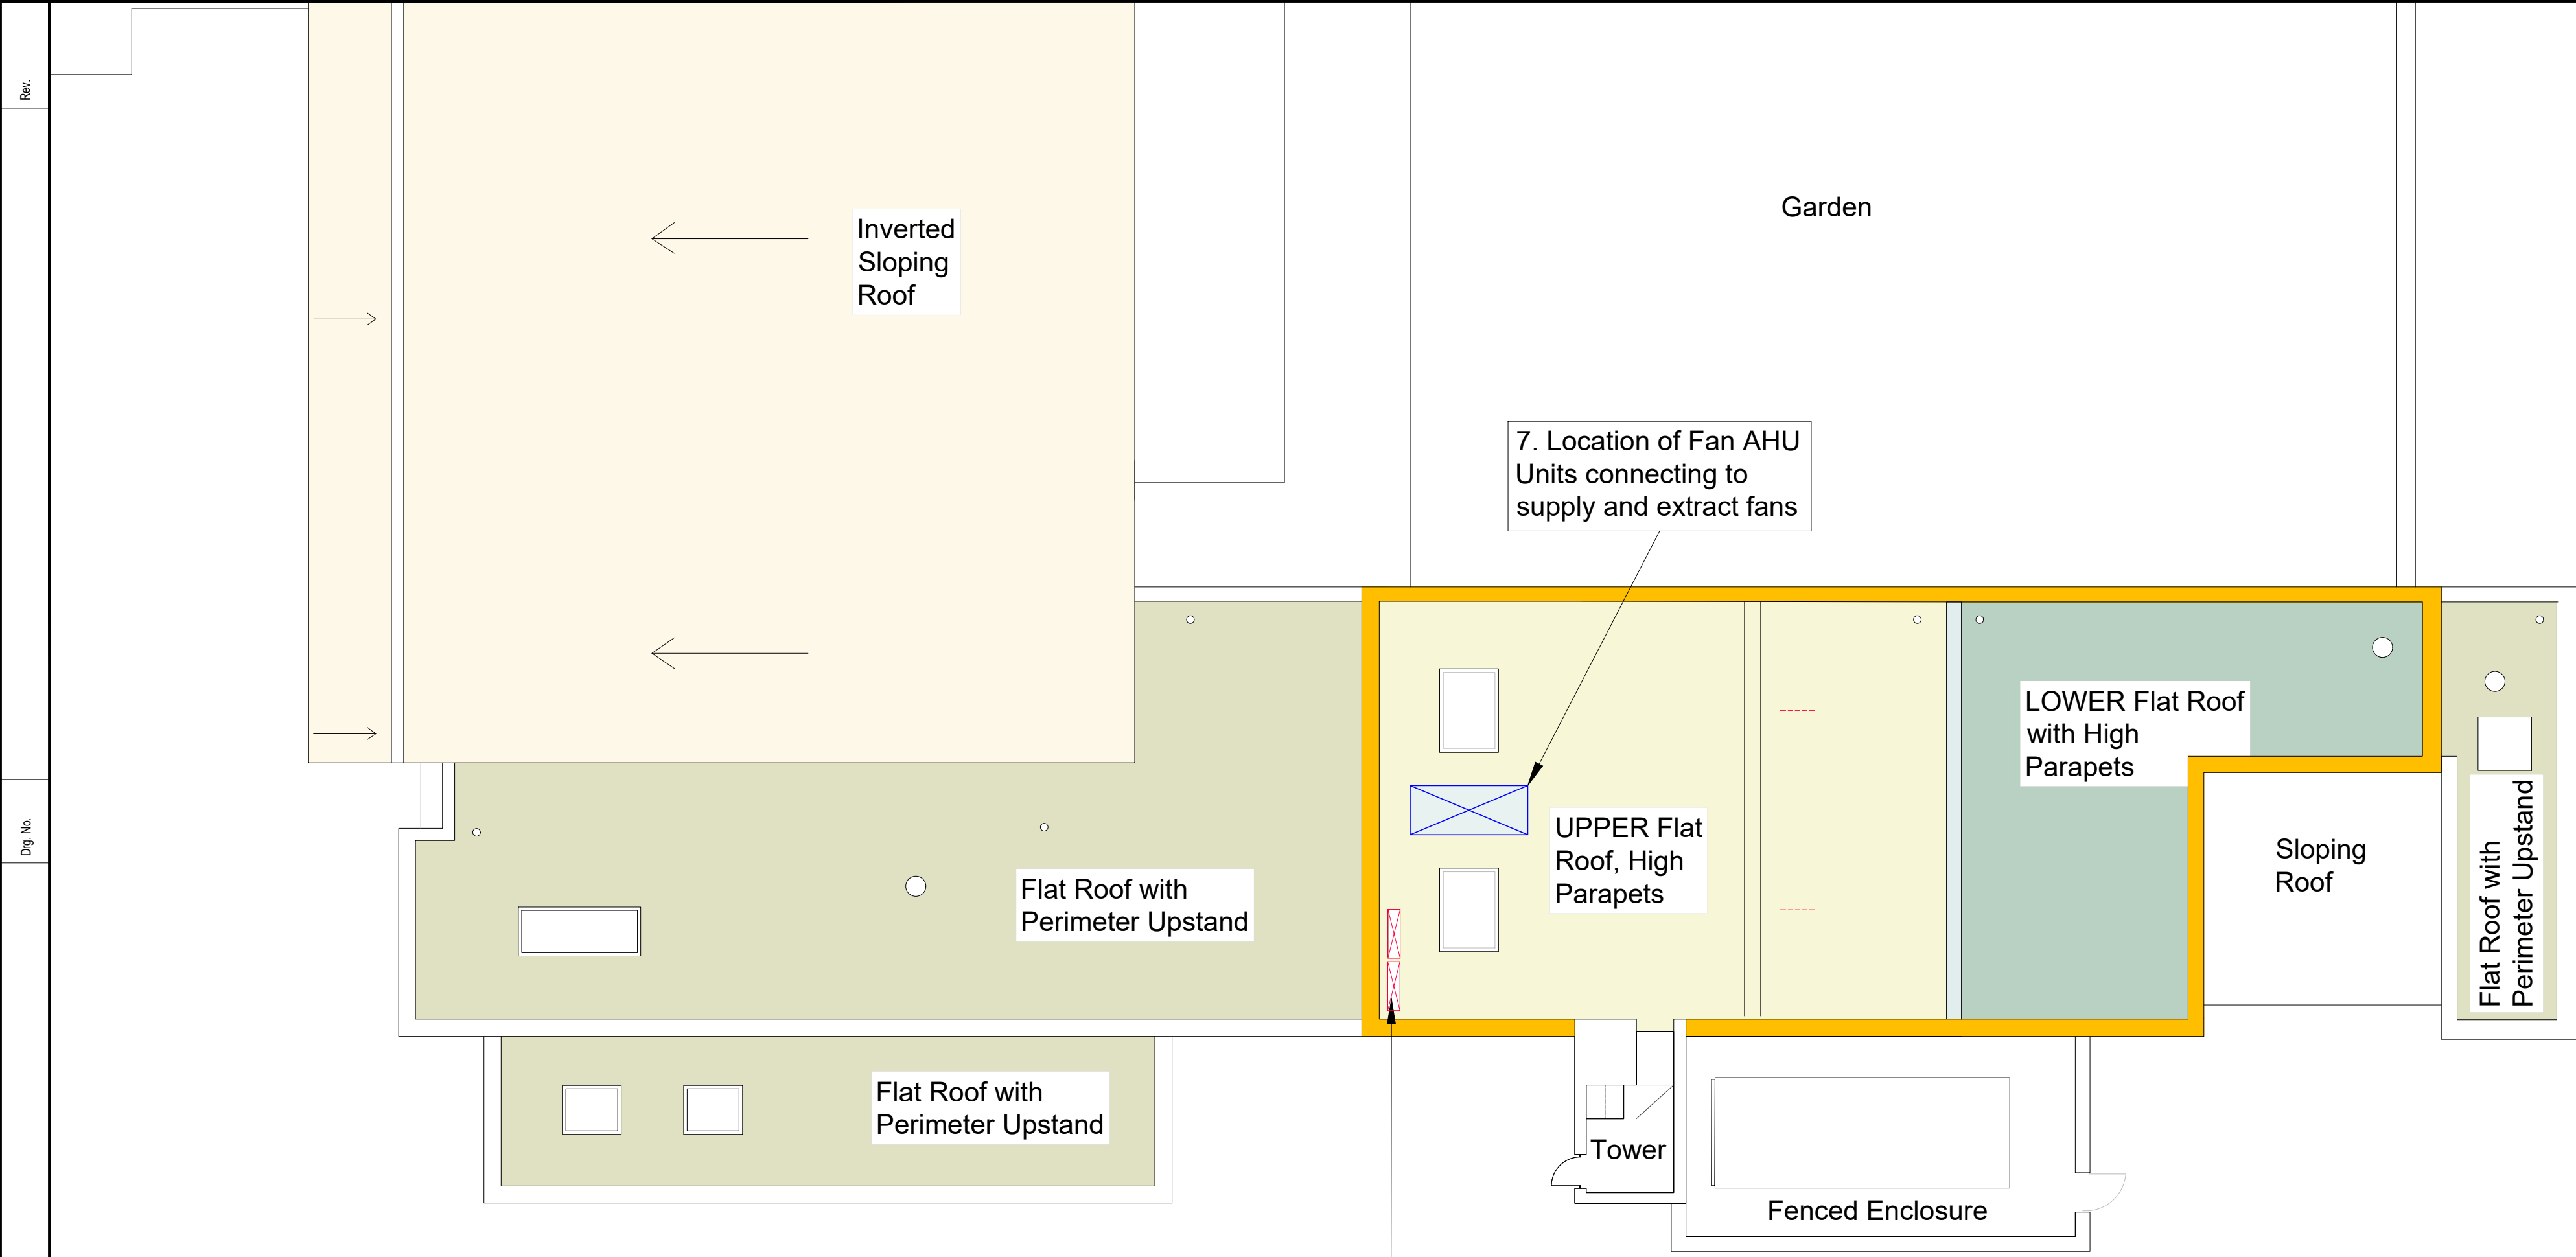

ROOF PLAN

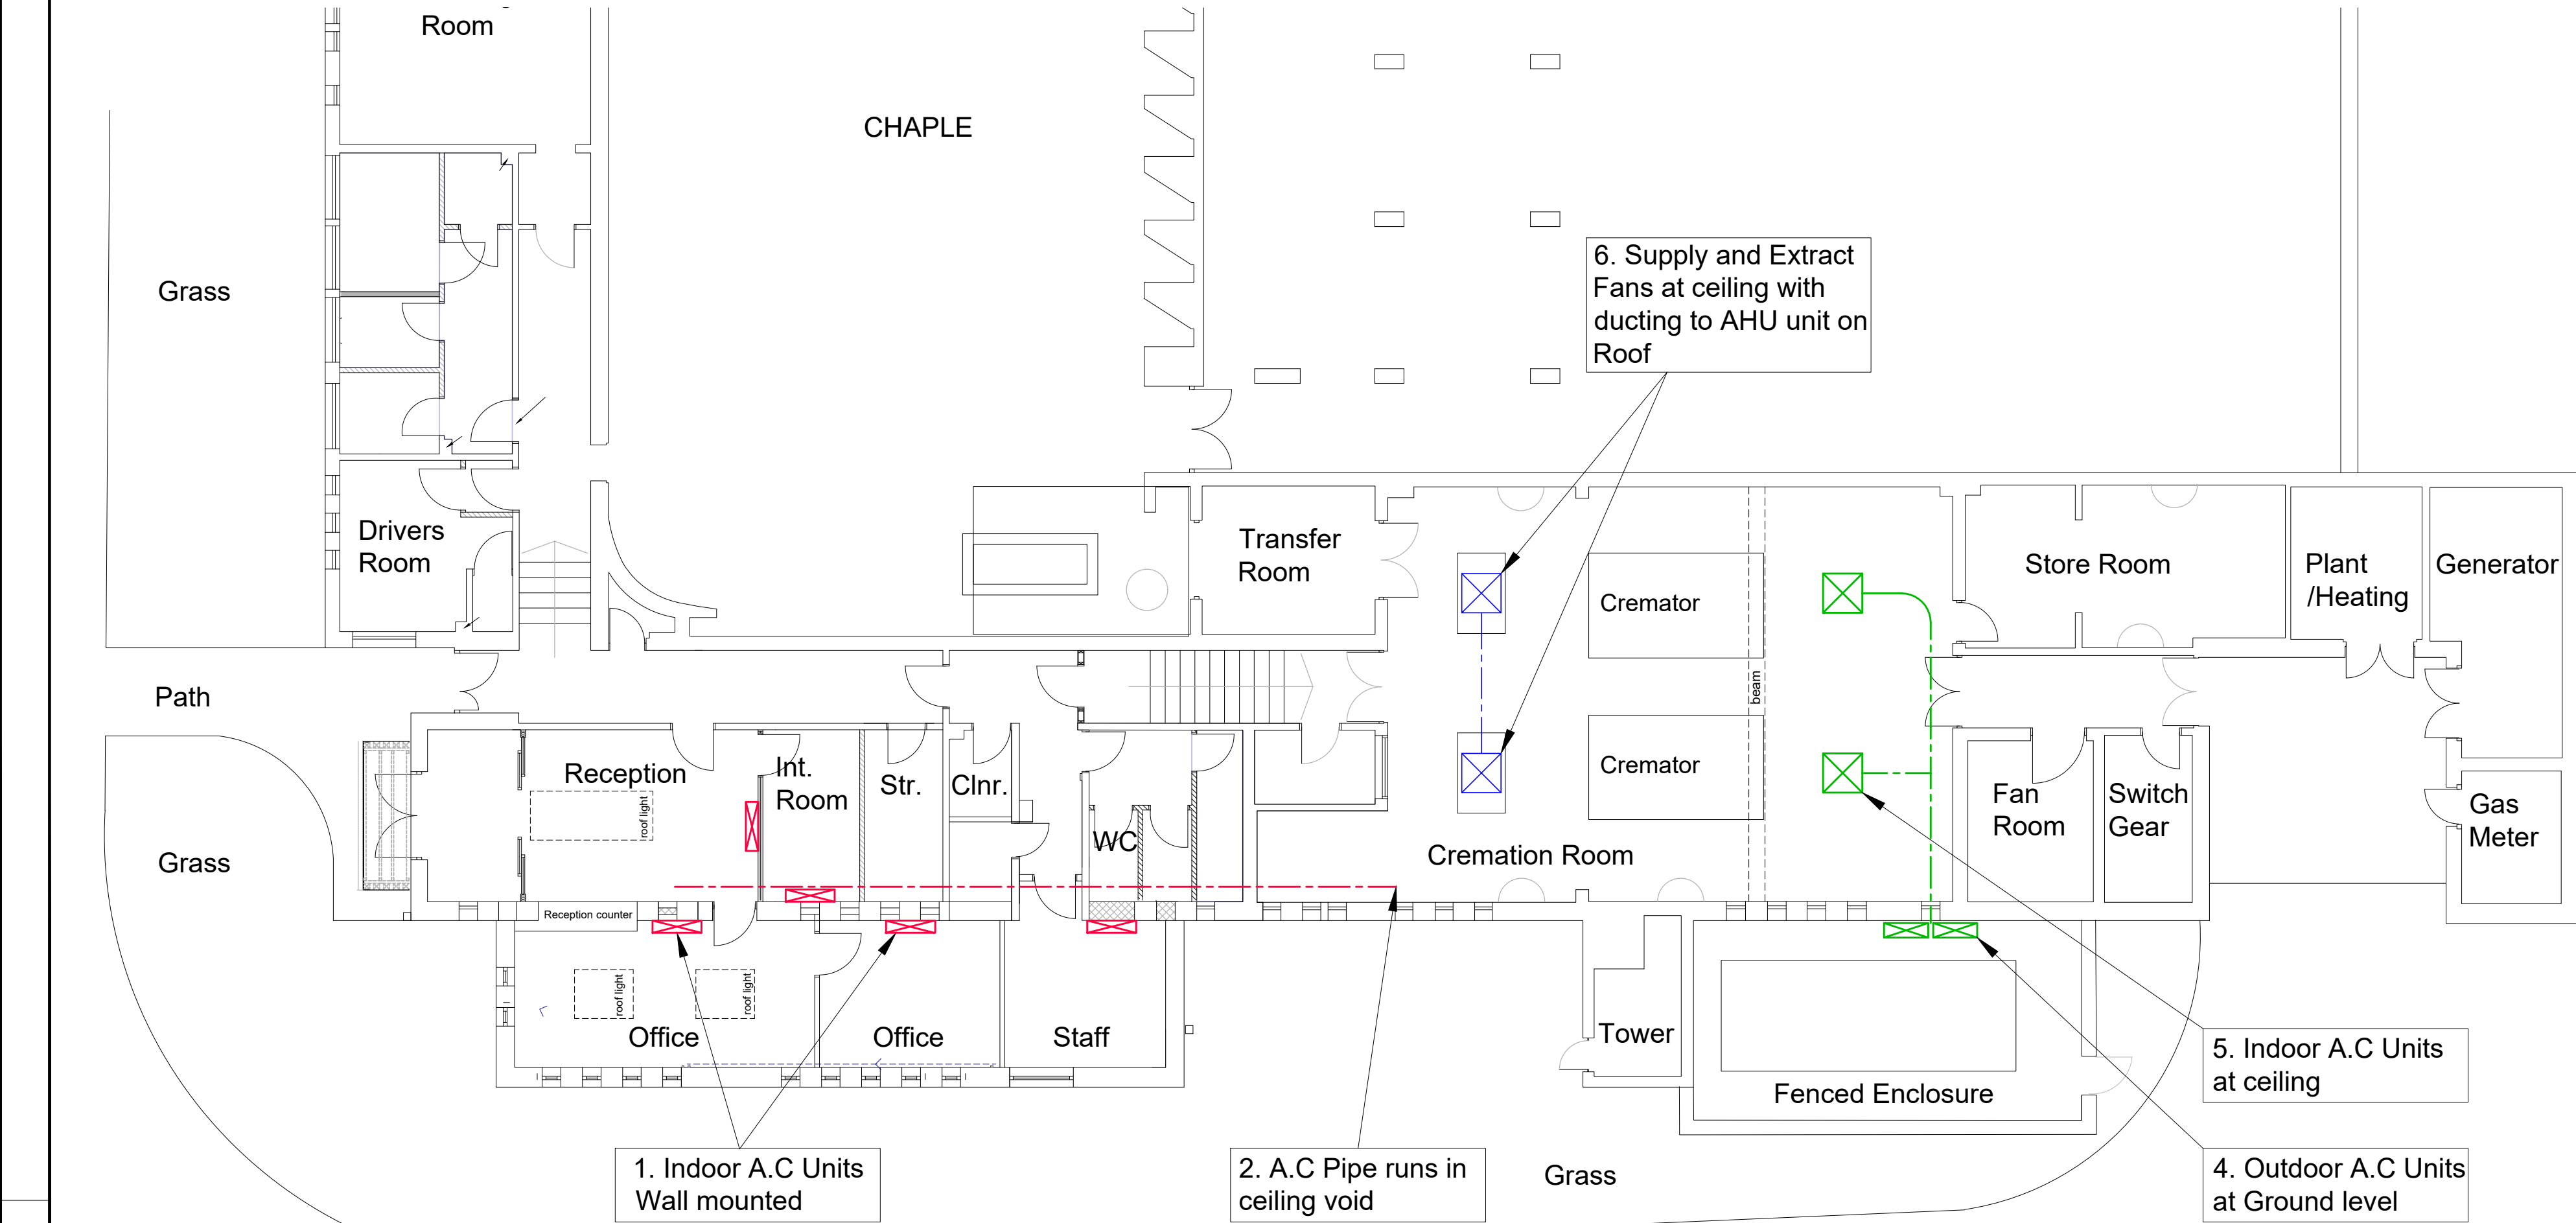

FLOOR PLAN



Upper Roof Photograph

NOTES

Also refer to Heritage Impact Statement

These drawings are intended to confirm the locations and visual impact of installations for the purpose of Listed Building Consent. Installations are to be directed by the Mechanical and Electrical Engineer with appropriate H&S details, CDM and contract administration.

All contractors method statements for installation to be approved by SE prior to installation.

System 1

Item 1
Locations of Indoor Air Conditioning units at offices. Fix to walls at high level and refer to Mechanical and Electrical Engineers specifications for make and model. Connection to Outdoor Air Conditioning units, Item 3

Item 2
Air conditioning pipes between indoor and outdoor units are to be fixed in the ceiling void over offices. All M&E fittings in the Cremation Room are to be visible, as original architect's design intent.

Item 3
Location of Outdoor Air Conditioning Units fixed at roof against inner face of Parapet wall. Connections through the roof fabric with appropriate 'top hat' seals in the roof membrane.

System 2

Item 4
Location of Outdoor Air Conditioning Units as Appendix 1, LUZ outdoor Air Conditioning Unit. Fixed at ground level with cable and pipes through uPVC window panel. All M&E fittings in the Cremation Room are to be visible, as original architect's design intent.

Item 5
Location of Indoor Air Conditioning Units as Appendix 2, Under Ceiling Cassette A.C.

System 3

Item 6
Location of Extract Fans as Appendix 3. Under ceiling extract fan connecting to Air Handling Unit on roof.

Item 7
Approximate location of Air Handling Unit on roof. Unit model and dimensions as Appendix 4.

NOTES

1. All dimensions in millimetres unless otherwise stated.

Rev	Details	Dr	Ch	Apr	Date



Neath Port Talbot

Castell-nedd Port Talbot

County Borough Council Cyngor Bwrdeistref Sirol

Making a difference Gwahaniaeth er gwell

PROPERTY & REGENERATION

Nicola Pearce BSc(Hons) DipTP MRTPI

DIRECTOR OF ENVIRONMENT AND REGENERATION

THE QUAYS, BRUNEL WAY

BAGLAN ENERGY PARK SA11 2GG

www.npt.gov.uk

Project

MARGAM CREMATORIUM
AIR CONDITIONING

Drawing Title

Applic. for Listed Building Consent
Equipment Locations

File No.	Property Ref. No.
Drawn	TJE
Checked	
Date	Aug 2023
Date	
Date	
Date	
Scales	1:100 @ A1
Drawing No.	A1284-03
Rev.	