


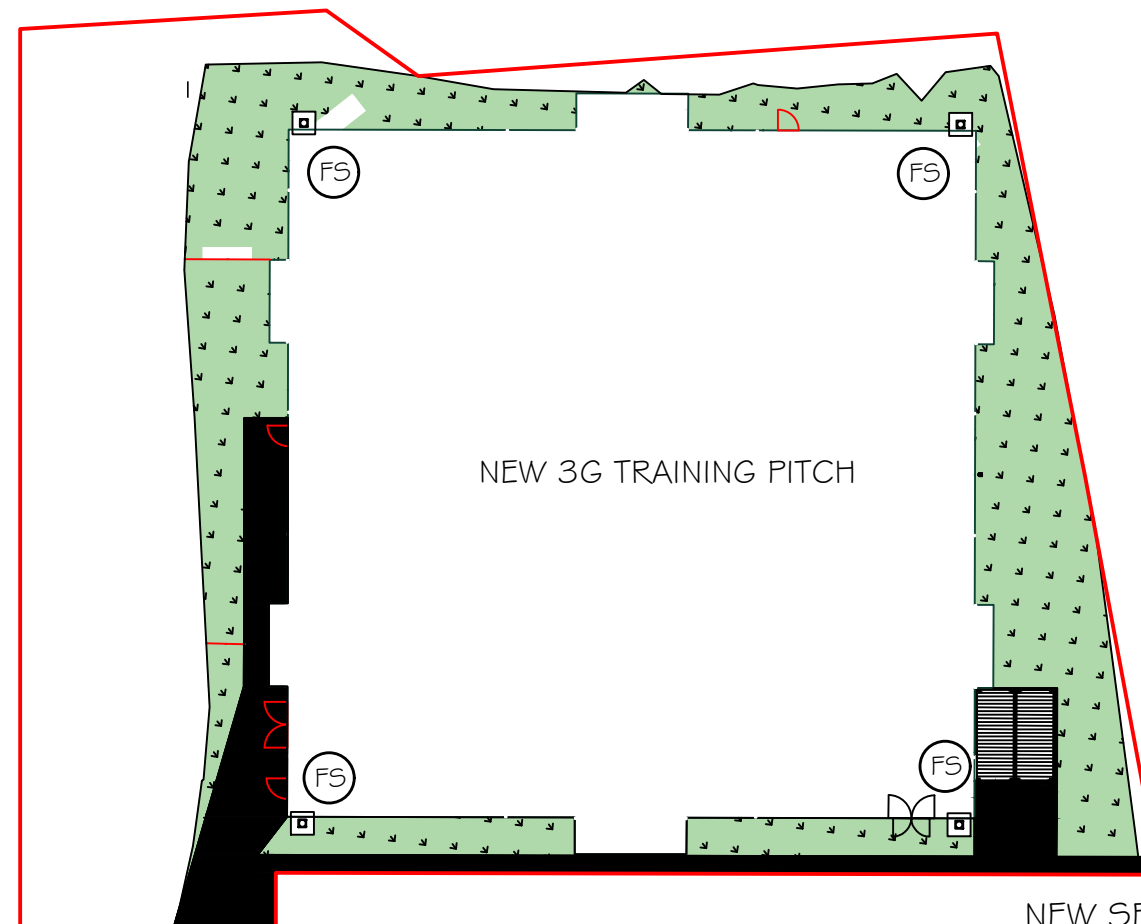

NEW SECURE STORAGE CONTAINERS
2 NO. 2.75 X 6.0 X 2.6m HIGH

PLAN ON NEW TRAINING PITCH
SHOWING NEW FLOODLIGHTING STANCHIONS (FS)

PETER JONES
TALBOT DESIGN SERVICES
mobile: 07817538014
email: jonespeter177@gmail.com

project title
Trefelin Boys and Girls Club
proposed 3G Training Pitch

drawing title
new 3G training pitch
FLOOD LIGHTING PLAN

date January 2024 scale 1:500
drawing No TBGC - TP 02