




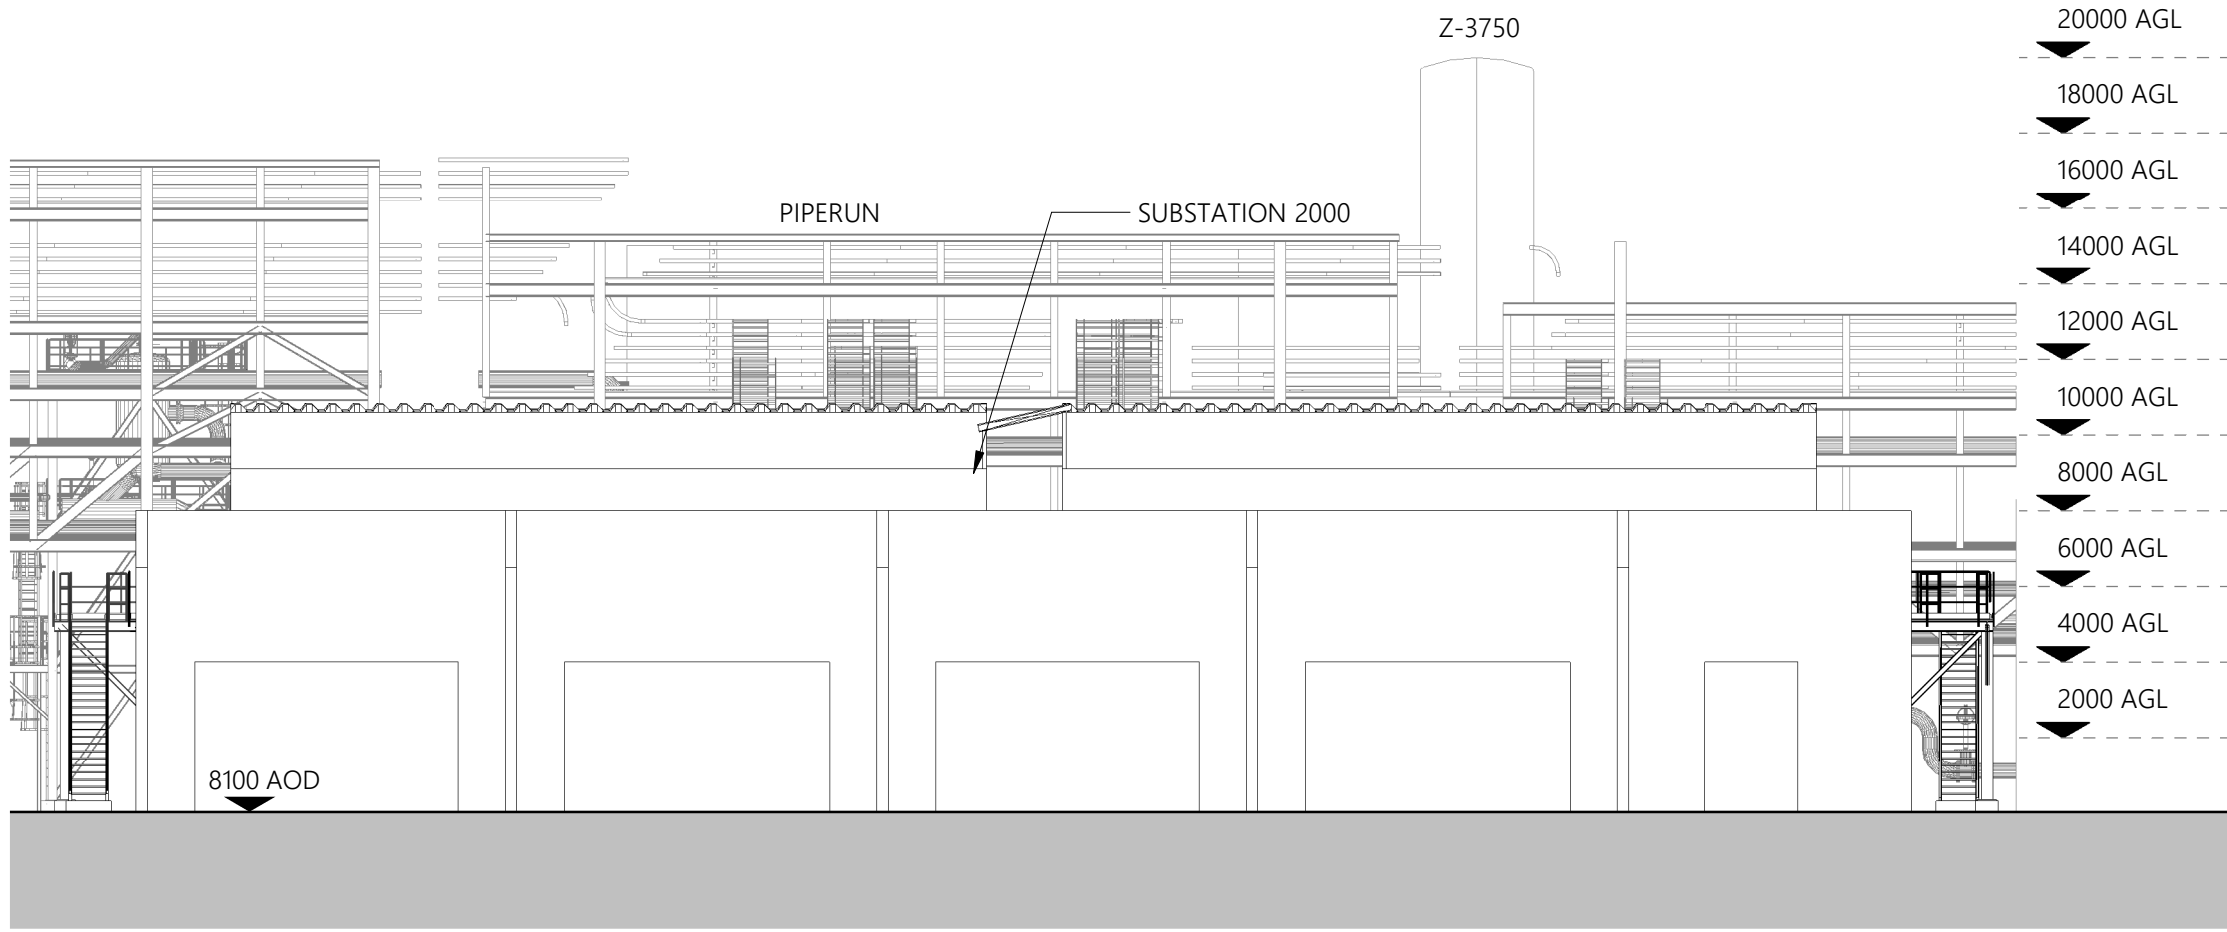


1 Proposed Zone 14 East Elevation
1 : 200

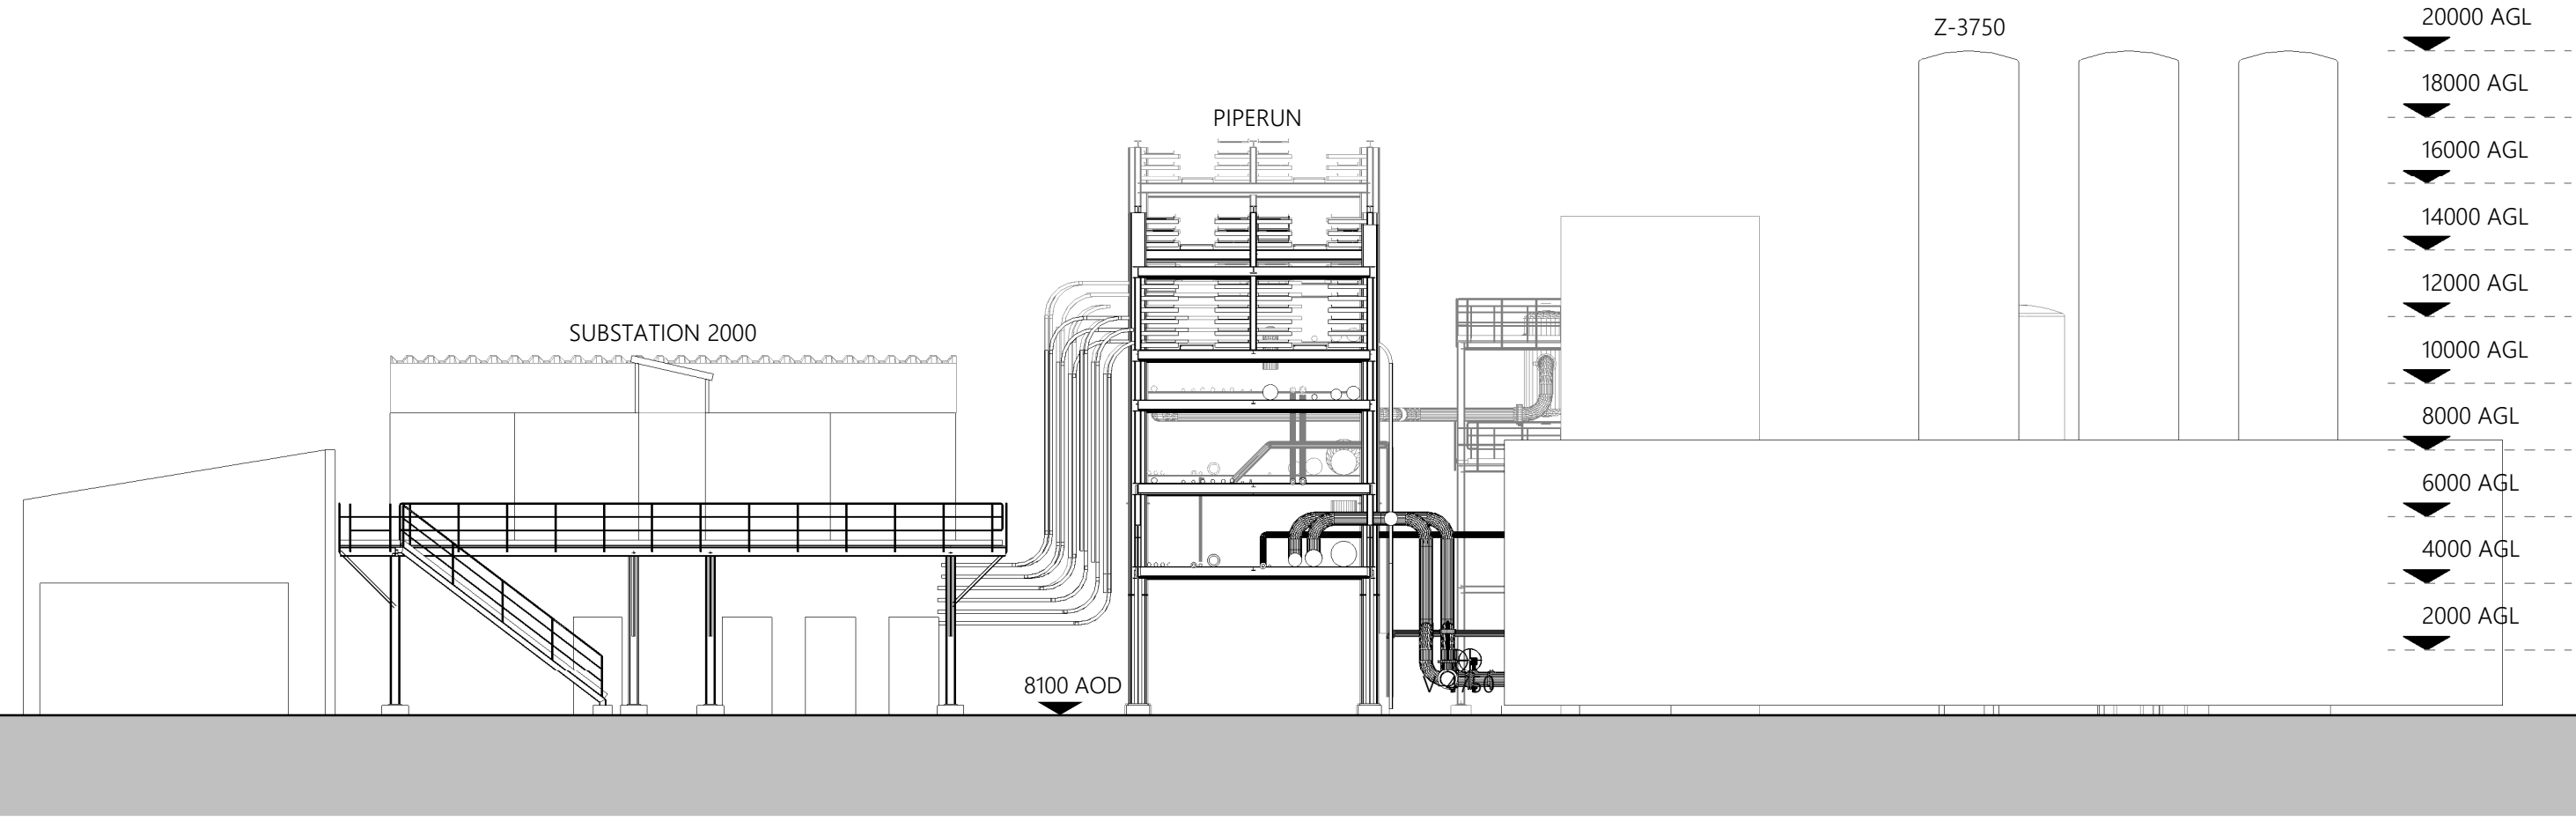

2 Proposed Zone 14 North Elevation
1 : 200

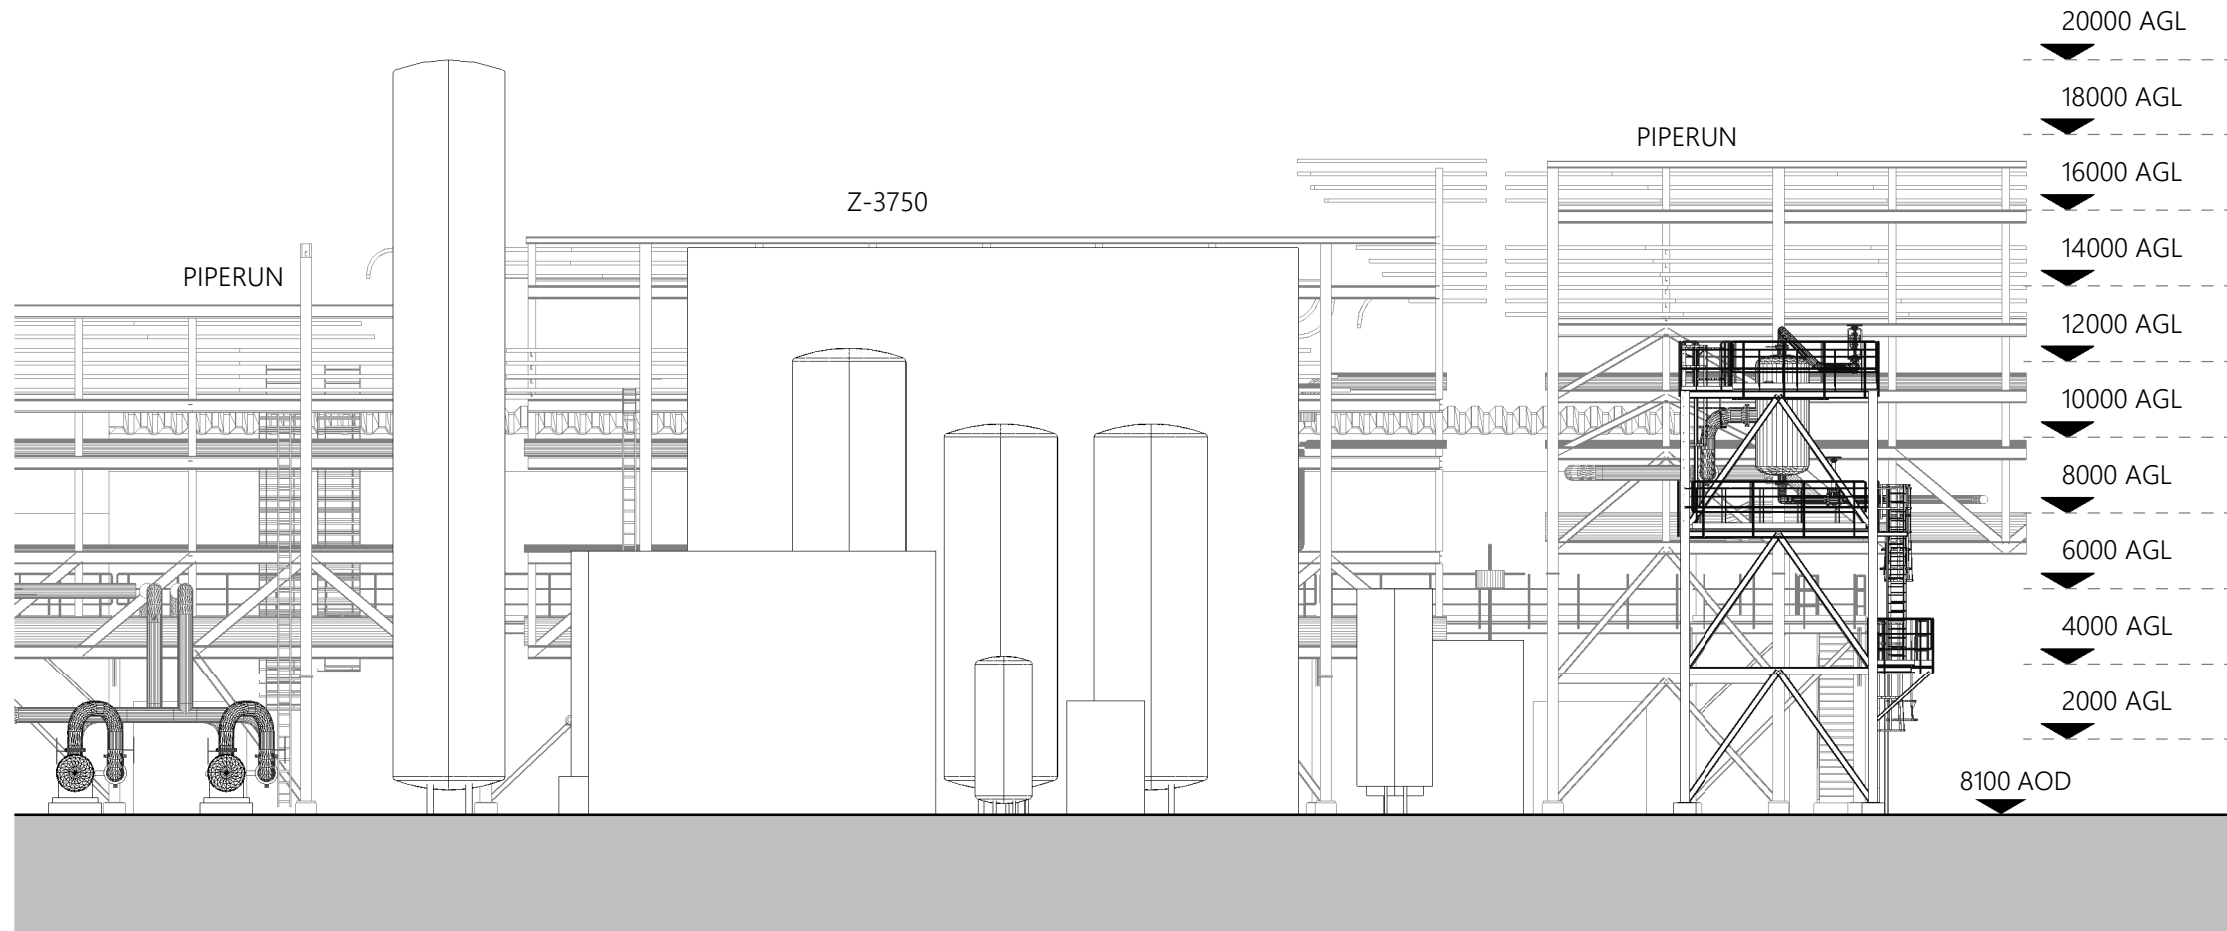

3 Proposed Zone 14 West Elevation
1 : 200

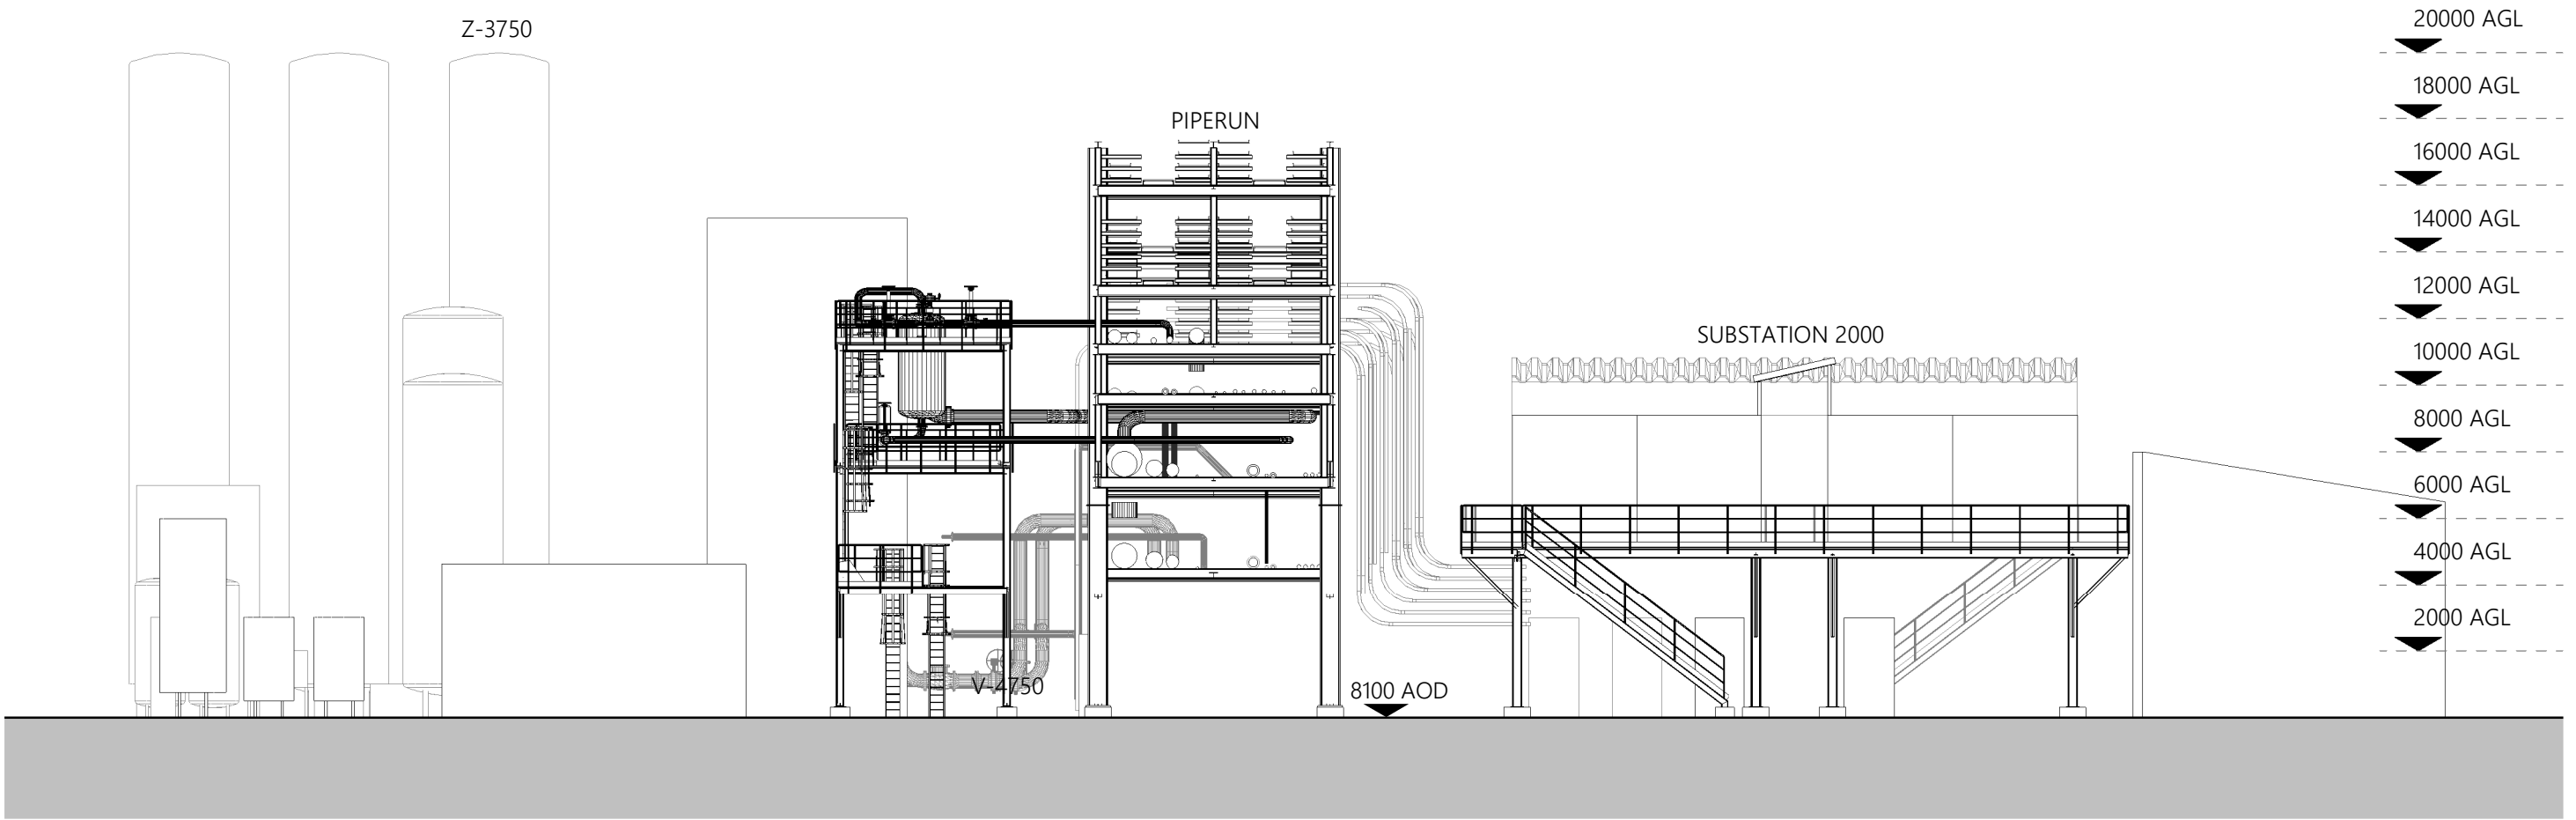

4 Proposed Zone 14 South Elevation
1 : 200


(c) 2023 Sophem Limited
info@inspirearchitects.co.uk
www.inspirearchitects.co.uk

Sophem Limited t/a Inspire Architects
Heywood House, Heywood. BA13 4NA
01749 605006



GENERAL NOTES

- All works proposed shall be conducted in accordance with the related H&S and CDM regulations. Where doubt arises over any aspect of safety, consult Inspire Architects.
- Should any discrepancy be found on this drawing or related project information then the matter should be brought to the attention of Inspire Architects for resolution as soon as possible.
- This drawing may be based on a measured survey or Ordnance Survey information. Do not scale from this drawing unless for planning purposes.
- All dimensions are in millimetres unless otherwise stated. Do not scale from this drawing. All information and layouts detailed on this drawing are subject to site dimension checks.
- Copyright - All Inspire Architects drawings are the property and copyright of Sophem Limited and are not to be used for any purpose without prior written agreement.

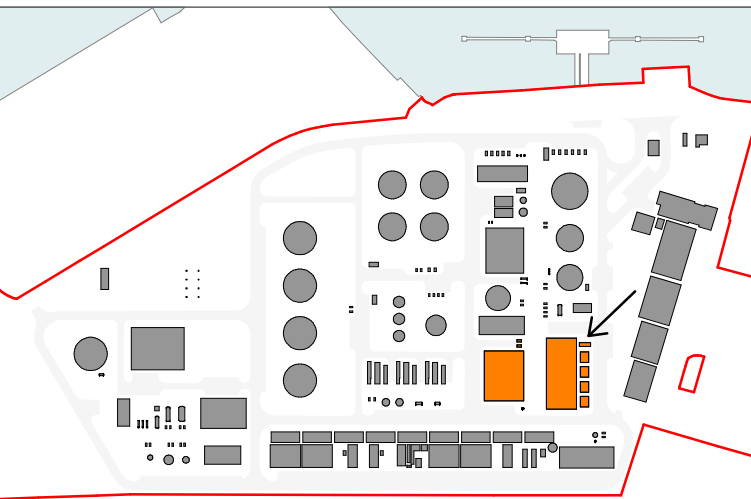

Site Key Plan - Zone 14 Shown in Orange

NOTES

- Survey information taken directly from drawings issued on December 2021 by AP Land Surveys.
- Inspire Architects are not responsible for the design of the plant equipment identified on this drawing.
- All tanks to be goosewing grey, all metalwork to be galvanised.

Revision	Drawn	Checked	Date
P6	CH	NC	02.11.2023
P5	CH	NC	31.10.2023
P4	CH	NC	11.08.2023
P3	CH	NC	09.08.2023
P2	CH	NC	25.07.2023
P1	CH	NC	17.07.2023



PROJECT NAME
Project Dragon - Sustainable Aviation Fuel (SAF) Production Facility

CLIENT
LanzaTech UK Limited

SHEET NAME
Proposed Zone 14 Plant Elevations - Substation 2000 & Liquid Nitrogen Storage

SHEET SIZE A1	SCALE 1 : 200 @ A1
STATUS CODE S2	STATUS PLANNING

REVISION DATE 02.11.2023	REVISION P6
-----------------------------	----------------

DRAWING NUMBER
2143.01-IA-ZZ-ZZ-DR-A-0514