


LIGHTING COLUMN SPECIFICATION (FS)

1.5m Octagonal base hinged flanged column 94 (4 no.)
HD Galvanised.Design Capacity
0.718m2 Windage&100kg top load or 0.5m2&150kg top load
to 29m/s basic wind speed(10-min mean)Terrain

LIGHTING UNIT SPECIFICATION

AMNIS Match (2 No. per column)
87,000lum.lm, 665W, 131lm/W, 6 Row,
Fixed Output Driver,
Narrow Short Throw Optic, 4000K, IP66, IK08,
RAL7016 30% Gloss Anthracite
Grey Marine Grade Finish.

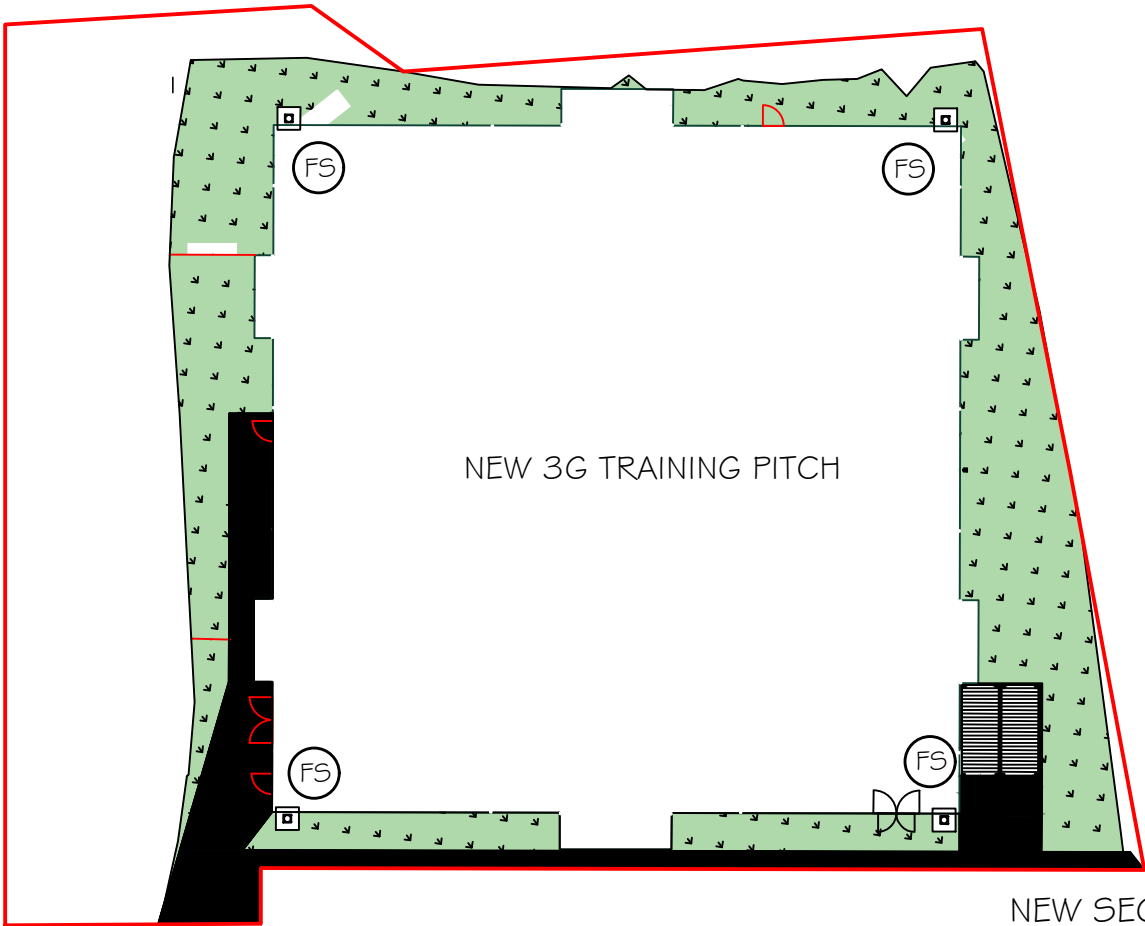

NEW SECURE STORAGE CONTAINERS
2 NO. 2.75 X 6.0 X 2.6m HIGH

PLAN ON NEW TRAINING PITCH
SHOWING NEW FLOODLIGHTING COLUMNS (FS)

REVISION A 09.02.24
floodlighting specification added

PETER JONES
TALBOT DESIGN SERVICES
mobile: 07817538014
email: jonespeter177@gmail.com

project title
Trefelin Boys and Girls Club
proposed 3G Training Pitch

drawing title
new 3G training pitch
FLOOD LIGHTING PLAN

date January 2024 scale 1:500
drawing No TBGC - TP 02 Rev A