


LIGHTING COLUMN SPECIFICATION (FS)

10m Octagonal base hinged flanged column 94 (4 no.)
HD Galvanised.Design Capacity
0.718m2 Windage100kg top load or 0.5m2150kg top load
to 29m/s basic wind speed(10-min mean)Terrain

LIGHTING UNIT SPECIFICATION

The design has been completed using the Philips
Asymmetric OptiVision LED GEN 3.5 Floodlights.
A total of 4 No have been used to achieve an
average of 200lux.
Floodlights are mounted on 4 x 10 metre columns.
All Floodlights are fitted with integral louvres to reduce
spill and glare.

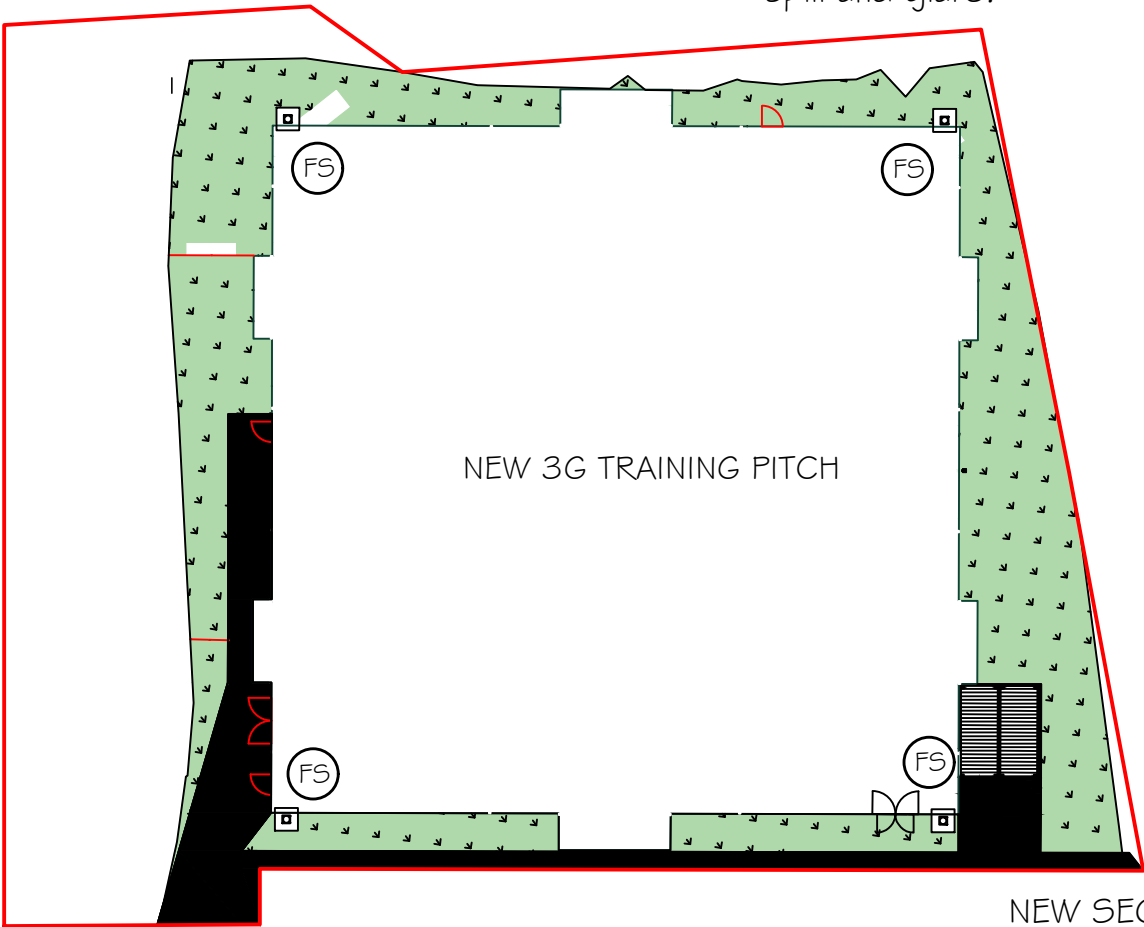

NEW 3G TRAINING PITCH

NEW SECURE STORAGE CONTAINERS
2 NO. 2.75 X 6.0 X 2.6m HIGH

PLAN ON NEW TRAINING PITCH
SHOWING NEW FLOODLIGHTING COLUMNS (FS)

REVISION B 26.04.24
floodlighting specification AMENDED
lighting columns reduced to 10m height
REVISION A 09.02.24
floodlighting specification added

PETER JONES
TALBOT DESIGN SERVICES
mobile: 07817538014
email: jonespeter177@gmail.com

project title
Trefelin Boys and Girls Club
proposed 3G Training Pitch

drawing title
new 3G training pitch
FLOOD LIGHTING PLAN

date January 2024 scale 1:500
drawing No TBGC - TP 02 Rev B