

NOTE:
SURROUNDING CONTEXTUAL BUILDINGS
AND INFORMATION ARE
BASED ON RECEIVED ORDINANCE
SURVEY DRAWINGS AND ARE SHOWN
FOR ILLUSTRATIVE PURPOSES ONLY.
ASSUMED SITE BOUNDARY IS
SUBJECT TO CONFIRMATION

General Notes:
All proposed tree locations are subject to co-ordination with drainage layout and subject to modification depending on the location of underground services and utilities. Drainage engineer to co-ordinate services layout in conjunction with the landscape plan to avoid conflict as much as possible. Allowance to be made at tender stage for the possible requirement for root barriers once the drainage layout is confirmed, CA to be informed immediately once this is available.



0 2 4 6 8 10 20m
Scale: 1:100 @ A1

NORTH

RAIN GARDENS LOCATION PLAN
SCALE 1:100 @ A1



RAIN GARDENS PLANTING LAYOUT
SCALE 1:100 @A1

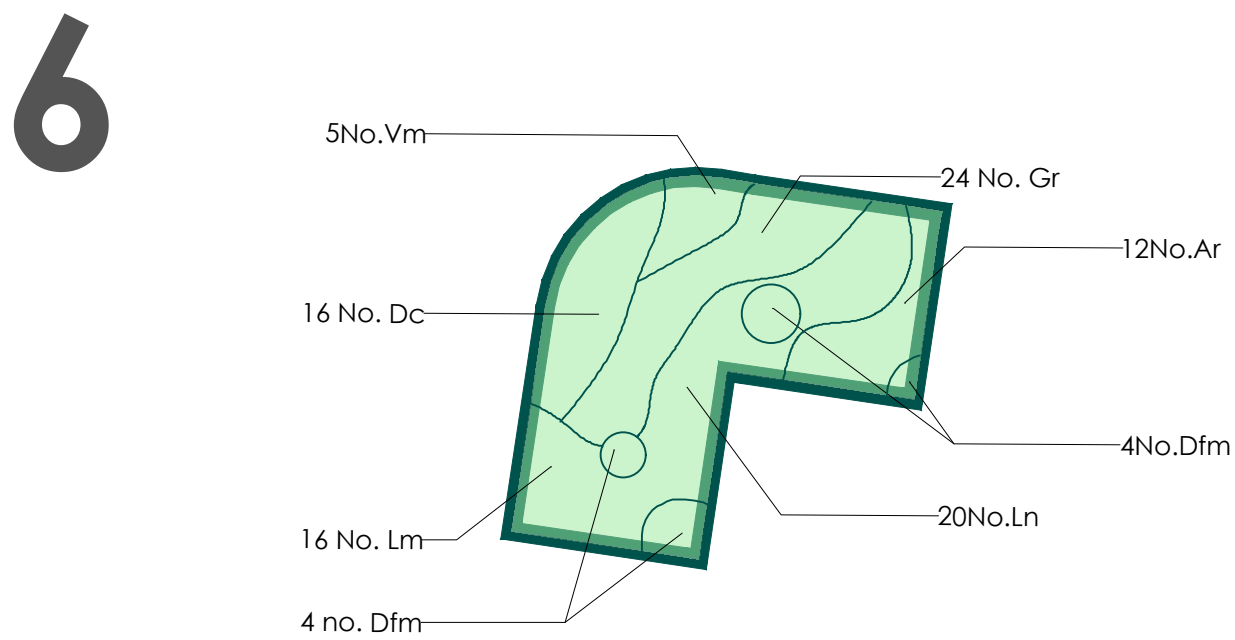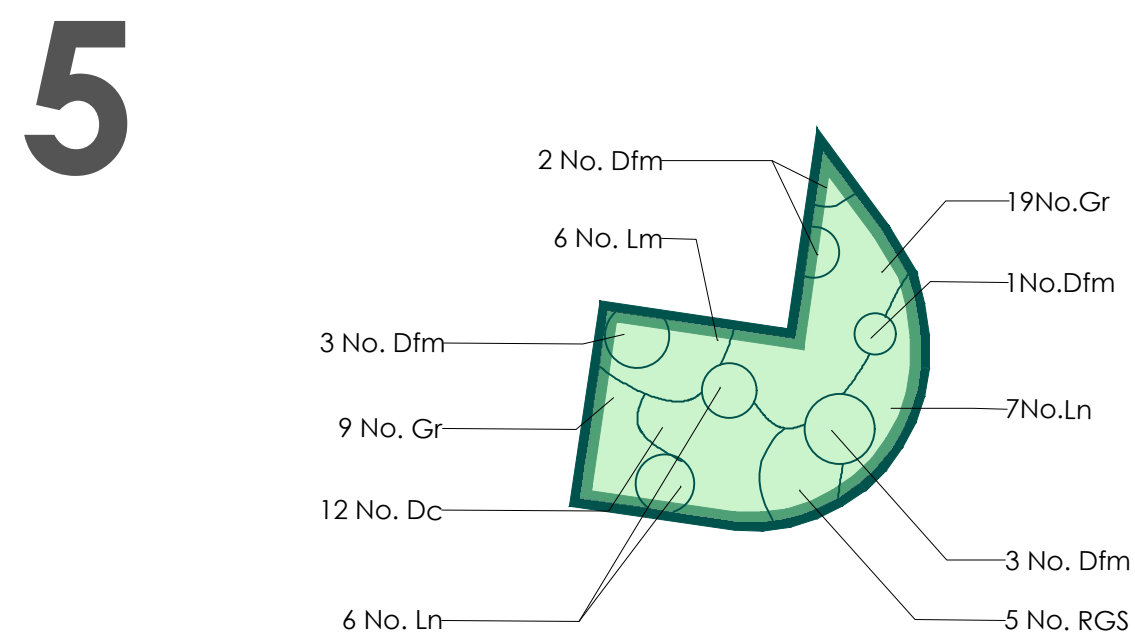

PLANTING PALETTE



Geranium rozanne



Vinca minor



Luzula nivea



Liriope muscari



Rudbeckia 'Gold Star'



Ajuga reptans



Dryopteris filix-mas



Deschampsia cespitosa



Cornus sanguinea



Miscanthus sinensis

PLANTING SCHEDULES

Rain Garden Planting						
Name	Abb	Height (cm)	Root	Container	Habit	Total No.
Ajuga reptans	Ar	/	C	3L	v	12
Dryopteris filix-mas	Dfm	/	C	3L	S	17
Geranium 'Rozanne'	GR	/	C	3L	V	52
Liriope muscari	Lm	/	C	3L	V	22
Luzula nivea	Ln	/	C	3L	S or V	33
Deschampsia cespitosa	Dc	/	C	3L	S or V	28
Rudbeckia 'Gold Star'	RGS	30-40	C	3L	Branches	5
Vinca minor	Vm	/	C	3L	V	5

Specimen Planting:						
Name	Abb	Height (cm)	Root	Container	Habit	Quantity
Amelanchier lamarkii	Al	175-200	RB	-	Specimen 3-5 main stems	1
Phormium 'Apricot Queen'	PAQ	80-100	C	25L	Specimen	1
Phormium cookianum 'Tricolor'	PcT	80-100	C	25L	Specimen	1
Phormium 'Yellow Wave'	PYW	/	C	10-12L	Triple Crown	4
Cornus sanguinea	Cs	60-80	C	5L	Branches	3
Miscanthus sinensis	Ms	/	C	3L	V	3

03/08/23 D Updated landscape plan to coordinate with Engineers plan

02/03/23 C Updated landscape plan to coordinate with architects plan

28/02/23 B Updated landscape plan to coordinate with architects plan - realigned Rain Garden - enable car access

23/02/23 A Updated landscape plan to coordinate with architects plan - realigned SUDS to marry up with new entrance layout

Revisions

Description

Drawn

Check

03/08/23 D Updated landscape plan to coordinate with Engineers plan

22/05/2024 G Updated to coordinate with Architects site plan

13/05/24 F Updated landscape plan to coordinate with architects plan

18/10/23 E Updated landscape plan to coordinate with architects plan

Revisions

Description

Drawn

Check

Project Title

Proposed McDonald's Restaurant

Gwyn's Drift Pontardawe

SA8 3AZ

Client

McDonald's Restaurants Ltd

Status

PLANNING

Scale

1:100

Drawing Size

A1

Drawn By

NB

Checked By

AS

Date

07/2022

Drawing Title

RAIN GARDEN PLANTING PLAN

Job Dwg No

18634-VL-MCD-L03

Rev

G

WAKEFIELD - T. 01924 291800

2 St John's North, Wakefield, WF1 3QA

MANCHESTER - T. 0161 2388555

Carver's Warehouse, 77 Dale Street, Manchester, M1 2HG

MILTON KEYNES - T. 01908 211 577

The Old Rectory, 79 High Street Newport Pagnell, MK16 8AB

READING - T. 0118 950 7700

101 London Road, Reading, RG1 8BY

LONDON - T. 020 7409 1215

10 Gales Court, St Christopher's Place, London, W1U 1JJ