


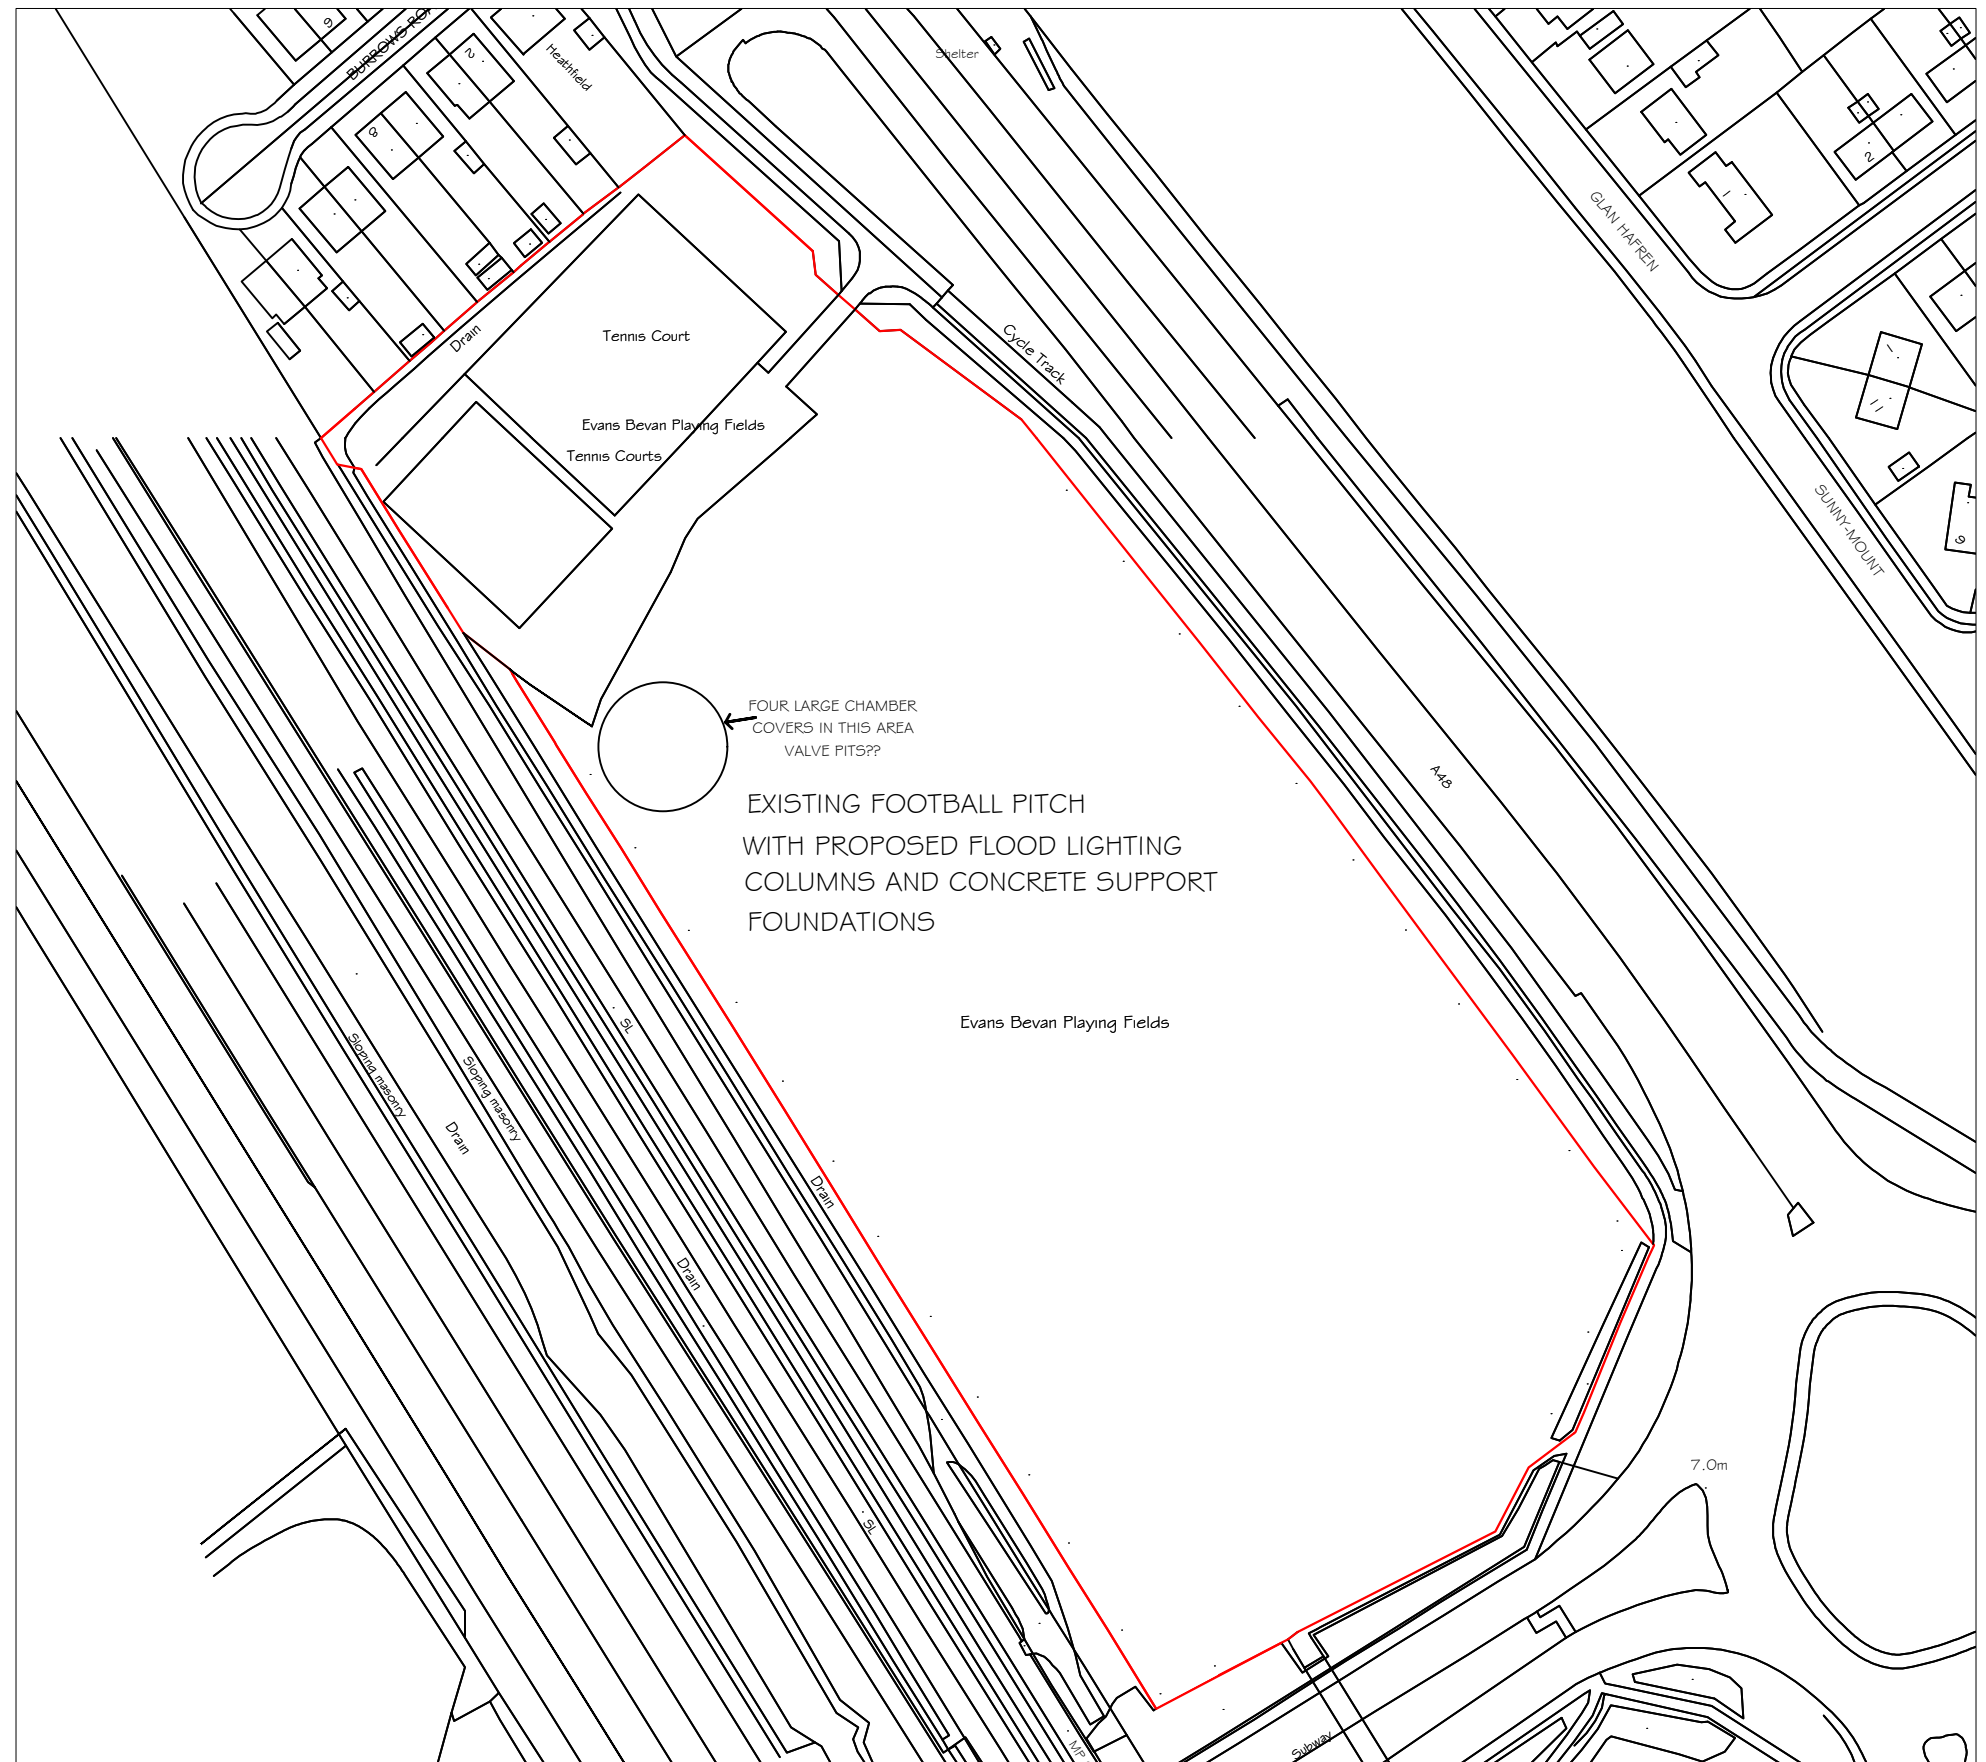

PETER JONES TALBOT DESIGN SERVICES mobile: 07817538014 email: jonespeter177@gmail.com	project title Baglan Boys & Girls Club NEW FLOODLIGHTING	drawing title SITE PLAN	date May 2024	scale 1:1250
			drawing No BBGC - 01	