


A3 SHEET



EXISTING SHOP FLOOR PLAN

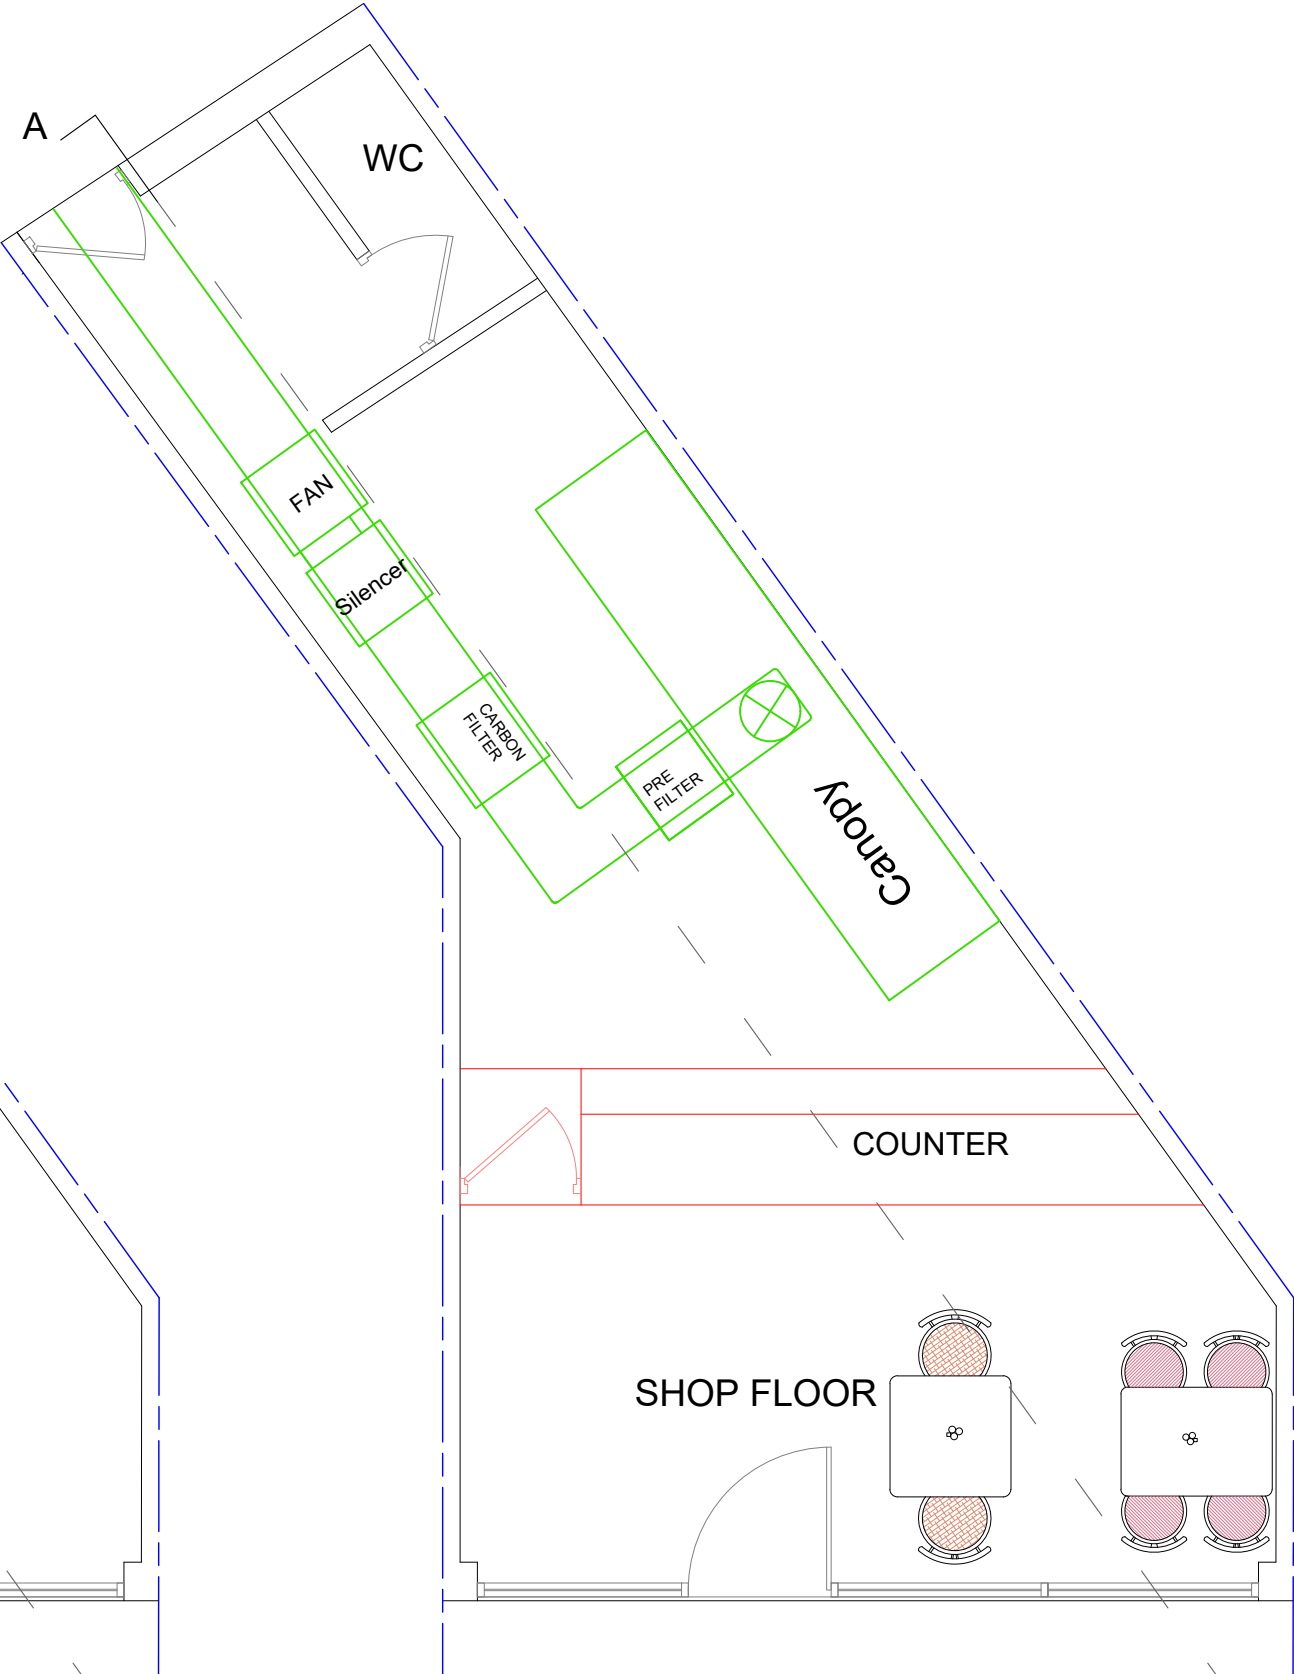

PROPSOED SHOP FLOOR PLAN

TITLE: INSTALLATION OF EXTRACTOR FLUE PIPE

NAME : Mr.K.PONNUTHURAI
ADDRESS : 3 THE PARADE
NEATH
SA11 1PU



Tel : 020 3620 2355
Fax: 020 8425 1312

Web : www.arccidesigns.com
Email: admin@arccidesigns.com

Notes:

- This Drawing is Copyright of ARCCI DESIGNS and may not be reproduced or copied, in whole or in part, without express permission.
- Contractor/Builder to check all dimension on site, Before commencement of any works. Figured dimension only to be used.
- All work shall comply with the latest Building Regulations & be to the satisfaction of the L. Authority.
- Materials shall be suitable for the purpose for which they are used & the quality shall not be lower than that defined in the relevant British standard.

Drg No : AD/24/THE03/PL00


Scale : 1:100

Drwn By: ST

Date : 16.09.2024

Page : 1 of 2

A3 SHEET

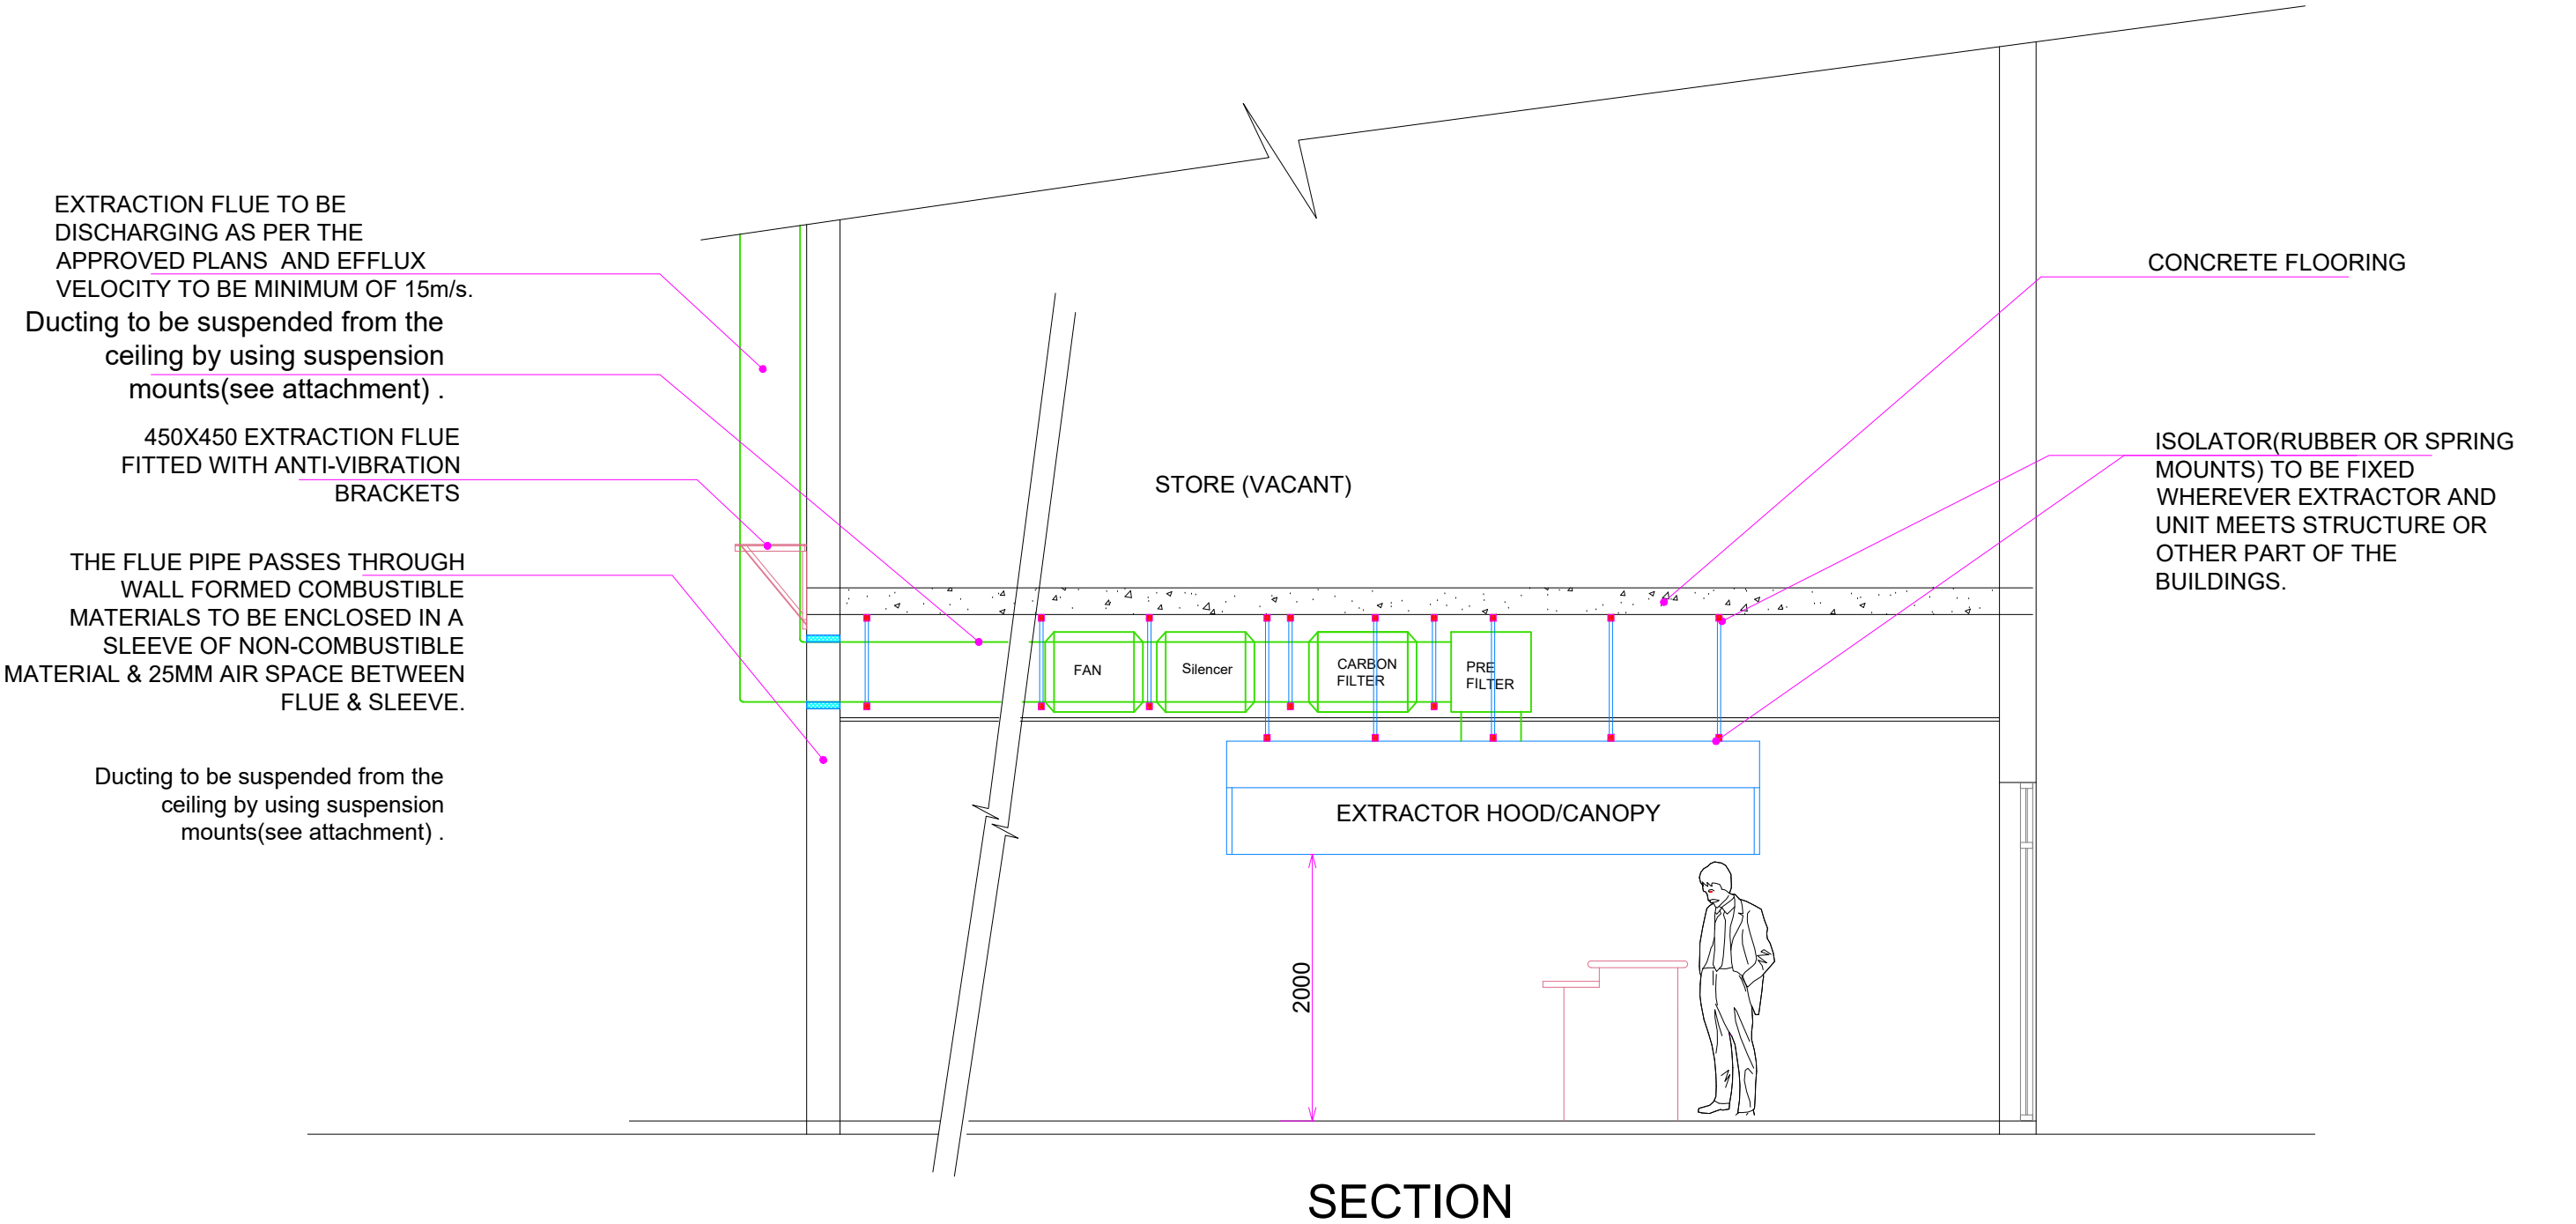

TITLE: INSTALLATION OF EXTRACTOR FLUE PIPE

NAME : Mr.K.PONNUTHURAI
ADDRESS : 3 THE PARADE
NEATH
SA11 1PU



Tel : 020 3620 2355
Fax: 020 8425 1312

Web : www.arccidesigns.com
Email: admin@arccidesigns.com

Notes:

- This Drawing is Copyright of ARCCI DESIGNS and may not be reproduced or copied, in whole or in part, without express permission.
- Contractor/Builder to check all dimension on site, Before commencement of any works. Figured dimension only to be used.
- All work shall comply with the latest Building Regulations & be to the satisfaction of the L. Authority.
- Materials shall be suitable for the purpose for which they are used & the quality shall not be lower than that defined in the relevant British standard.

Drg No : AD/24/THE03/PL00

Scale : 1:100

Drwn By: ST

Date : 16.09.2024

Page : 2 of 2