


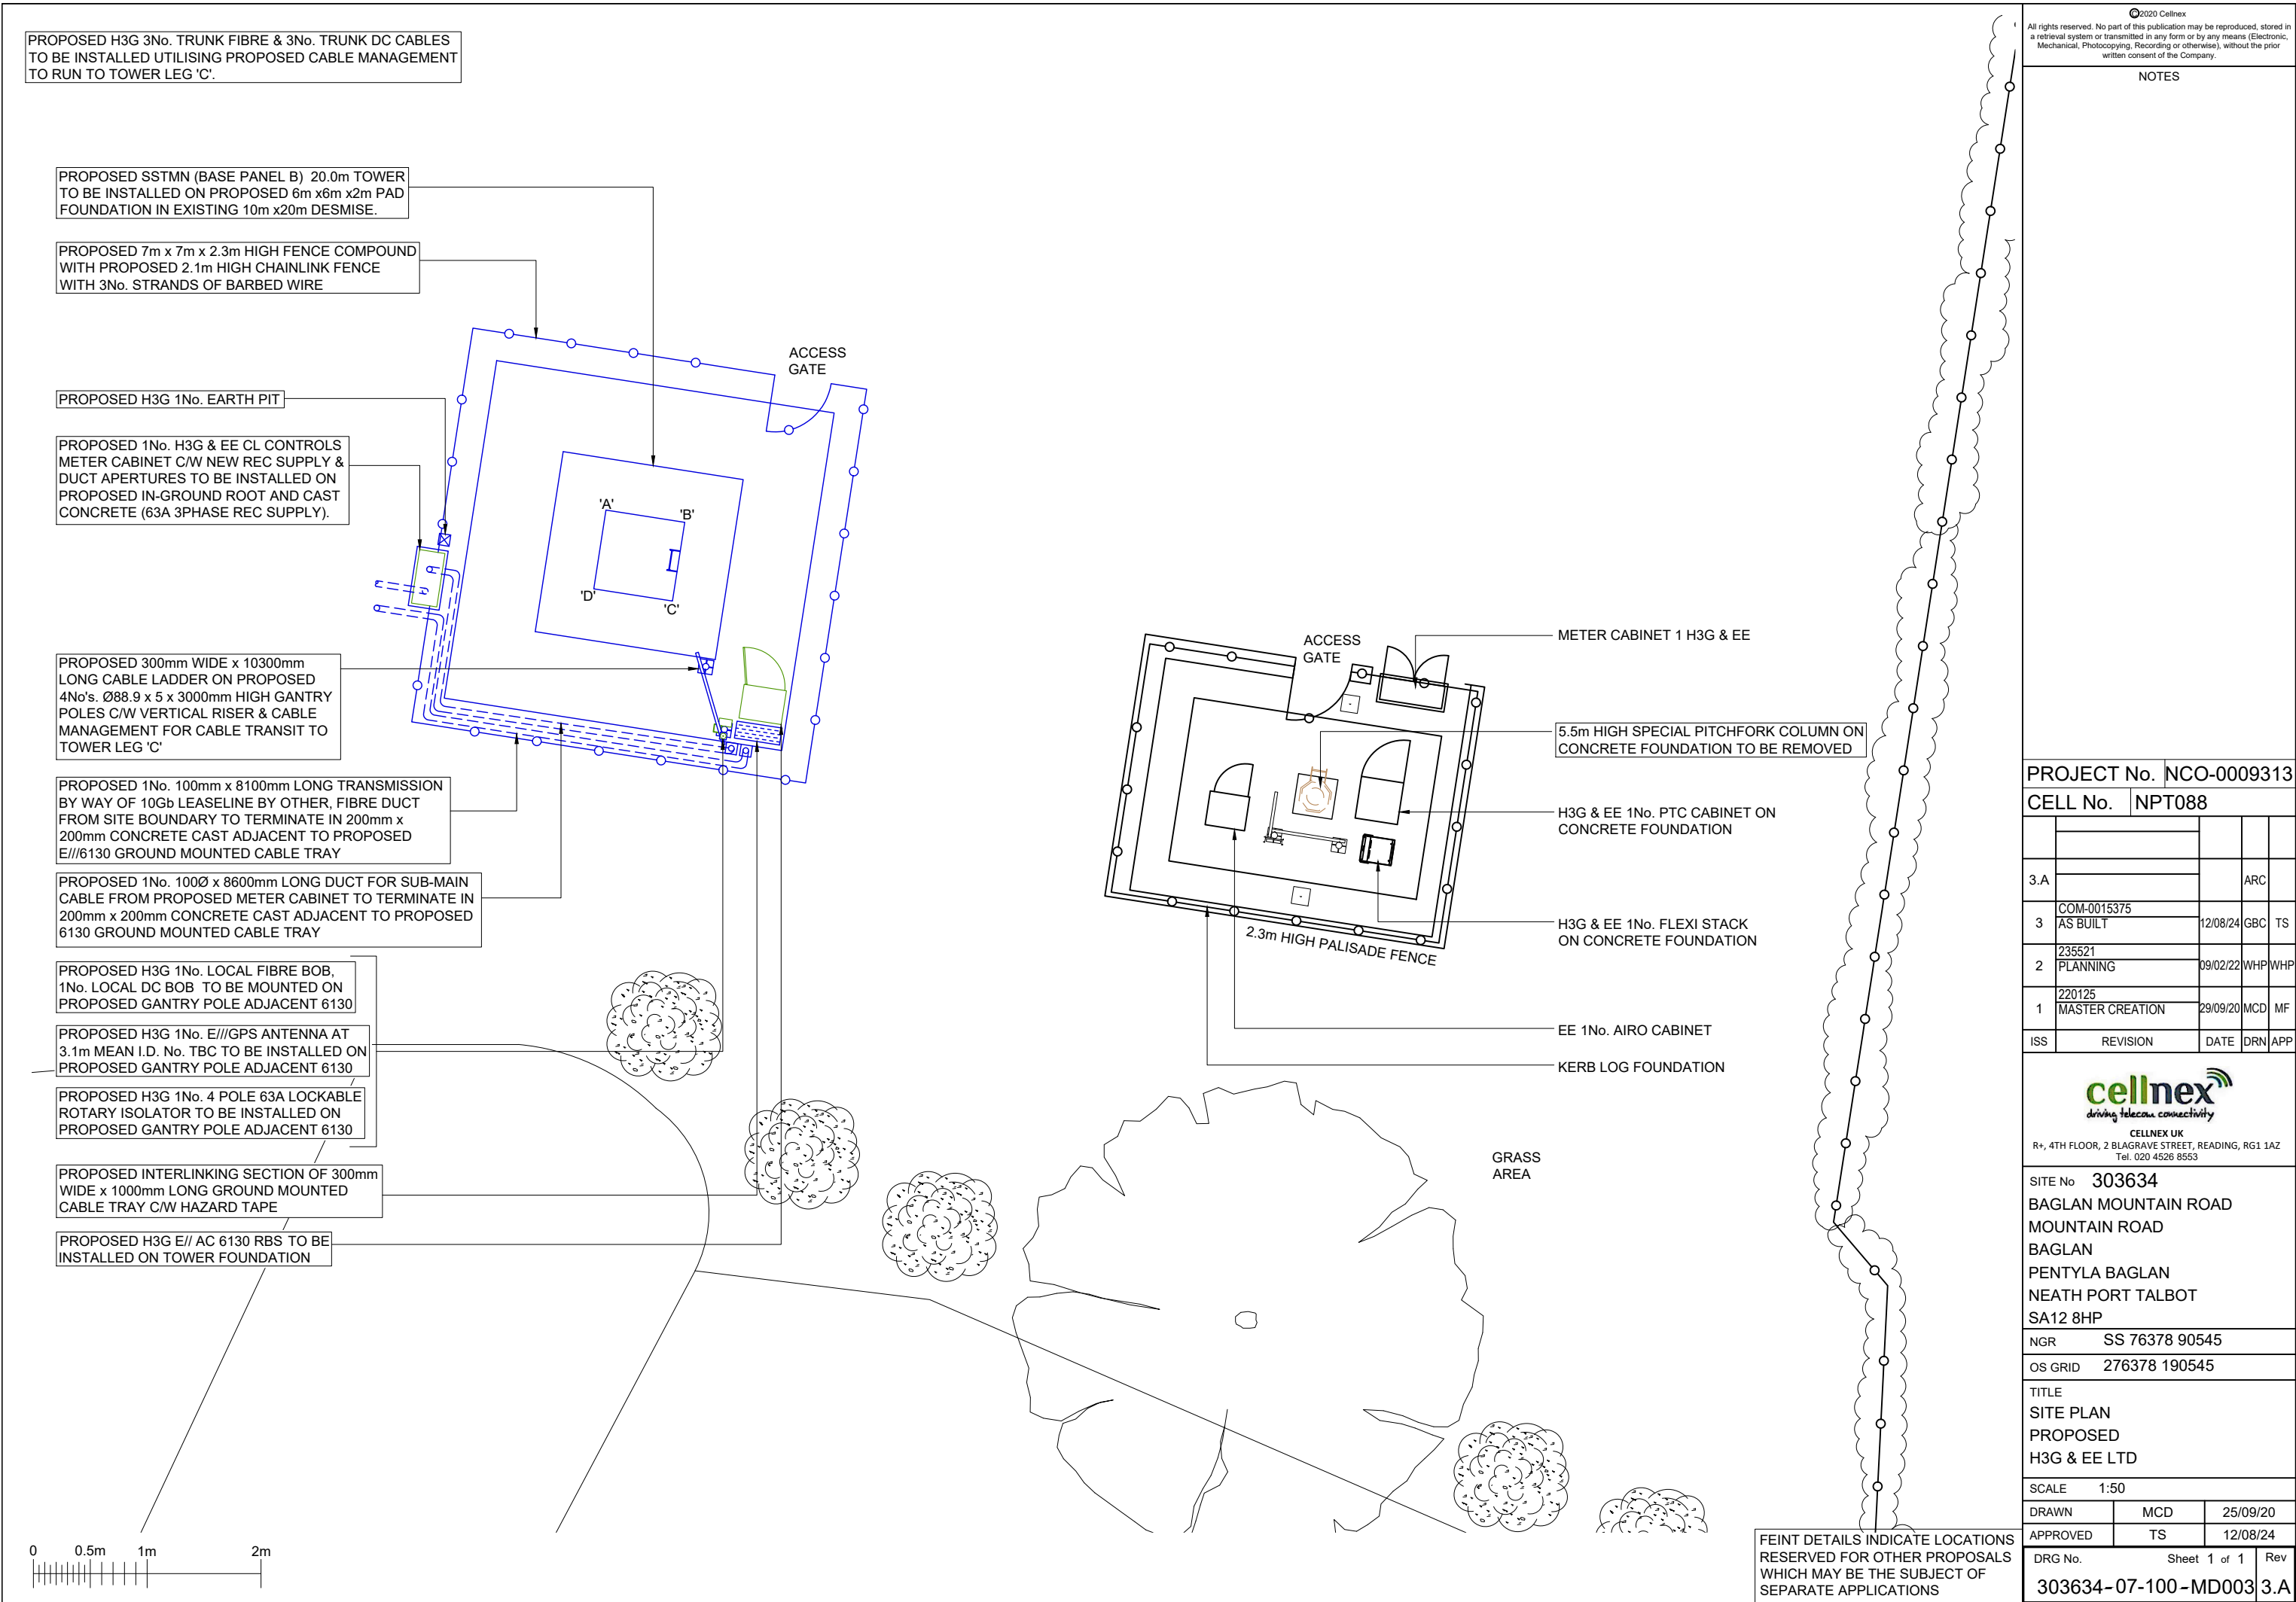

PROPOSED H3G 3No. TRUNK FIBRE & 3No. TRUNK DC CABLES TO BE INSTALLED UTILISING PROPOSED CABLE MANAGEMENT TO RUN TO TOWER LEG 'C'.

PROPOSED 300mm WIDE x 10300mm LONG CABLE LADDER ON PROPOSED 4No's. Ø88.9 x 5 x 3000mm HIGH GANTRY POLES C/W VERTICAL RISER & CABLE MANAGEMENT FOR CABLE TRANSIT TO TOWER LEG 'C'

PROPOSED H3G 1No. LOCAL FIBRE BOB, 1No. LOCAL DC BOB TO BE MOUNTED ON PROPOSED GANTRY POLE ADJACENT 6130

PROPOSED H3G 1No. E///GPS ANTENNA AT 3.1m MEAN I.D. No. TBC TO BE INSTALLED ON PROPOSED GANTRY POLE ADJACENT 6130

PROPOSED H3G 1No. 4 POLE 63A LOCKABLE ROTARY ISOLATOR TO BE INSTALLED ON PROPOSTED GANTRY POLE ADJACENT 6130

PROPOSED H3G E// AC 6130 RBS TO BE INSTALLED ON TOWER FOUNDATION

5.5m HIGH SPECIAL PITCHFORK COLUMN ON CONCRETE FOUNDATION TO BE REMOVED

PROPOSED 1No. H3G & EE CL CONTROLS METER CABINET C/W NEW REC SUPPLY & DUCT APERTURES TO BE INSTALLED ON PROPOSED IN-GROUND ROOT AND CAST CONCRETE (63A 3PHASE REC SUPPLY).

TOP OF STRUCTURE 21.0m

PROPOSED H3G 3No. MAS32 ANTENNAS AT 20.0m MEAN, BEARINGS 305°/100°/210° I.D. No. TBC TO BE INSTALLED ON PROPOSED Ø76.1 x 4 x 3000mm CHS SUPPORT POLES FIXED TO PROPOSED RING HEADFRAMES


PROPOSED H3G 1No. E///2460 700/800 ERS UNIT I.D. No. TBC, 1No. E///4020 1400 ERS UNITS I.D. No. TBC & 1No. E///4490 18/21 ERS UNIT I.D. No. TBC TO BE INSTALLED ON PROPOSED Ø76.1 x 4 x 2000mm CHS SUPPORT POLES FIXED TO PROPOSED RING HEADFRAMES

PROPOSED H3G 3No. REMOTE DC & 3No. REMOTE FIBRE BOB I.D. No. TBC TO BE MOUNTED ON PROPOSED ERS POLES AT ANTENNA LEVEL

PROPOSED SSTMN (BASE PANEL B) 20.0m TOWER TO BE INSTALLED ON PROPOSED 6m x6m x2m PAD FOUNDATION IN EXISTING 10m x20m DESMISE.

PROPOSED 7m x 7m x 2.3m HIGH FENCE COMPOUND WITH PROPOSED 2.1m HIGH CHAINLINK FENCE WITH 3No. STRANDS OF BARBED WIRE

PROPOSED 6m x 6m x 2m DEEP BESPOKE CONCRETE FOUNDATION

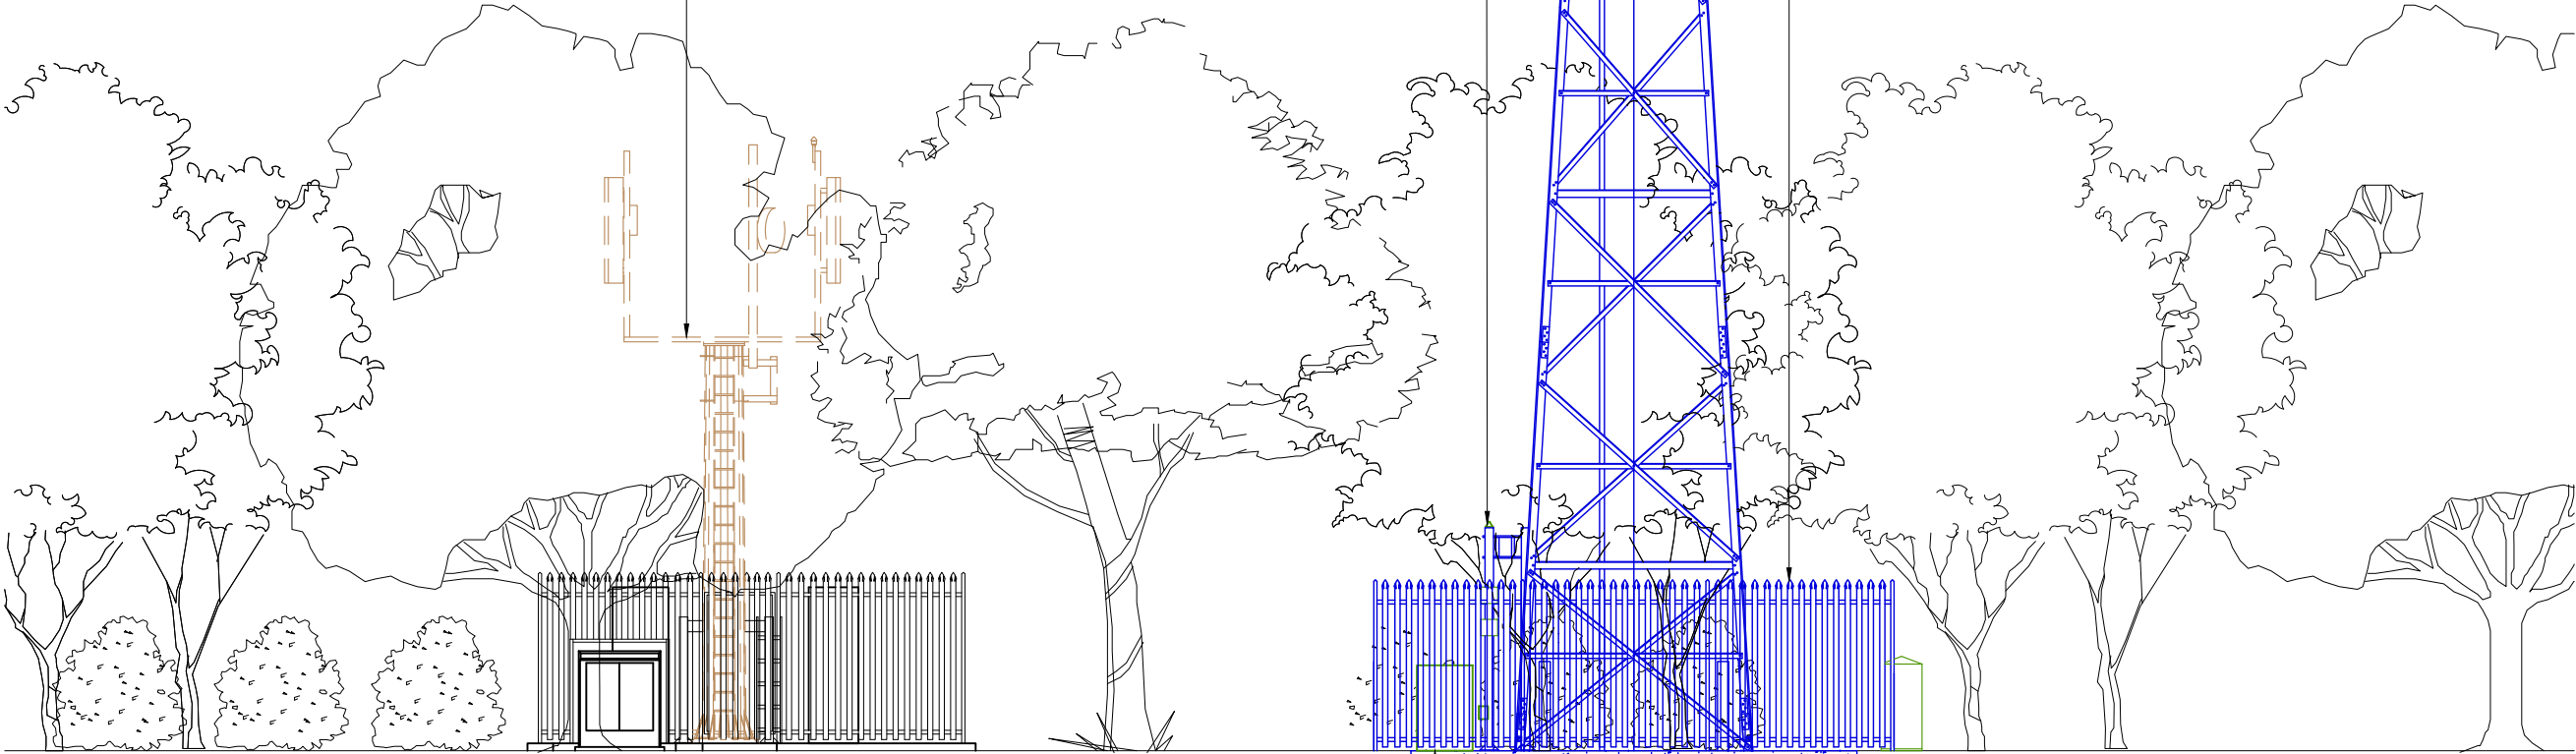

SOUTH WEST ELEVATION

FEINT DETAILS INDICATE LOCATIONS RESERVED FOR OTHER PROPOSALS WHICH MAY BE THE SUBJECT OF SEPARATE APPLICATIONS

NOTES

PROJECT No. NCO-0009313

CELL No. NPT088

3.A				
3	COM-0015375 AS BUILT	12/08/24	GBC	TS
2	235521 PLANNING	09/02/22	WHP	WHP
1	220125 MASTER CREATION	29/09/20	MCD	MF
ISS	REVISION	DATE	DRN	APP

cellnex
driving telecom connectivity

CELLNEX UK
R+, 4TH FLOOR, 2 BLAGRAVE STREET, READING, RG1 1AZ
Tel. 020 4526 8553

SITE No 303634
BAGLAN MOUNTAIN ROAD
MOUNTAIN ROAD
BAGLAN
PENTYLA BAGLAN
NEATH PORT TALBOT
SA12 8HP

NGR SS 76378 90545

OS GRID 276378 190545

TITLE
ELEVATION
PROPOSED
H3G & EE LTD

SCALE 1:100

DRAWN MCD 25/09/20

APPROVED TS 12/08/24

DRG No. Sheet 1 of 1 Rev
303634-07-150-MD003 3.A