


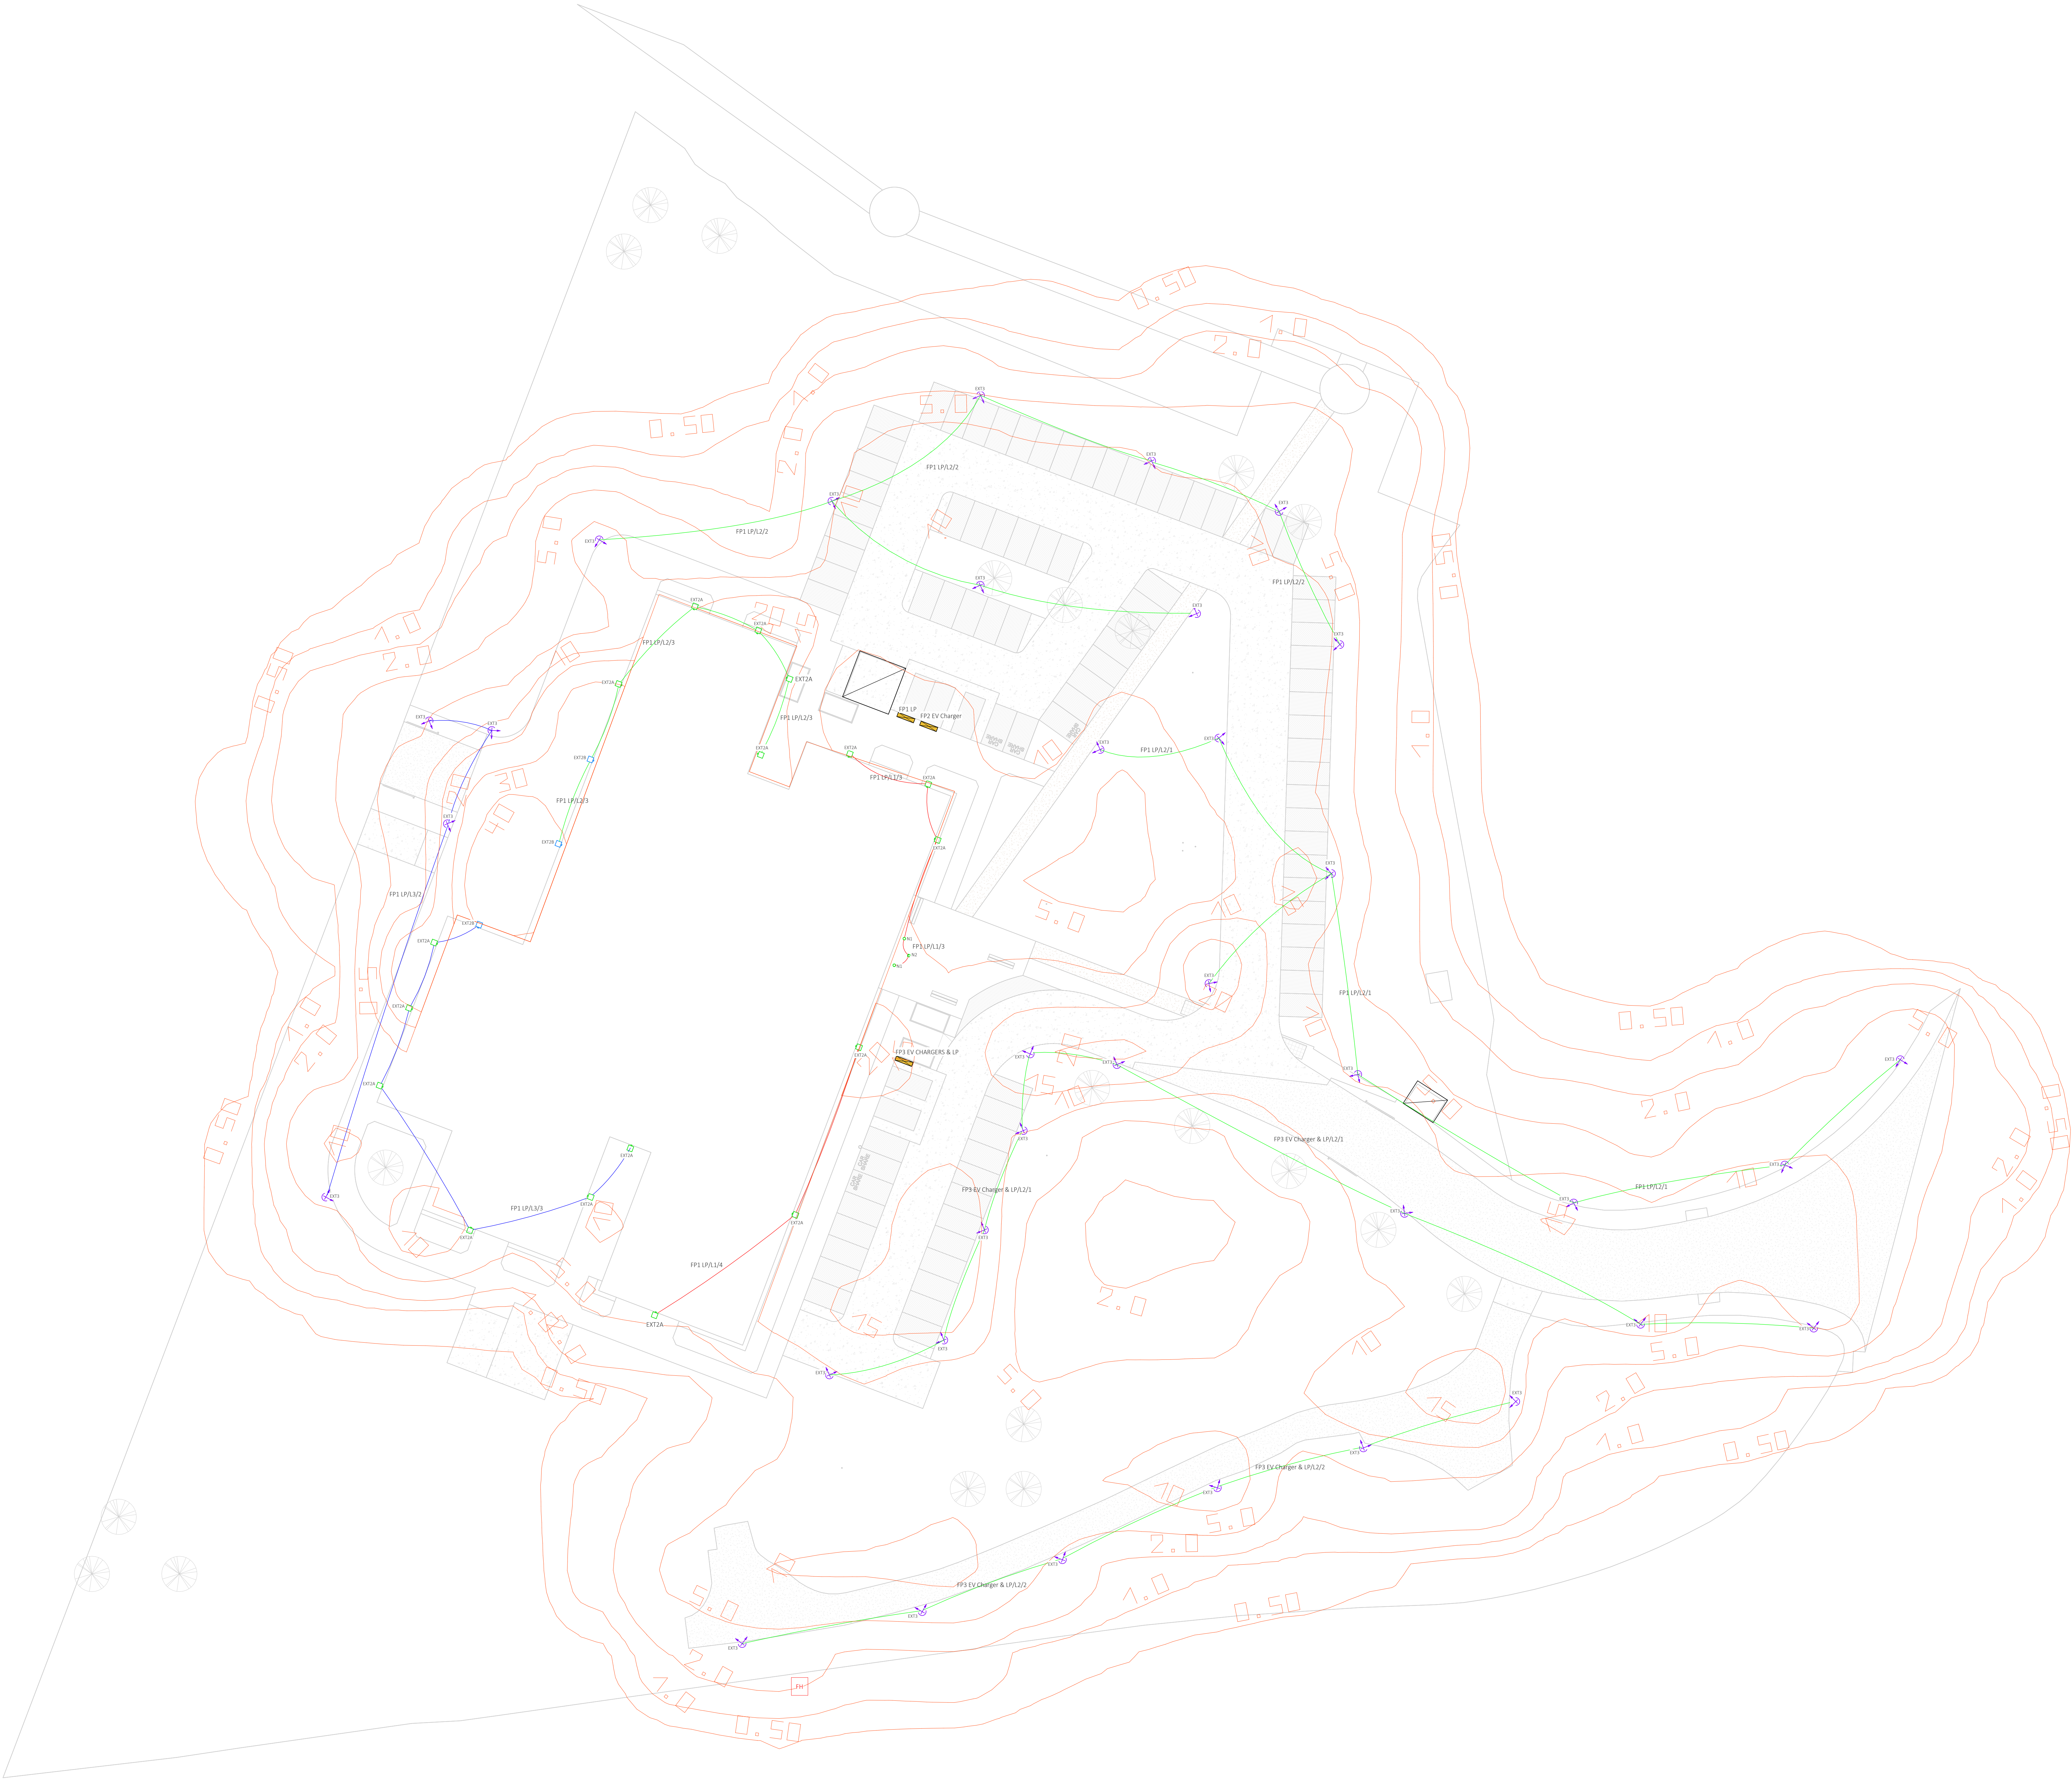

- NOTES
- All dimensions are to be checked on site before the commencement of works. Any discrepancies are to be reported to the Architect & Engineer for verification. Figure dimensions only are to be taken from this drawing.
 - This drawing is to be read in conjunction with all relevant engineers' and service engineers' drawings and specifications. This drawing is copyright.
 - Lighting levels to comply with BS EN 12464-2:2015, including all up to date amendments.
 - Contractor shall install luminaires as per the manufacturers recommendations for ingress protection and protection against mechanical impact.
 - Contractor to refer to Architects and landscape architects.
 - Cabling shall be via suitable XLPE/SWA/LSF suitable for external buried installation.
 - Co-ordination of services shall be by the contractor. Services shall be installed so that they do not clash with other services and shall be located so that they can be easily maintained.
 - Contractor to allow for ducting to external fittings.
- Note: For details of the types of Luminaires refer to the Luminaire Schedule.

- Legend
- Floodlight - EXT3
 - Square Wall Luminaire - EXT2A Low Power
 - Square Wall Luminaire - EXT2B High Power
 - Electrical Feeder Pillar

REVISIONS

P03	Stage 4 - Tender Issue	15/11/2024	M. J. Lewis	D. Finley A. Haines
P02	Stage 4 - Tender Issue	08/10/2024	M. J. Lewis	D. Finley A. Haines
P01	Stage 4 - Issue - For Comment	21/06/2024	M. J. Lewis	D. Finley A. Haines
Rev	Revision Description	Date	Drawn By	Checked Approved By

Hydrock

3rd Floor, Wharton Place
13 Wharton St
Cardiff
CF10 1GS
t: +44(0)2920 023665
e: cardiff@hydrock.com

CLIENT

Morgan Sindall

MORGAN SINDALL

PROJECT

SWITCH Harbourside

TITLE

Electrical Services
External Lighting Isolines Layout

HYDROCK PROJECT NO. C-26279	SCALE @ A0 1 : 250	STATUS D2
STATUS DESCRIPTION SUITABLE FOR TENDER	REVISION P03	
DRAWING NO. 26CB02-HYD-55-XX-D-E-550002		