 



44 Dynevor Avenue - Site Plan

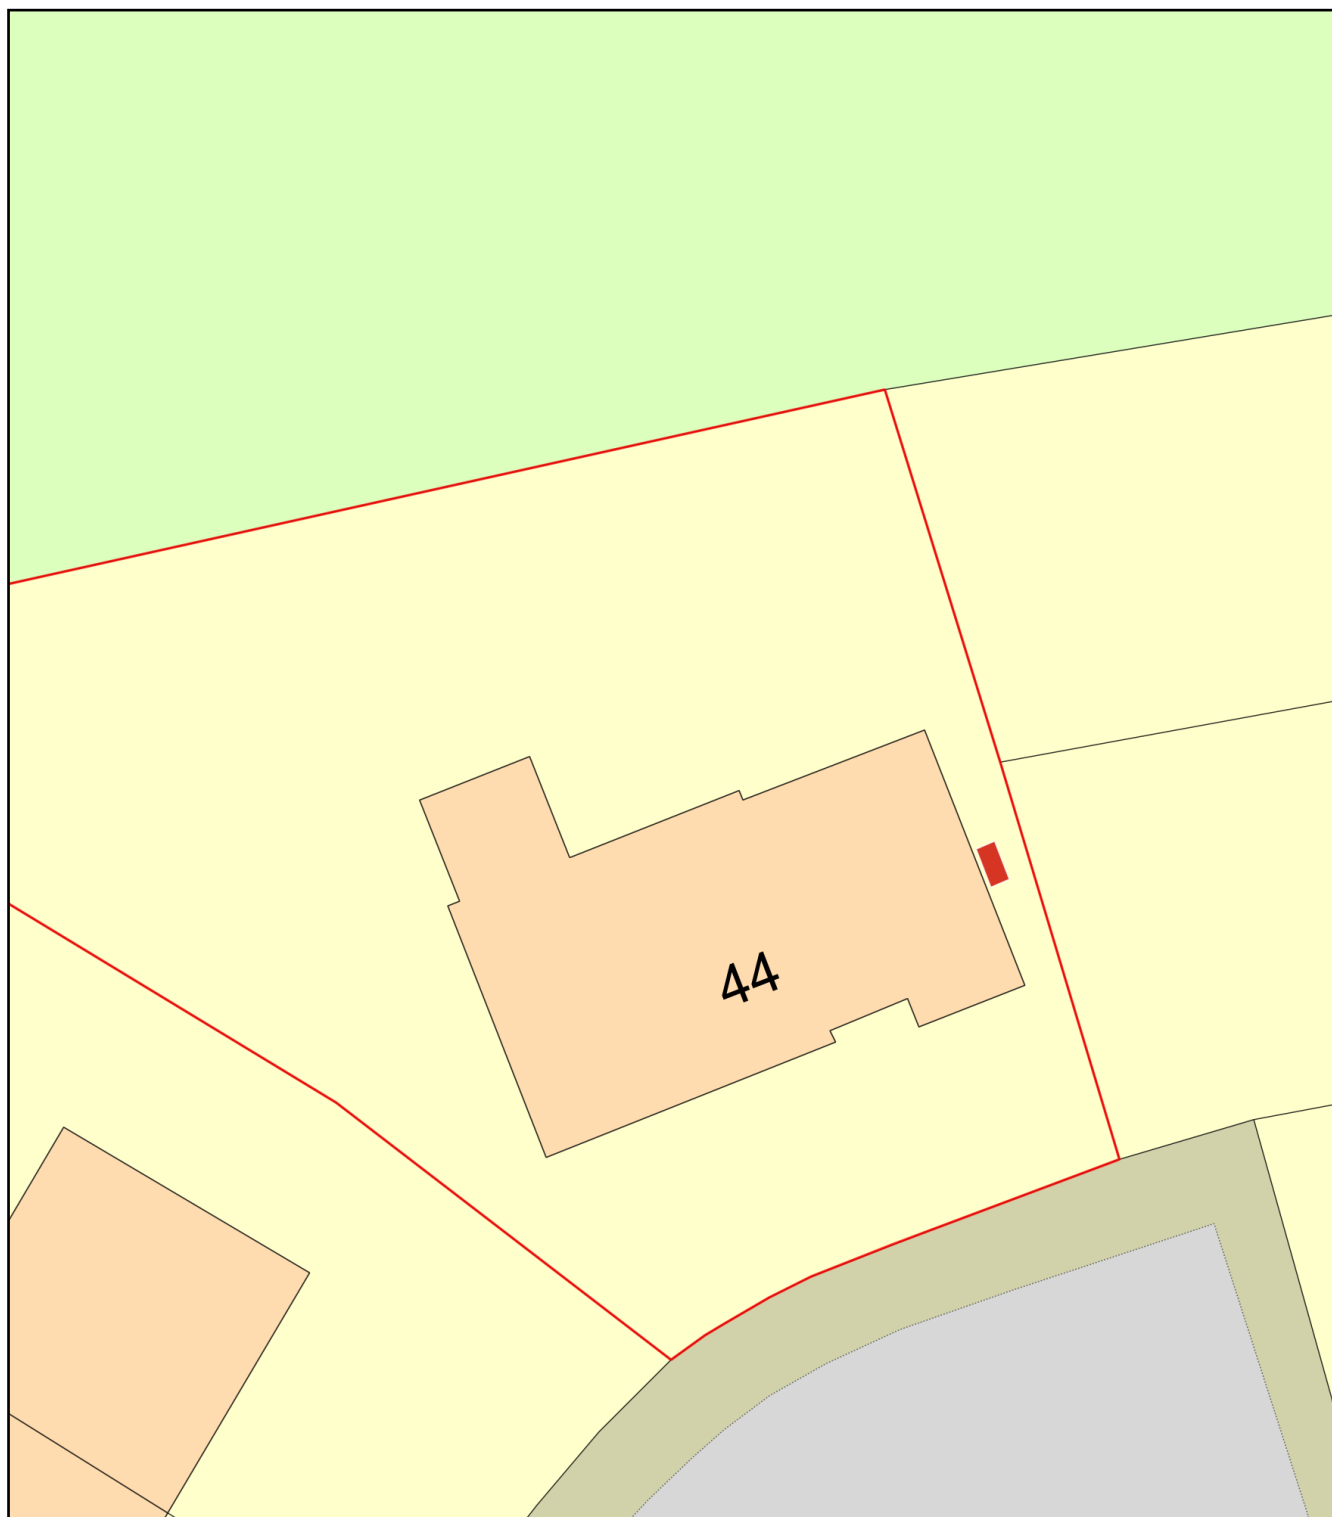

Plan Produced for: City Energy Network LTD

Date Produced: 12 Jun 2025

Plan Reference Number: TQRQM25163172744500

Scale: 1:200 @ A4