


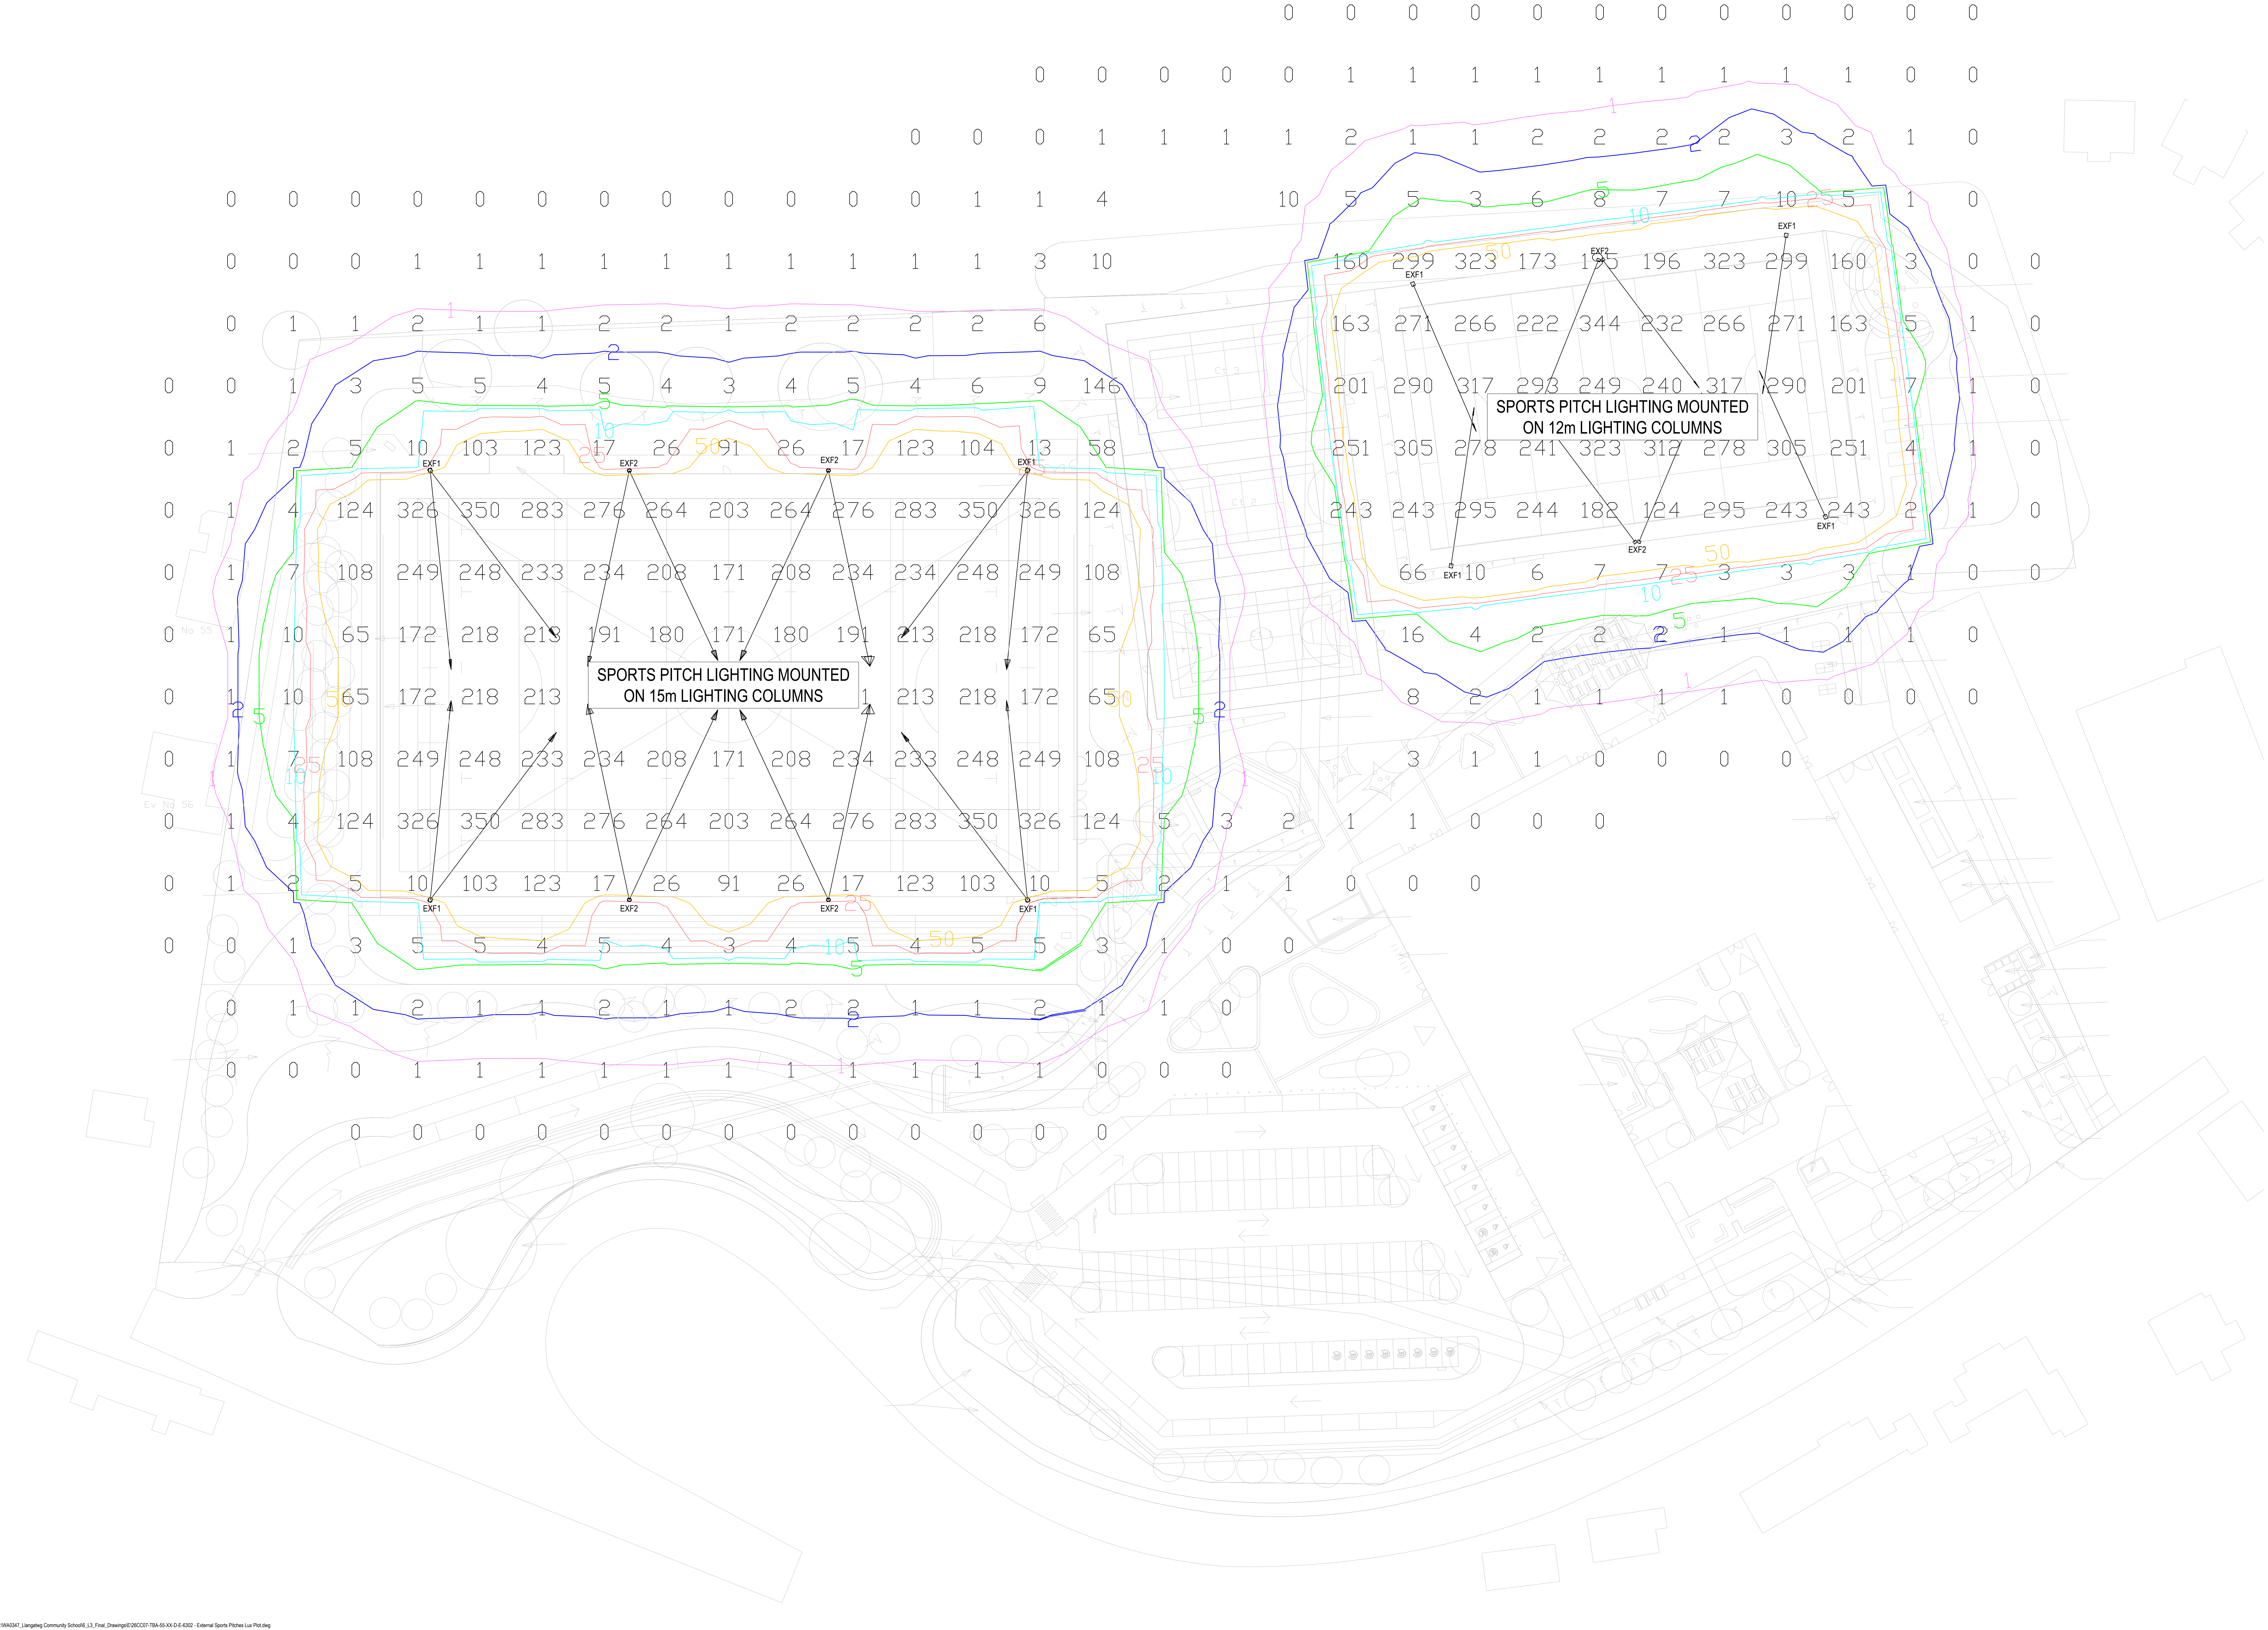

NOTES-LEGEND

- 1. DO NOT SCALE FROM THIS DRAWING
- 2. THIS DRAWING IS INTENDED AS DESIGN INTENT ONLY.
- 3. DRAWING TO BE READ IN CONJUNCTION WITH THE FOLLOWING DRAWINGS:
 - 26CC07-TBA-54-00-D-E-6310 - GROUND FLOOR LIGHTING LAYOUT SHEET 1 OF 4
 - 26CC07-TBA-54-00-D-E-6311 - GROUND FLOOR LIGHTING LAYOUT SHEET 2 OF 4
 - 26CC07-TBA-54-00-D-E-6312 - GROUND FLOOR LIGHTING LAYOUT SHEET 3 OF 4
 - 26CC07-TBA-54-00-D-E-6313 - GROUND FLOOR LIGHTING LAYOUT SHEET 4 OF 4
 - 26CC07-TBA-51-XX-D-E-6001 - EXTERNAL ELECTRICAL SERVICES LAYOUT
- 4. REFERENCE SHOULD BE MADE TO THE ASSOCIATED SCHEDULE OF LUMINAIRES.

TWIN LED 3000K FLOOD LIGHT, (FOLDING TYPE WITH WINCH OPERATION), COMPLETE WITH FUSE CUT OUT - REFER TO SCHEDULE OF LUMINAIRES

TWIN LED 3000K FLOOD LIGHT, (FOLDING TYPE WITH WINCH OPERATION), COMPLETE WITH FUSE CUT OUT - REFER TO SCHEDULE OF LUMINAIRES

P01	STAGE 3 ISSUE			JP	KS	29.05.2025
Rev	Doc	Description	Dwn	Chkd	Date	

STAGE 3

TROUP BYWATERS
+ ANDERS
Bringing Buildings to Life

3 Park Place
Cardiff CF10 3DP
t: +44 (0)2920 003760
e: cardiff@anders.com
w: www.anders.com

Project
LANGATWG COMMUNITY HIGH SCHOOL

Title
ELECTRICAL SERVICES
EXTERNAL SPORTS PITCHES LUX PLOT

Client
NEATH PORT TALBOT COUNCIL

Architect
AUSTIN-SMITHLORD

Project No.	Drawn By	Date	Checked	Scale
WA0347	RN	29.05.2025	KS	NTS

Acad Model	Revision
Drawing No. 26CC07-TBA-55-XX-D-E-6302	P01