


This drawing and design are the property of Ashcroft Electrical Services Ltd.
and should not be reproduced without the consent in writing of Ashcroft
Electrical Services Ltd


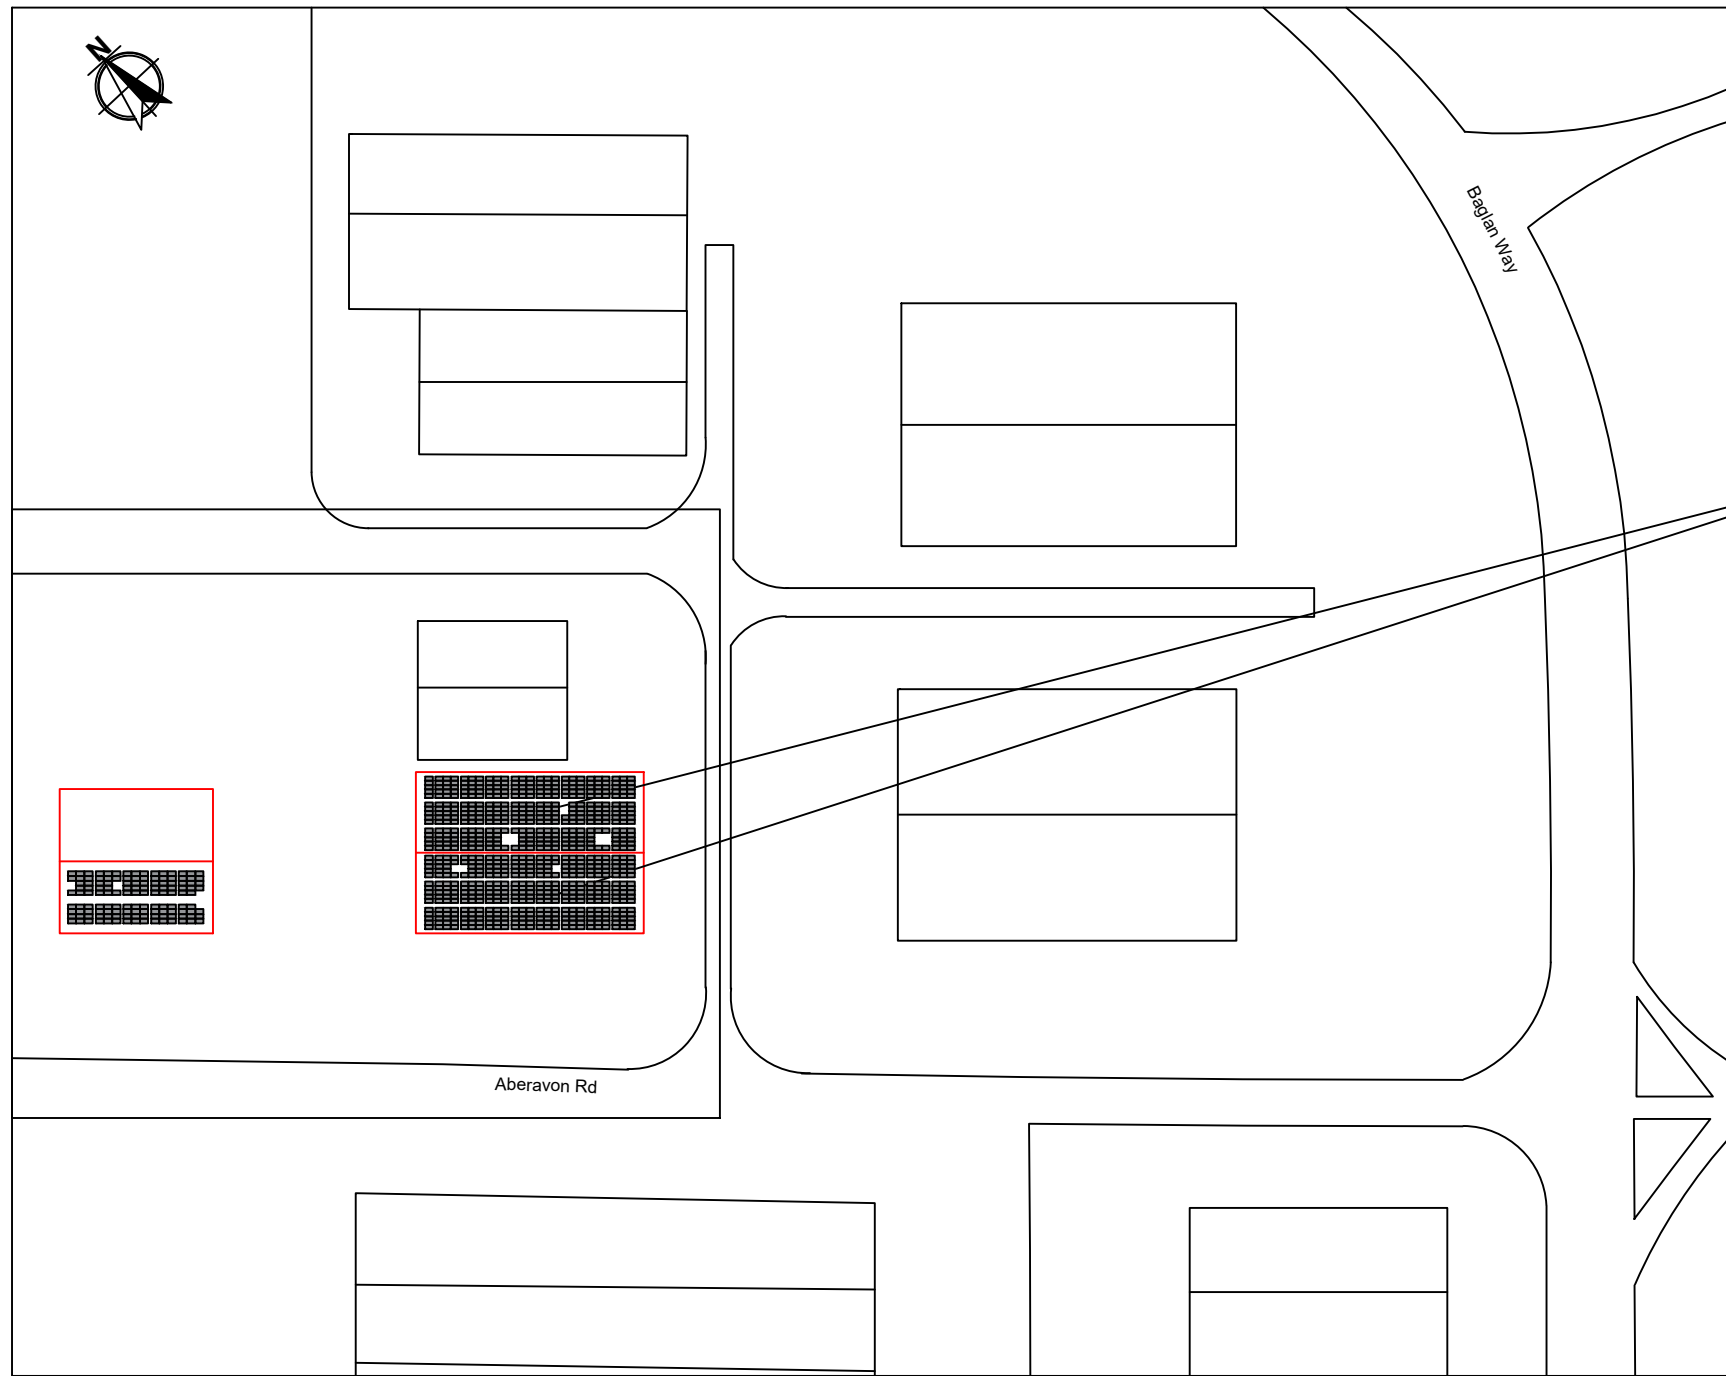


SITE LOCATION PLAN 1:1250


Scale 1:1250



0 25m 50m 75m 100m 125m 150m

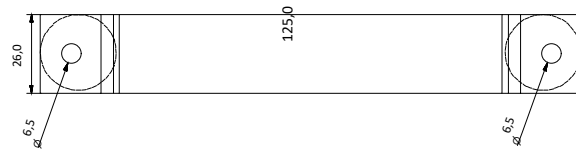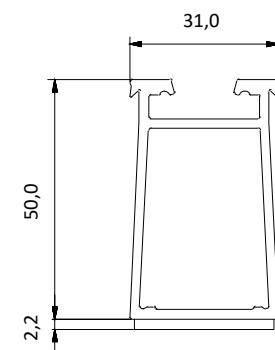

S:FLEX SOLAR MOUNTING
SYSTEM OR OTHER SIMILAR
APPROVED - SEE DATA
SHEET FOR SPECIFICATION

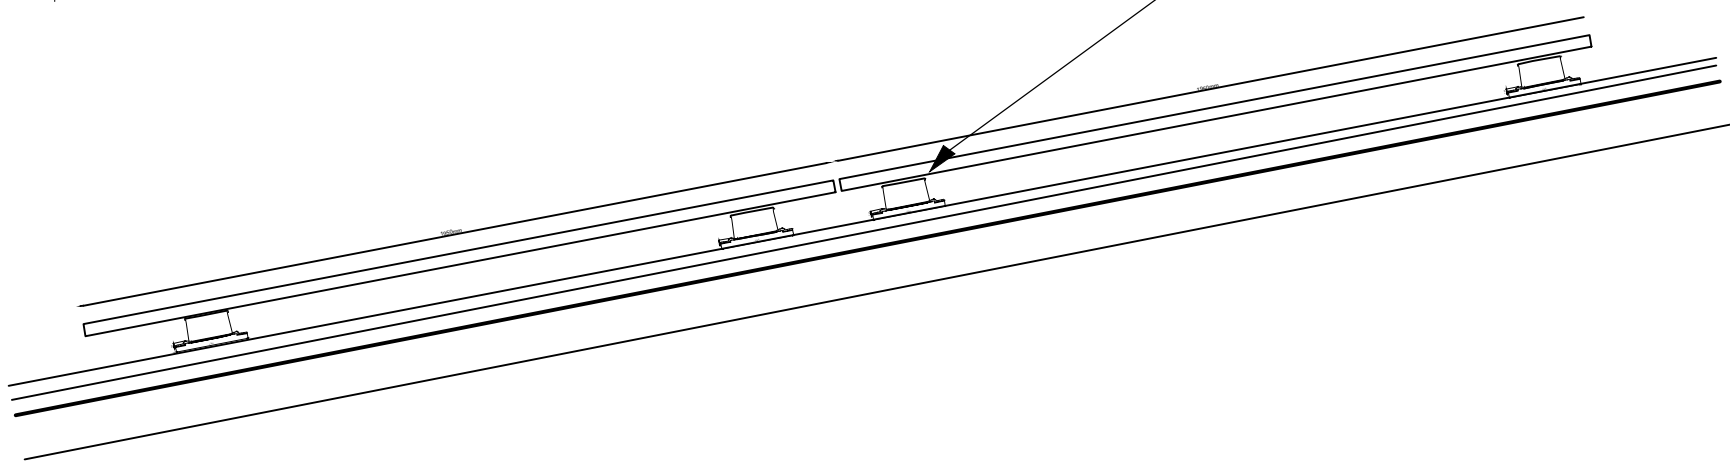


PROPOSED PANEL FIXING DETAIL - PITCHED ROOF 1:10

Scale 1:10



0 200mm 400mm 600mm 800mm 1000mm 1200mm

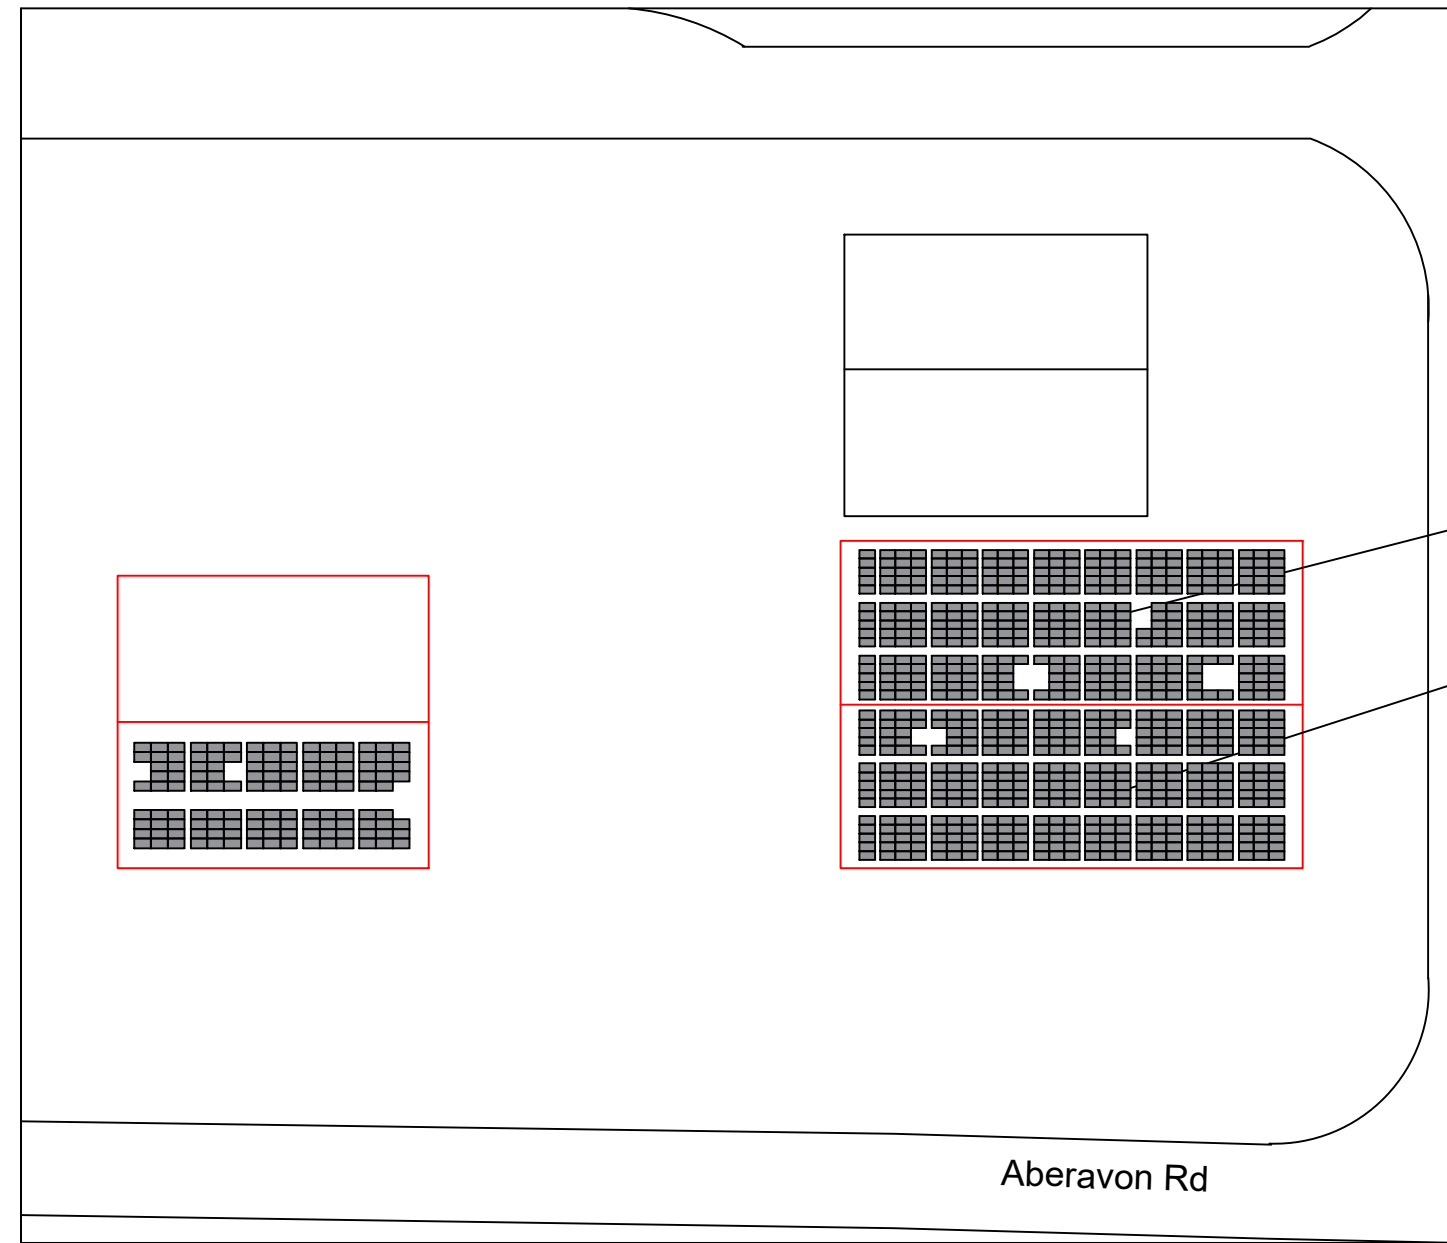

SITE LOCATION PLAN 1:500

Scale 1:500




0 25m 50m 75m 100m 125m 150m

[illegible]

Ashcroft Electrical Services 72A New Court Way
Ormskirk
L39 2YT

www.ashcroftelectricalco.uk info@ashcroftelectrical.co.uk 01695 566 7520

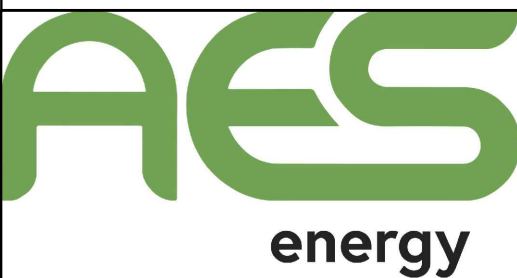

LOCATION
Volac,
12 Aberavon Rd,
Port Talbot
SA12 7DJ

PROJECT	Volac PV Panel Installation
---------	--------------------------------

CLIENT
Ashcroft Electrical Services Ltd.

DRAWING TITLE
SITE LOCATION PLAN, PROPOSED ROOF PLAN & PROPOSED DETAILS

PURPOSE OF ISSUE
PRIOR APPROVAL
PERMITTED DEVELOPMENT

DRAWN BY JB	CHECKED BY KD	DATE FEB 2025
----------------	------------------	------------------

SCALE (@ A1) AS INDICATED	PROJECT NUMBER TBD
------------------------------	-----------------------

DRAWING NUMBER	REV
0001	-