


1. Drawings must not be scaled and any discrepancies must be reported immediately.
2. The drawing is to be read in conjunction with all other relevant project drawings and schedules.
3. Dimensions indicated are structural.
4. Drawing must be printed in colour to ensure all elements are clearly identified.
5. Drawings are based on measured survey. All dimensions to be checked on site prior to work commencing.
6. Plans are subject to imposed planning and building control conditions and thorough drainage investigations. Position of all existing in use and redundant drainage runs to be confirmed following further investigation.
7. Position of any existing underground services to be confirmed following further investigation.
8. Tender to include for all builders works associated with MSE installations, including formwork of all holes, chases, notches etc and subsequent making good; removal of ceiling tiles / casings / boxings / ducting to facilitate subsequent making good.
9. Tender to include for all fire-stopping works to be undertaken by a certified Sub-Contractor and evidence provided to Contract Administrator.
10. Exact position of all existing services/M+E as well as in use and redundant drainage runs to be confirmed following further investigation.
11. Ownership of all boundaries to be confirmed by client.




Existing Wall Type Key

- — — — — Solid Wall
— — — — — Stud Wall

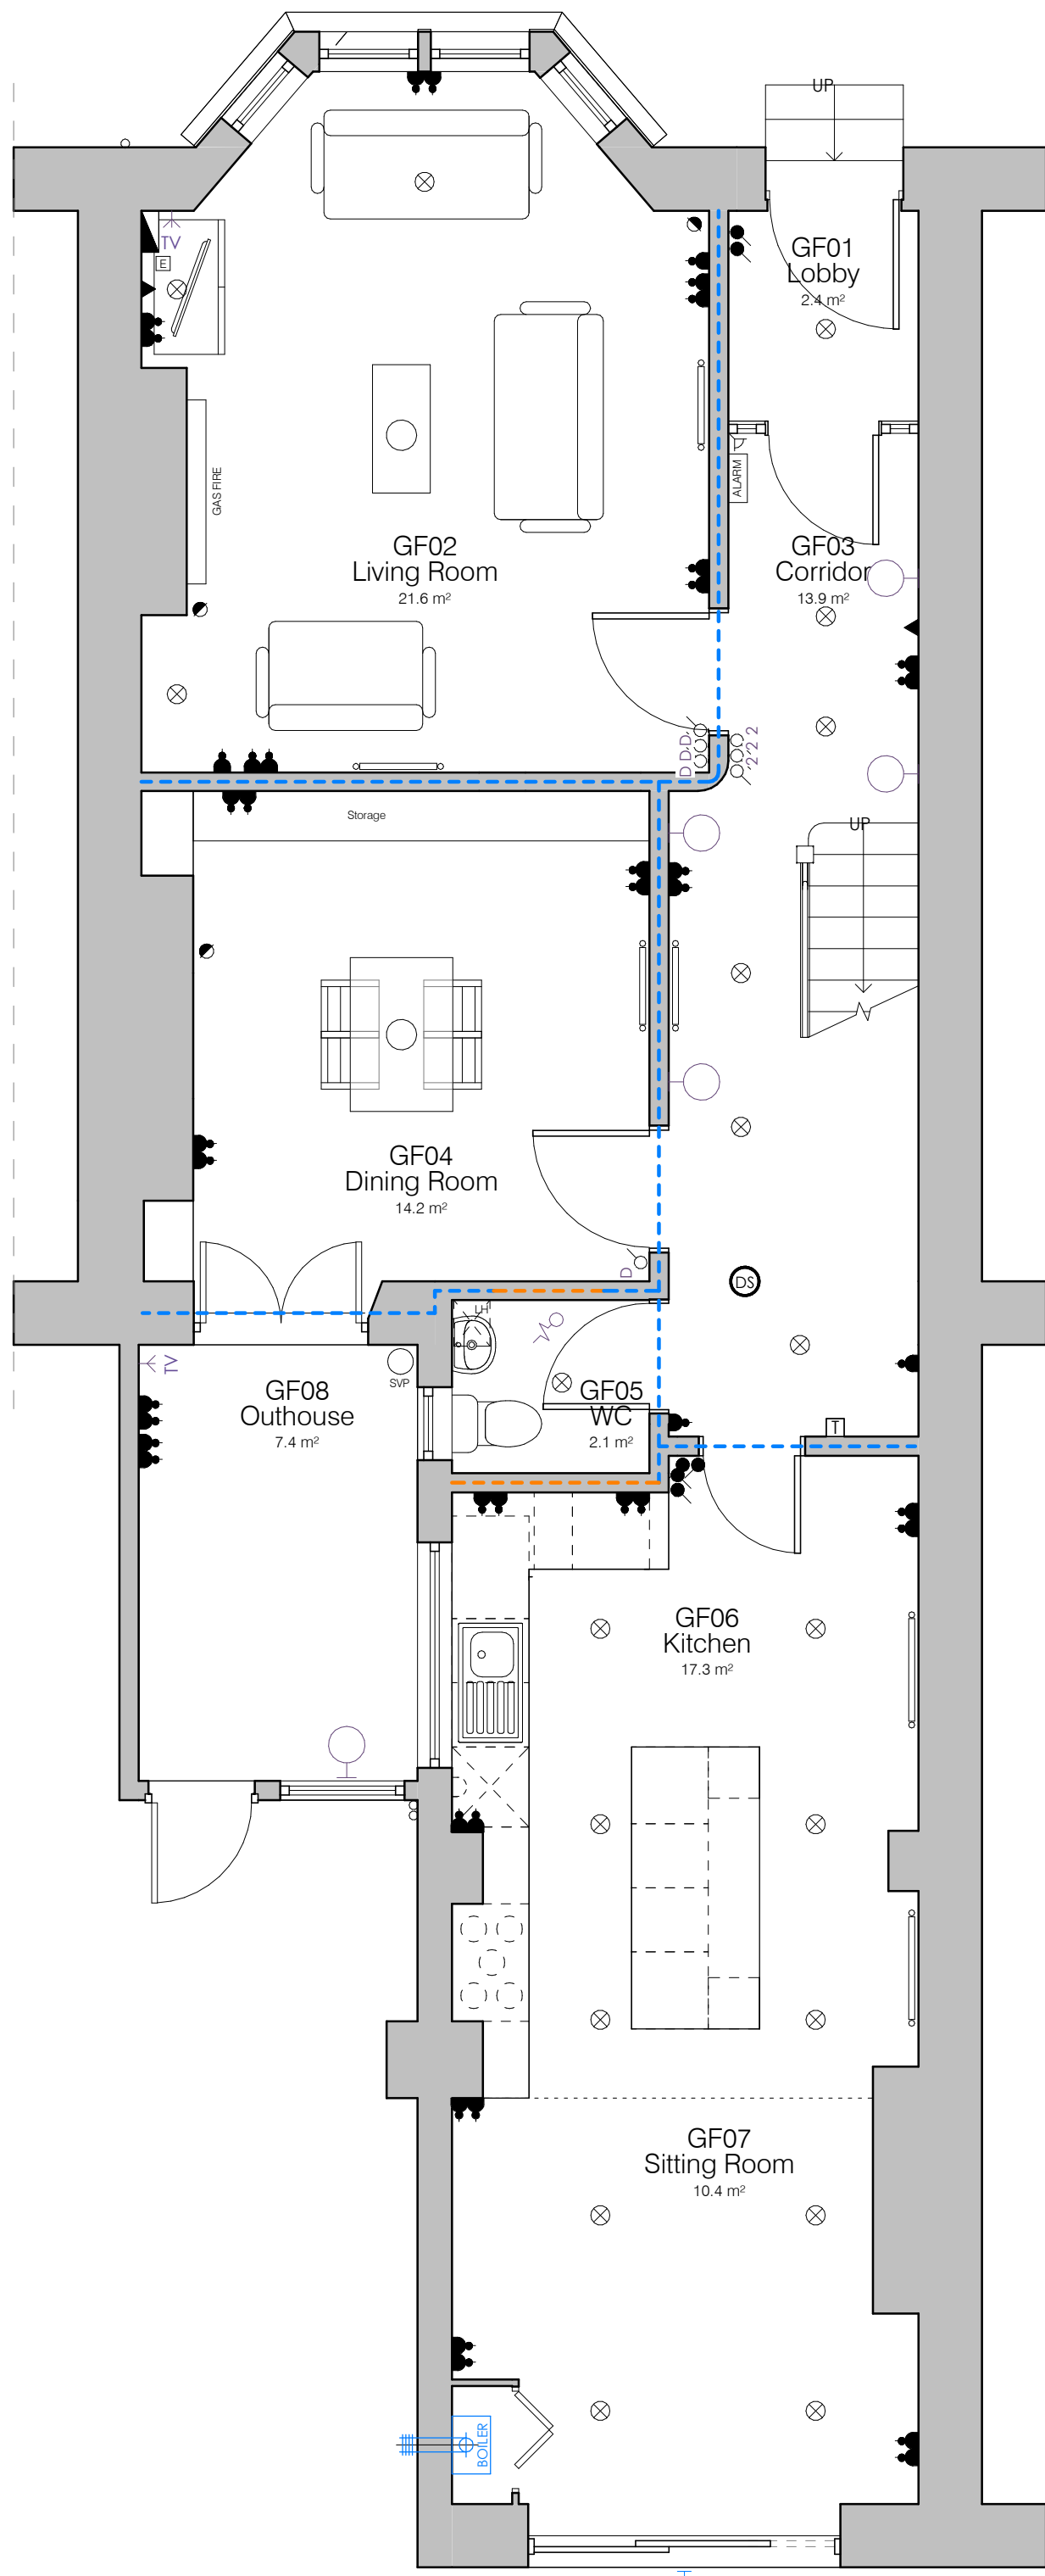


00 Existing Ground Floor Plan

1 : 50

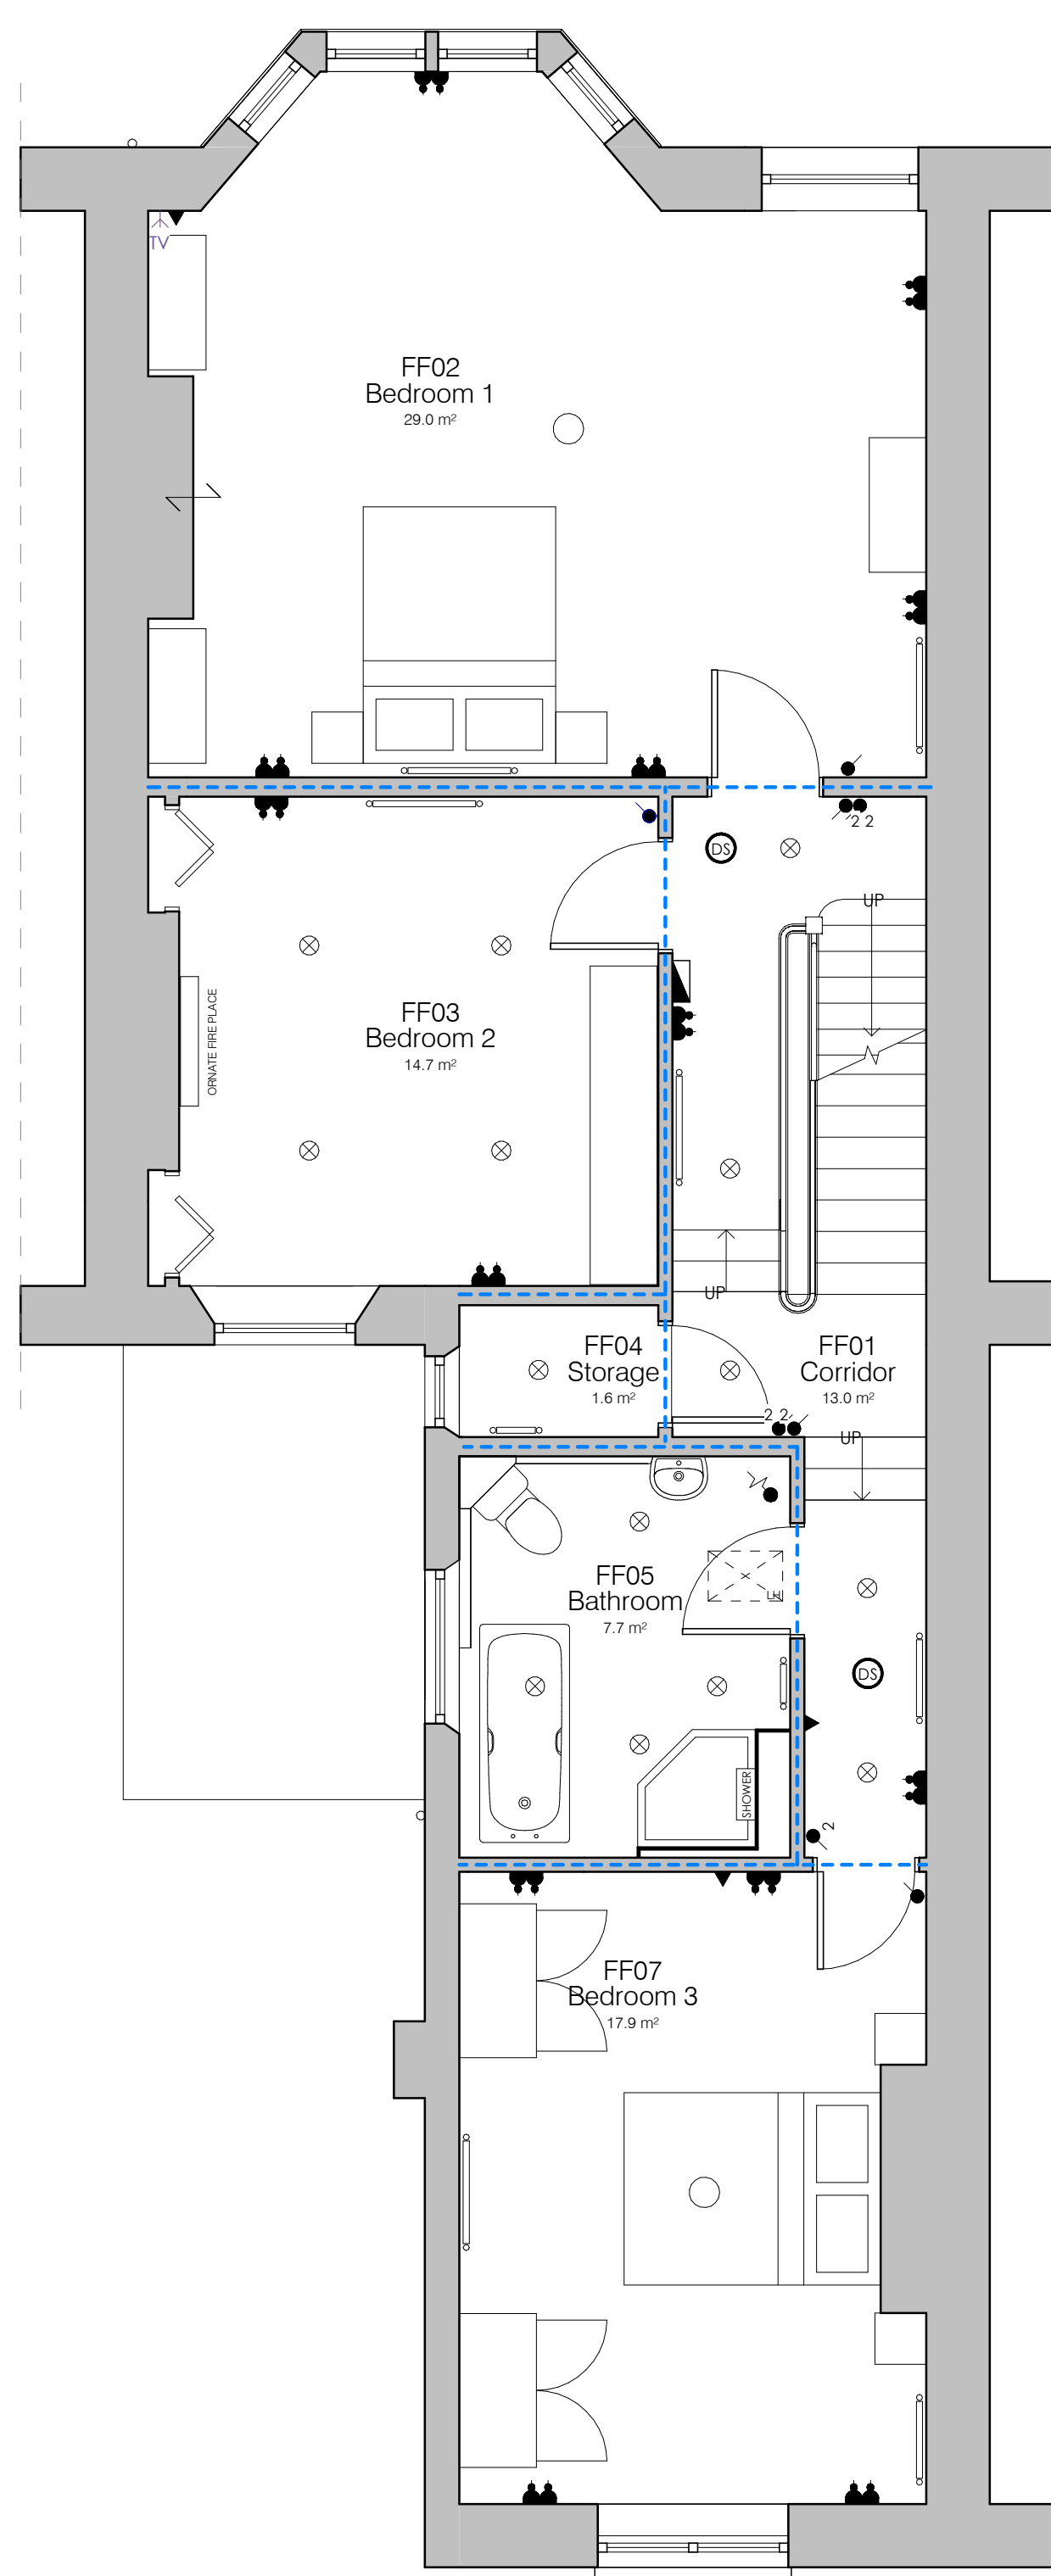

01 Existing First Floor Plan

1:50

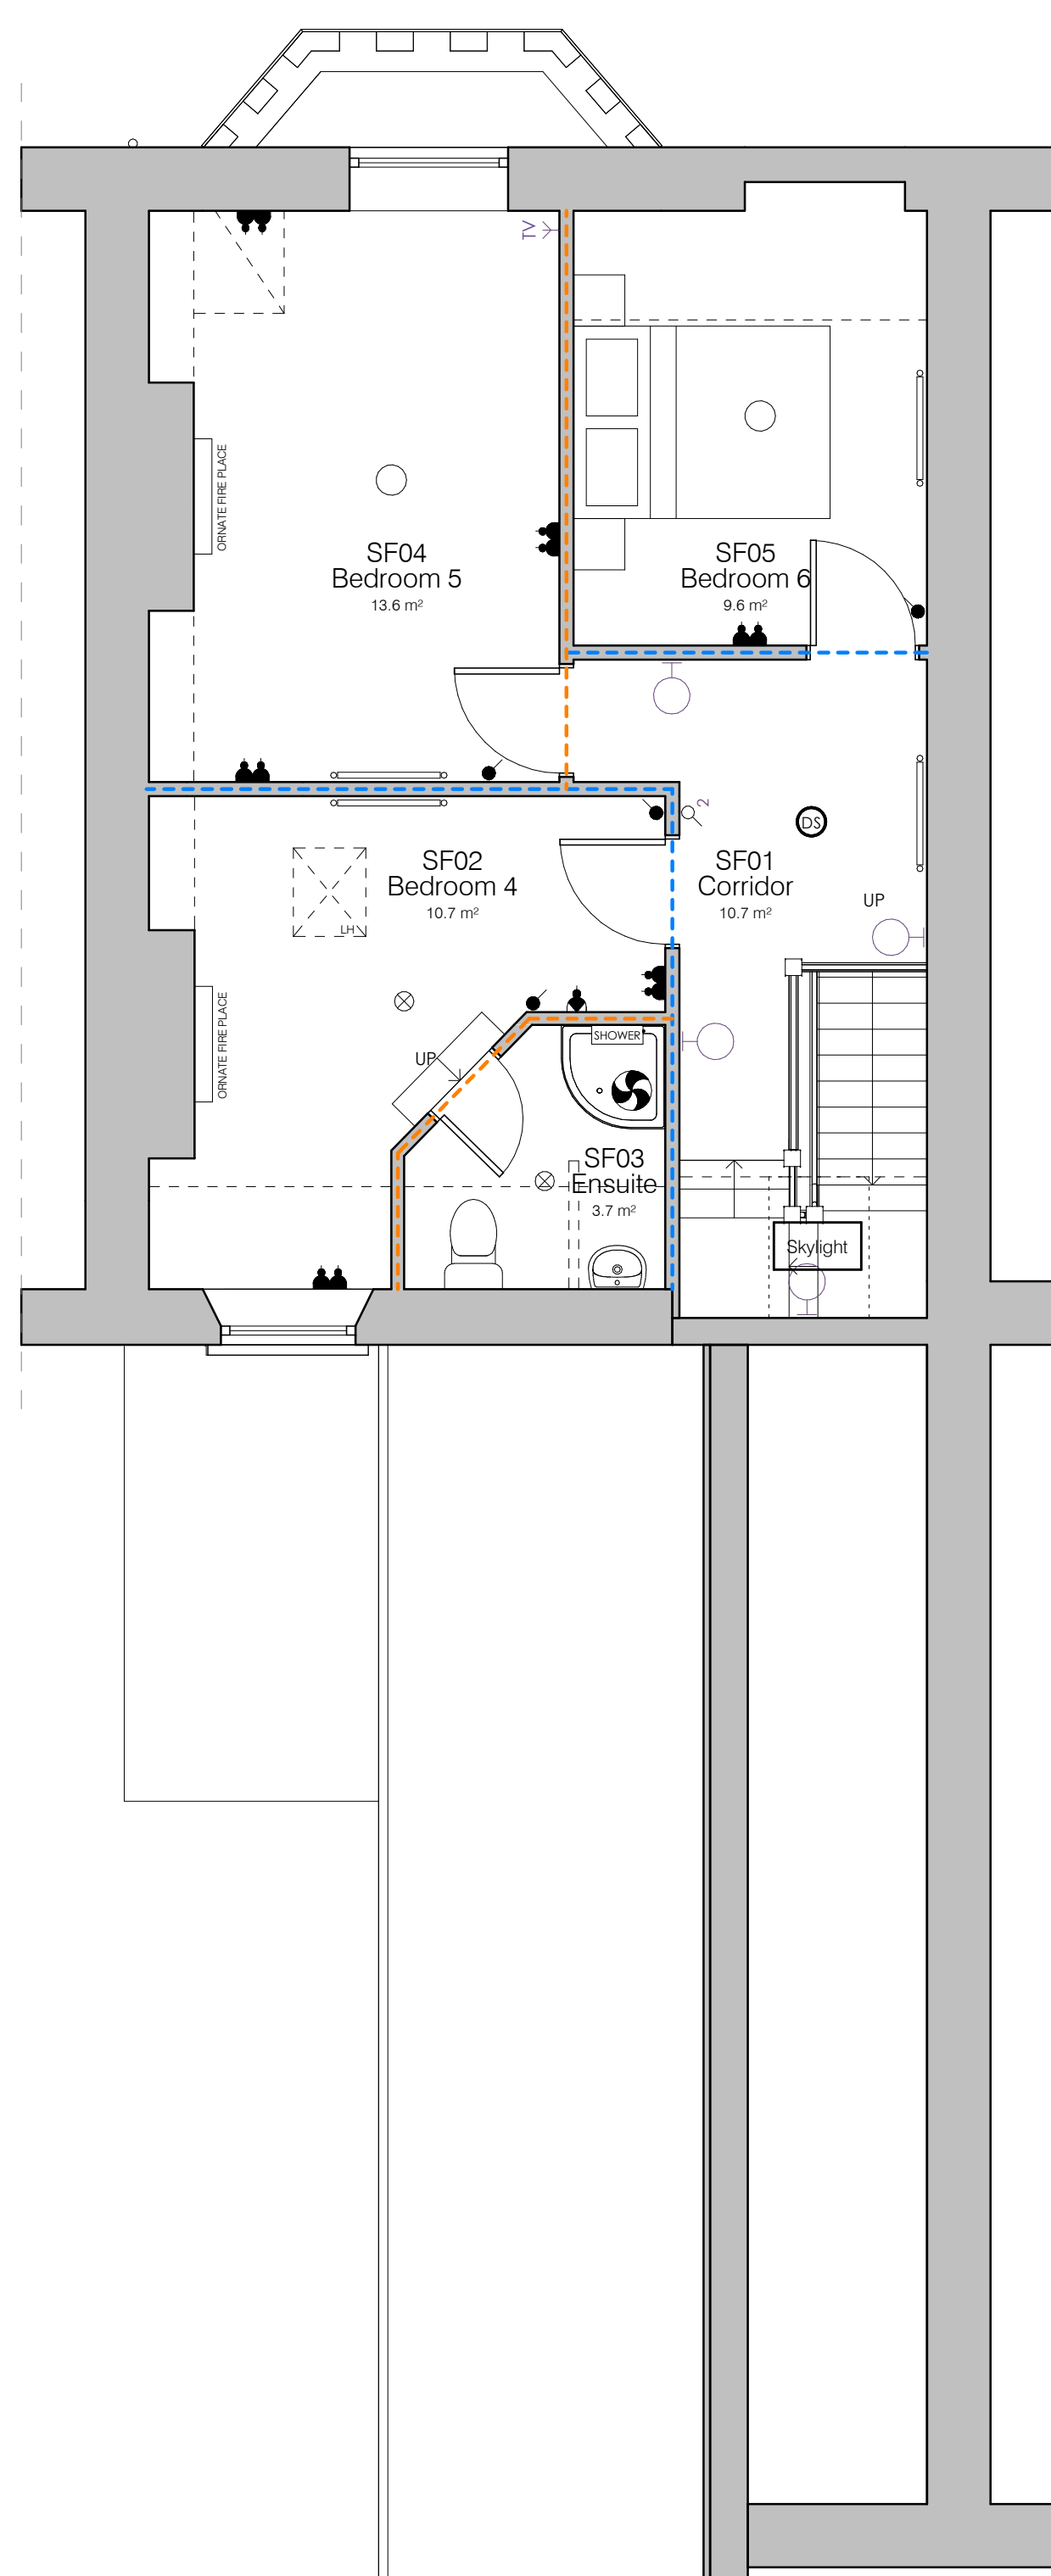

02 Existing Second Floor Plan

1 : 50

Existing Mechanical & Electrical Key

- | | | | | | | | | |
|---|--------------------------------|---|----------------------|---|--|---|-----|------------------------|
|  | Light Switch |  | PIR Sensor |  | Television Outlet |  | SVP | Soil Vent Pipe |
|  | Two Way Light Switch |  | Boiler |  | Telephone Outlet Point |  | FG | Floor Gully |
|  | Dimmer Switch |  | Radiator |  | Central Isolator Switchboard with Neon Indicator |  | FS | Floor Socket |
|  | Carbon Monoxide Detector |  | Gas Supply Point |  | Extractor Fan |  | SWS | Sprinkler Water Supply |
|  | Heat Detector |  | Consumer Unit |  | Thermostat |  | WM | Water Main |
|  | Smoke Detector |  | Switched Fused Spur |  | Shaver point with integral light | | | |
|  | Spot Light Fitting |  | Switch Single Socket |  | Shaver point | | | |
|  | Pendant Light Fitting |  | Single USB socket |  | Shower Fitting | | | |
|  | Wall Mounted Security Lighting |  | Switch Double Socket |  | Fibre panel | | | |

P1	Preliminary issue	CH	AH	04.02.25
Rev.	Description	Drawn	Check	Date

pentan
architects

22 Cathedral Road
Cardiff CF11 9LJ
t. 029 2030 9010
info@pentan.co.uk

Project
7 Cimla Road

24

Drawing Title

Existing Floor Plans

Job no.	Org.	Zone	Level	Type	Role	Description	Status	Rev.
4179	- PEN	- ZZ	- ZZ	- DR	- A	- 2000	S1	P1
Scale							Date	
As indicated @ A1							Jan '25	

NOTES: Do not scale. All dimensions are in millimetres unless stated otherwise