
 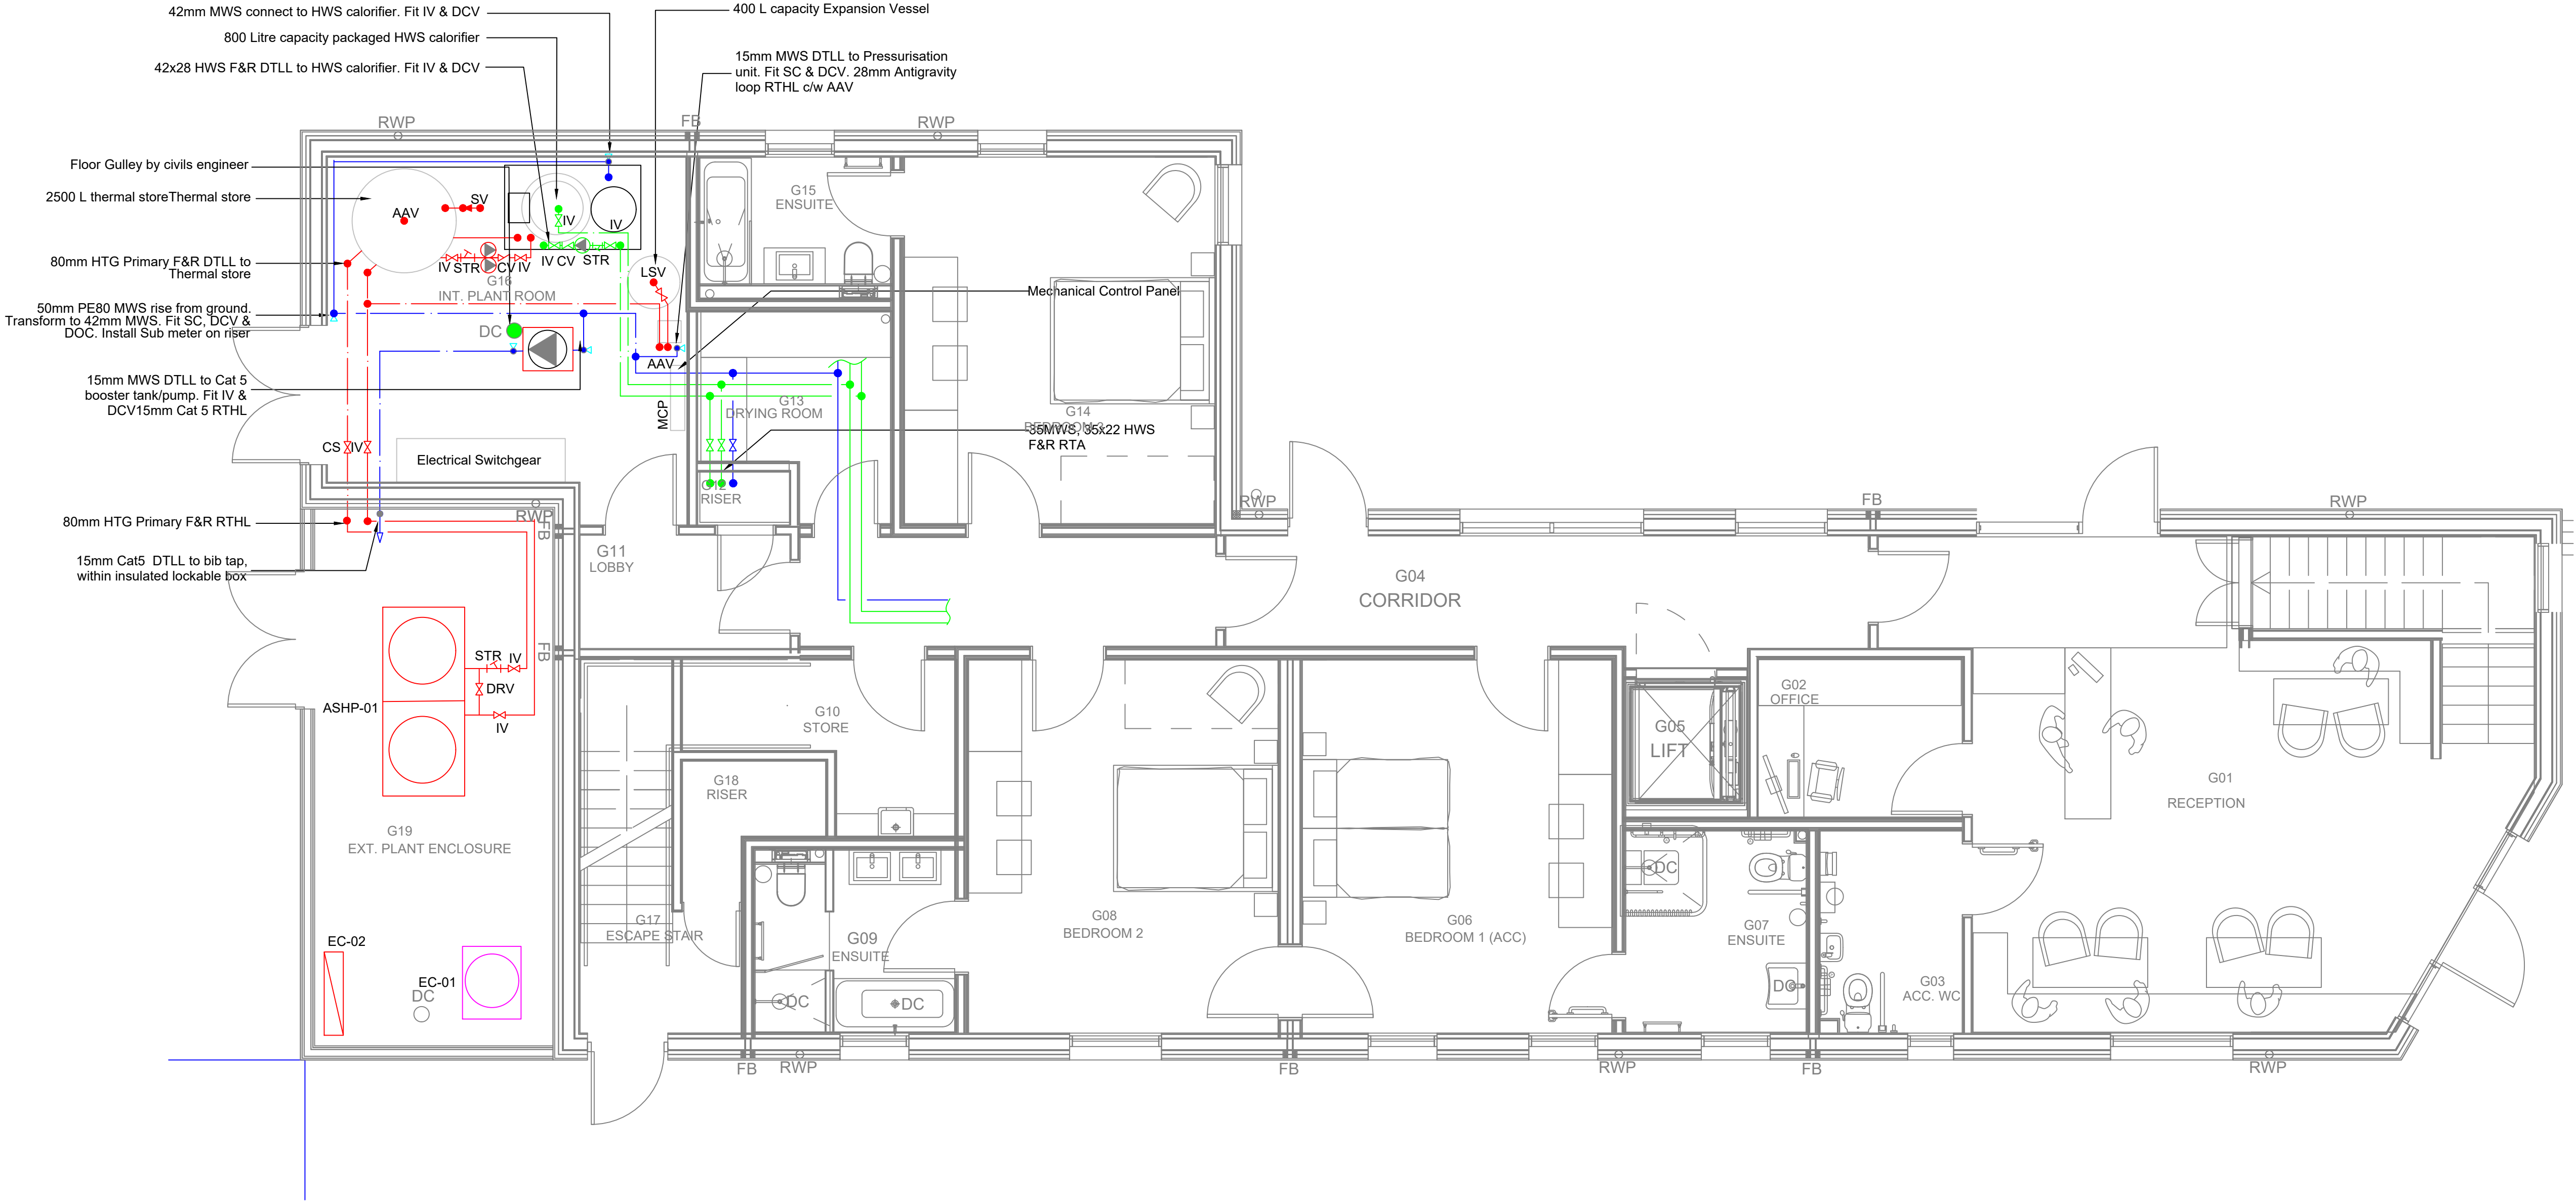




- This is not an installation drawing.
- The final coordination of services, specialist Sub-Contractors, and building structure is the responsibility of the building services Contractor.
- Do not scale from this drawing.
- This drawing shall be read in conjunction with the MEP Specification.
- The installation of services shall be in compliance with the workmanship clauses detailed in the Specification.

Notes

Legend

#### Safety, Health & Environmental Information

In addition to the hazards / risks normally associated with the types of work detailed on this drawing, note the following:

#### Construction

1. None identified at date of issue.

#### Maintenance / Cleaning

1. None identified at date of issue.

#### Decommissioning / Demolition

1. None identified at date of issue.

It is assumed that all works will be carried out by a competent contractor working, where appropriate, to an approved method statement

|                                                     |     |          |     |
|-----------------------------------------------------|-----|----------|-----|
| New Arch Layout: ASHP Details Amended               | PP  | 20.11.25 | C02 |
| Construction Phase Issue                            | PP  | June 25  | C01 |
| Contract Issue                                      | PP  | May 25   | P04 |
| Cat 5 booster added                                 | PP  | 03.12.24 | P03 |
| Primary Pumps omitted from ASHP. Floor Gulley added | PP  | 02.12.24 | P02 |
| Details                                             | Eng | Date     | Rev |

#### Revisions



Job Title  
Lower Pontneddfechan  
Neath Port Talbot CBC

Drawing Title  
Mechanical Engineering Services  
Proposed Mechanical Plantroom Layout  
Accommodation Block  
Ground Floor

| Scale       | A1                 | Date                 | Authorised | Checked | Engineer | Drawn |
|-------------|--------------------|----------------------|------------|---------|----------|-------|
| 1:50        | Sep 24             | GBH                  | DJ         | PP      | RM       |       |
| McConn. Ref | Status             | Status Code Revision |            |         |          |       |
| 9003        | Construction Phase | A1                   | C02        |         |          |       |
| UPRN        | Volume             | Originator           | Role       | Type    | Number   |       |
| 2081        | 01                 | MCP                  | H          | DR      | 8000     |       |