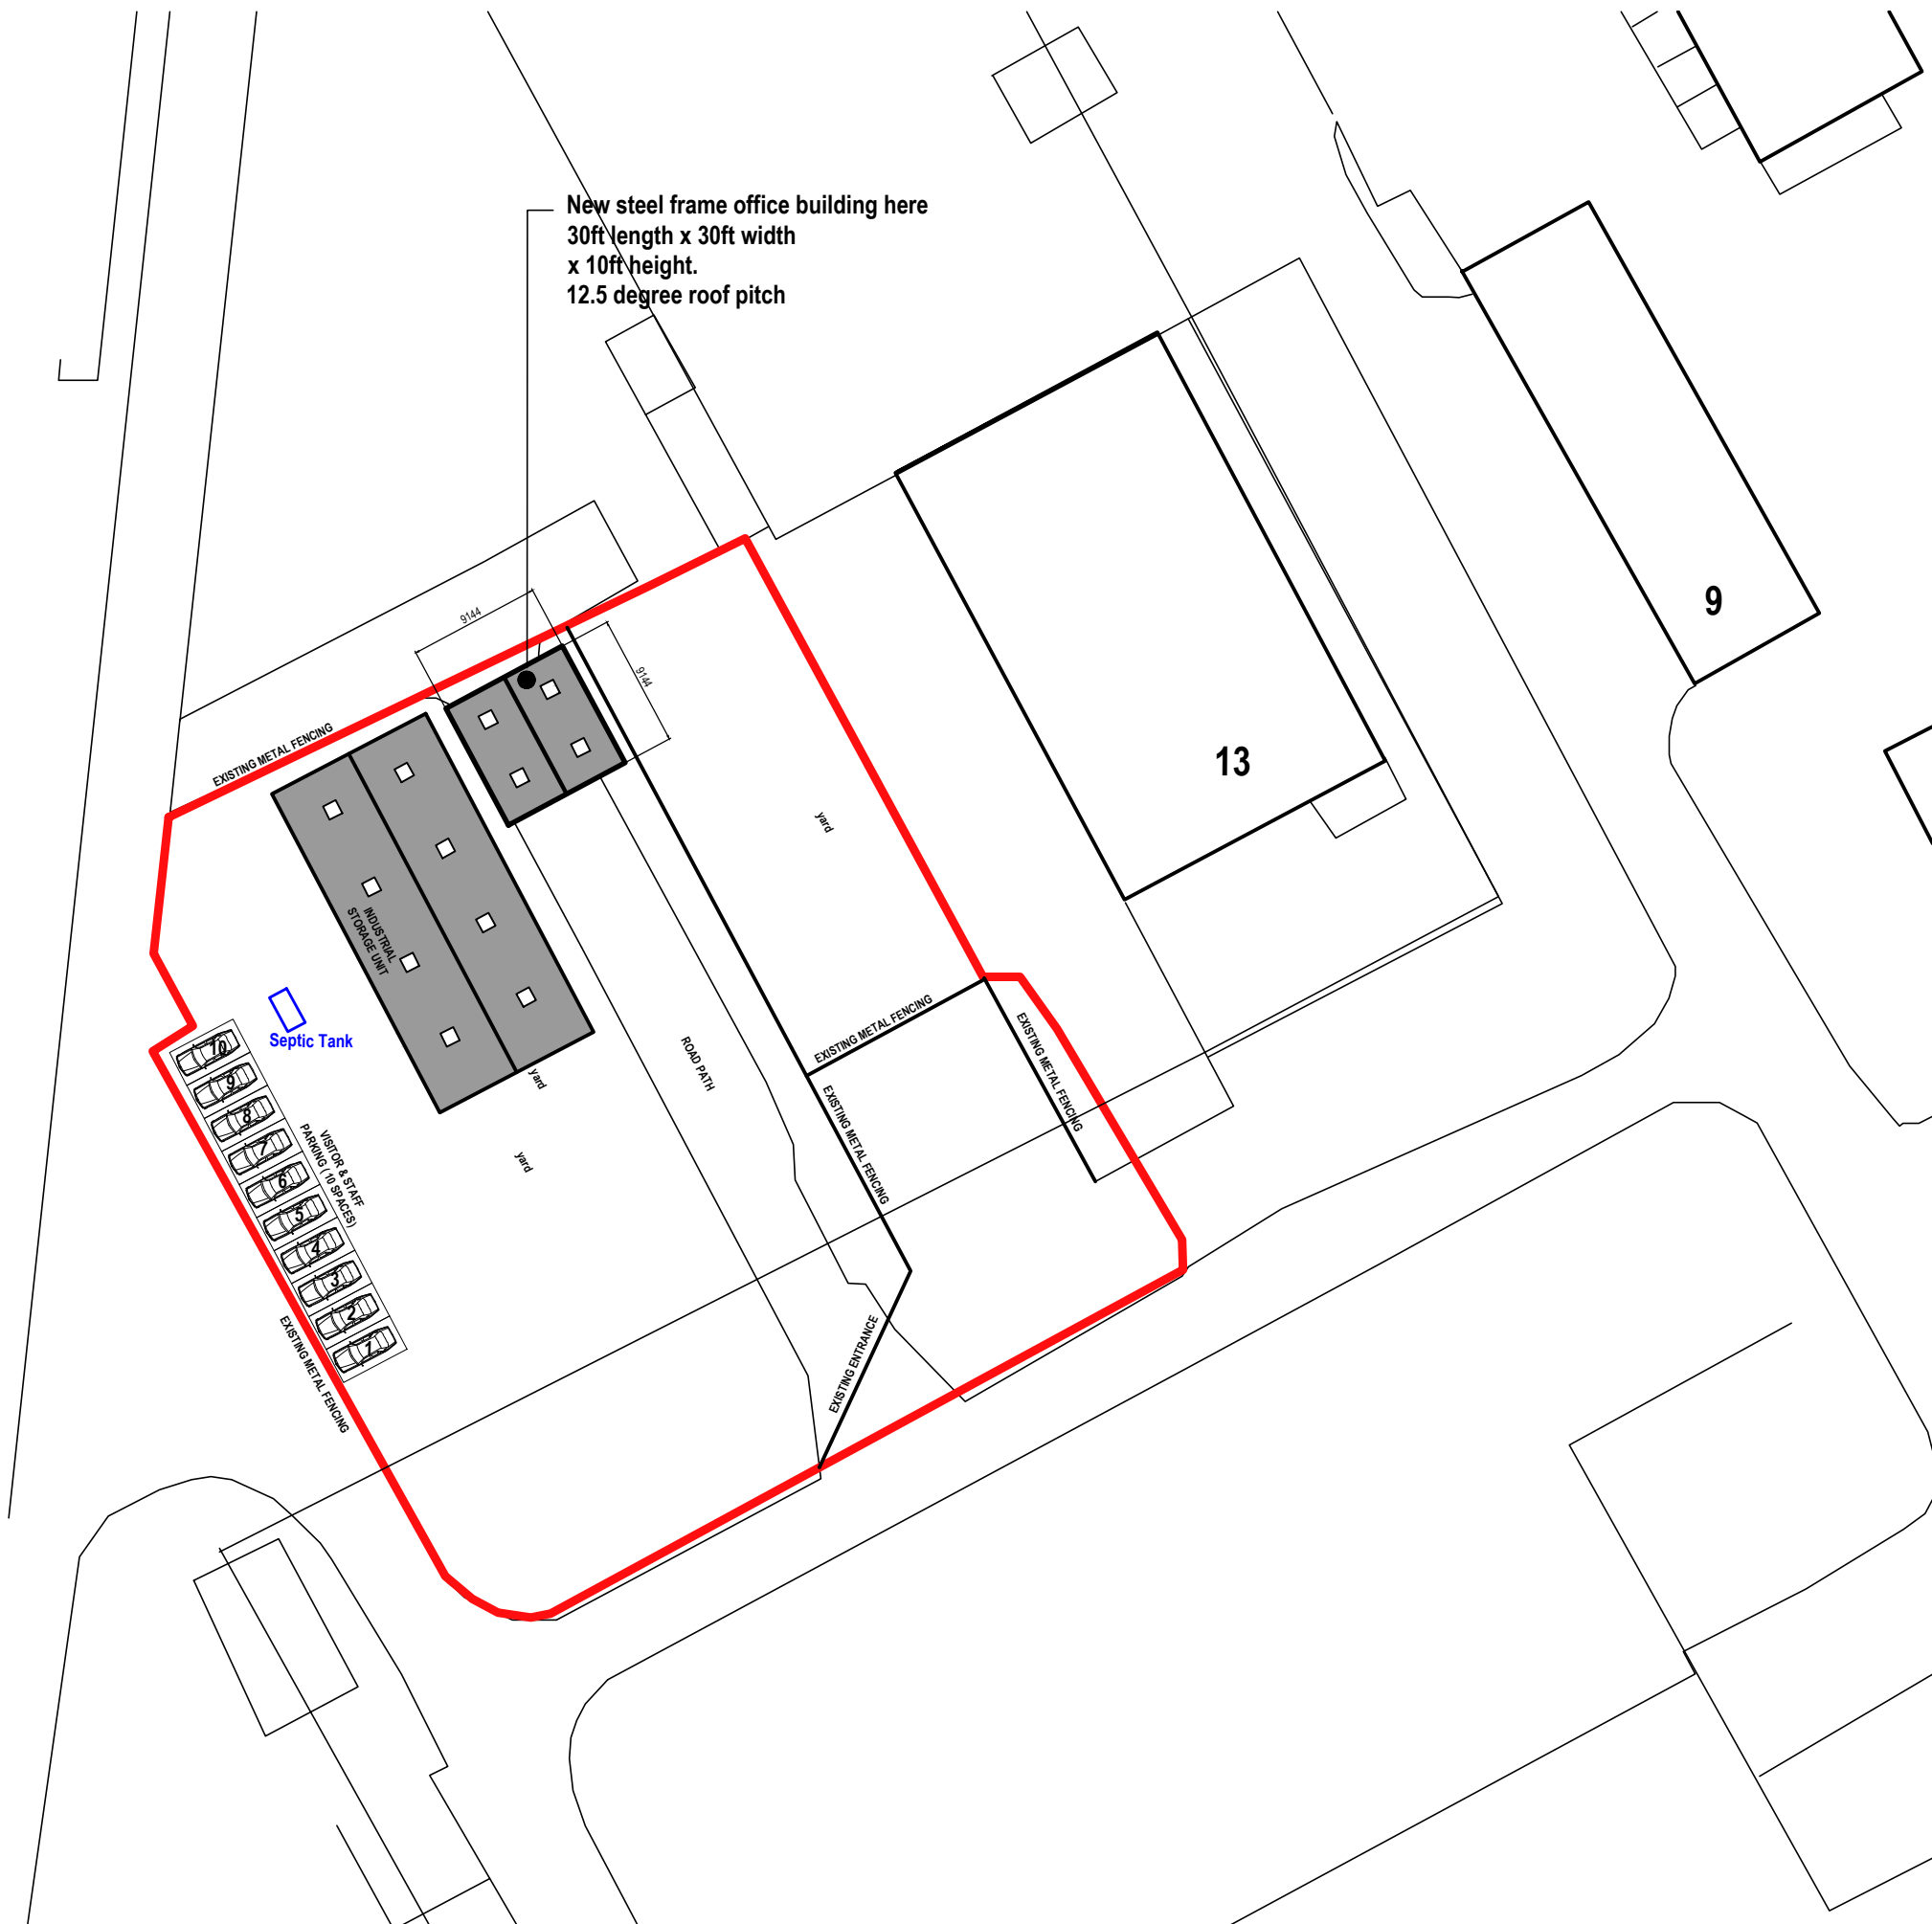


NOTE:

The Contractor is to check and verify all building and site dimensions, levels and sewer invert levels at connection points before work starts.

This drawing must be read with and checked against any structural or other specialist drawings provided.

The Contractor is to comply in all respects with the current Building Regulations whether or not specifically stated on these drawings.

This drawing is not intended to show details of foundation or ground conditions. Each area of ground relied upon to support the structure depicted must be investigated by the Contractor and suitable methods of foundation be provided.

Rev.				By	Date

DESIGN VISION 5

Contact: Angharad Randall
Email: design_vision_5@hotmail.com
Tel No: 07853 169 142

SITE ADDRESS:
TANKERTECH LTD
UNIT 11, EDWARDS WORKS
LLANDARCY SA10 6JY

DRAWING TITLE:
PROPOSED SITE LAYOUT PLAN

	DRAWN BY: AR	SCALE: A3 @ 1:500	DATE: 09/2025
Arch/Designer AR	SYSTEM PROJECT NUMBER: 151 - 2025	DRWG NO: 02	REVISION: -

Proposed Site Plan scale 1:500 @ A3