


Untitled Map

Write a description for your map.



Kingfisher Lighting

Part of the Luceco PLC group of companies **LUCECO**

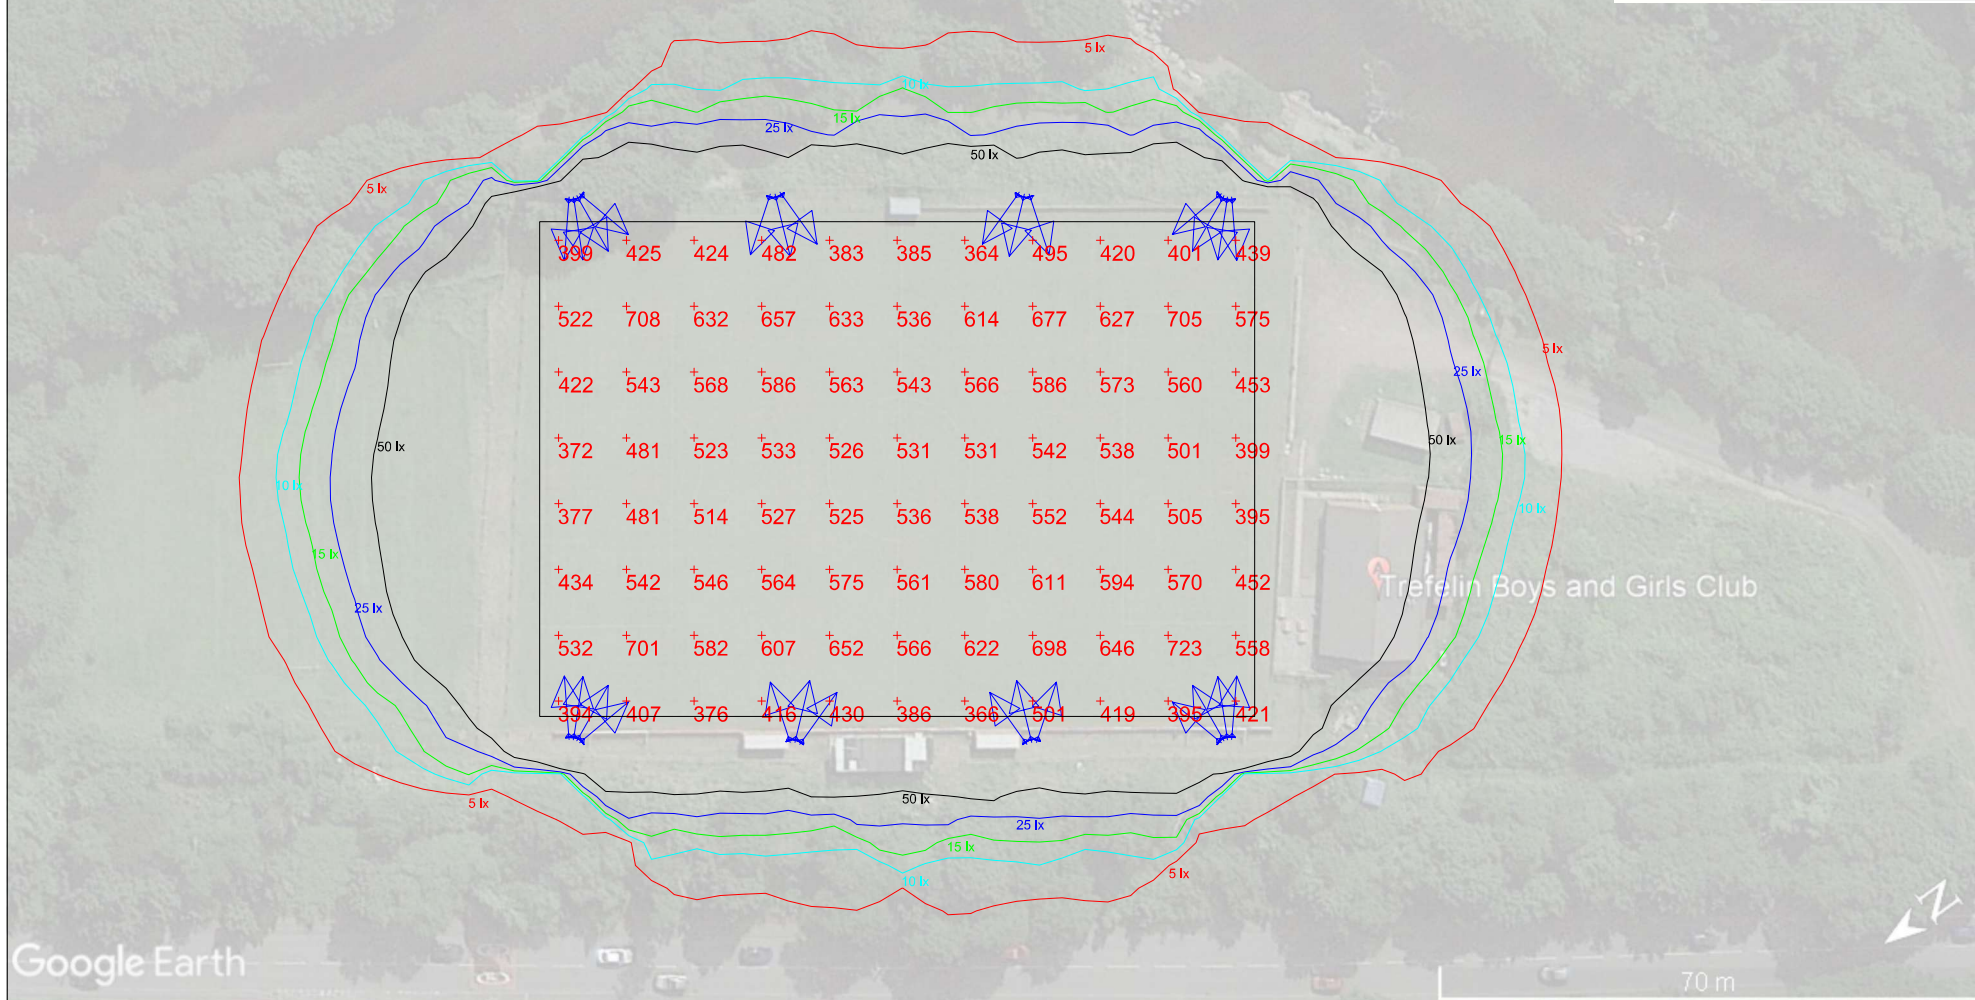

Calculation Summary							
Label	CalcType	Units	Avg	Max	Min	Min/Avg	Min/Max
Football Field	Illuminance	Lux	521.18	723	364	0.70	0.50
ISO	Illuminance	Lux	122.16	738	0	0.00	0.00

Luminaire Schedule				
Symbol	Qty	Label	Arrangement	Description
	28	A	SINGLE	1 x Amnis 1350W Short Narrow Throw Mounted @ 15m New



Trefelin RFU



For our LED lighting designs a 0.5m has been used. If this differs from the maintenance period for this project then you must advise us accordingly.

Scale	Project Number
1: 500 at A2	DI - DESIGN A TREFELIN F.C.
Date	Drawing No.
06/08/2020	Design 1
Lighting Designer: Tom Ford	

A lighting applications design service is provided by us in good faith and without charge, relating to Kingfisher products only. As such, whilst every endeavor is made for accuracy from information provided by yourselves, the final responsibility for the suitability of the design lies with the client. The company cannot, therefore, accept any liability or consequential loss incurred.

A2